



COMMUNITY OF EAGLE ROCK

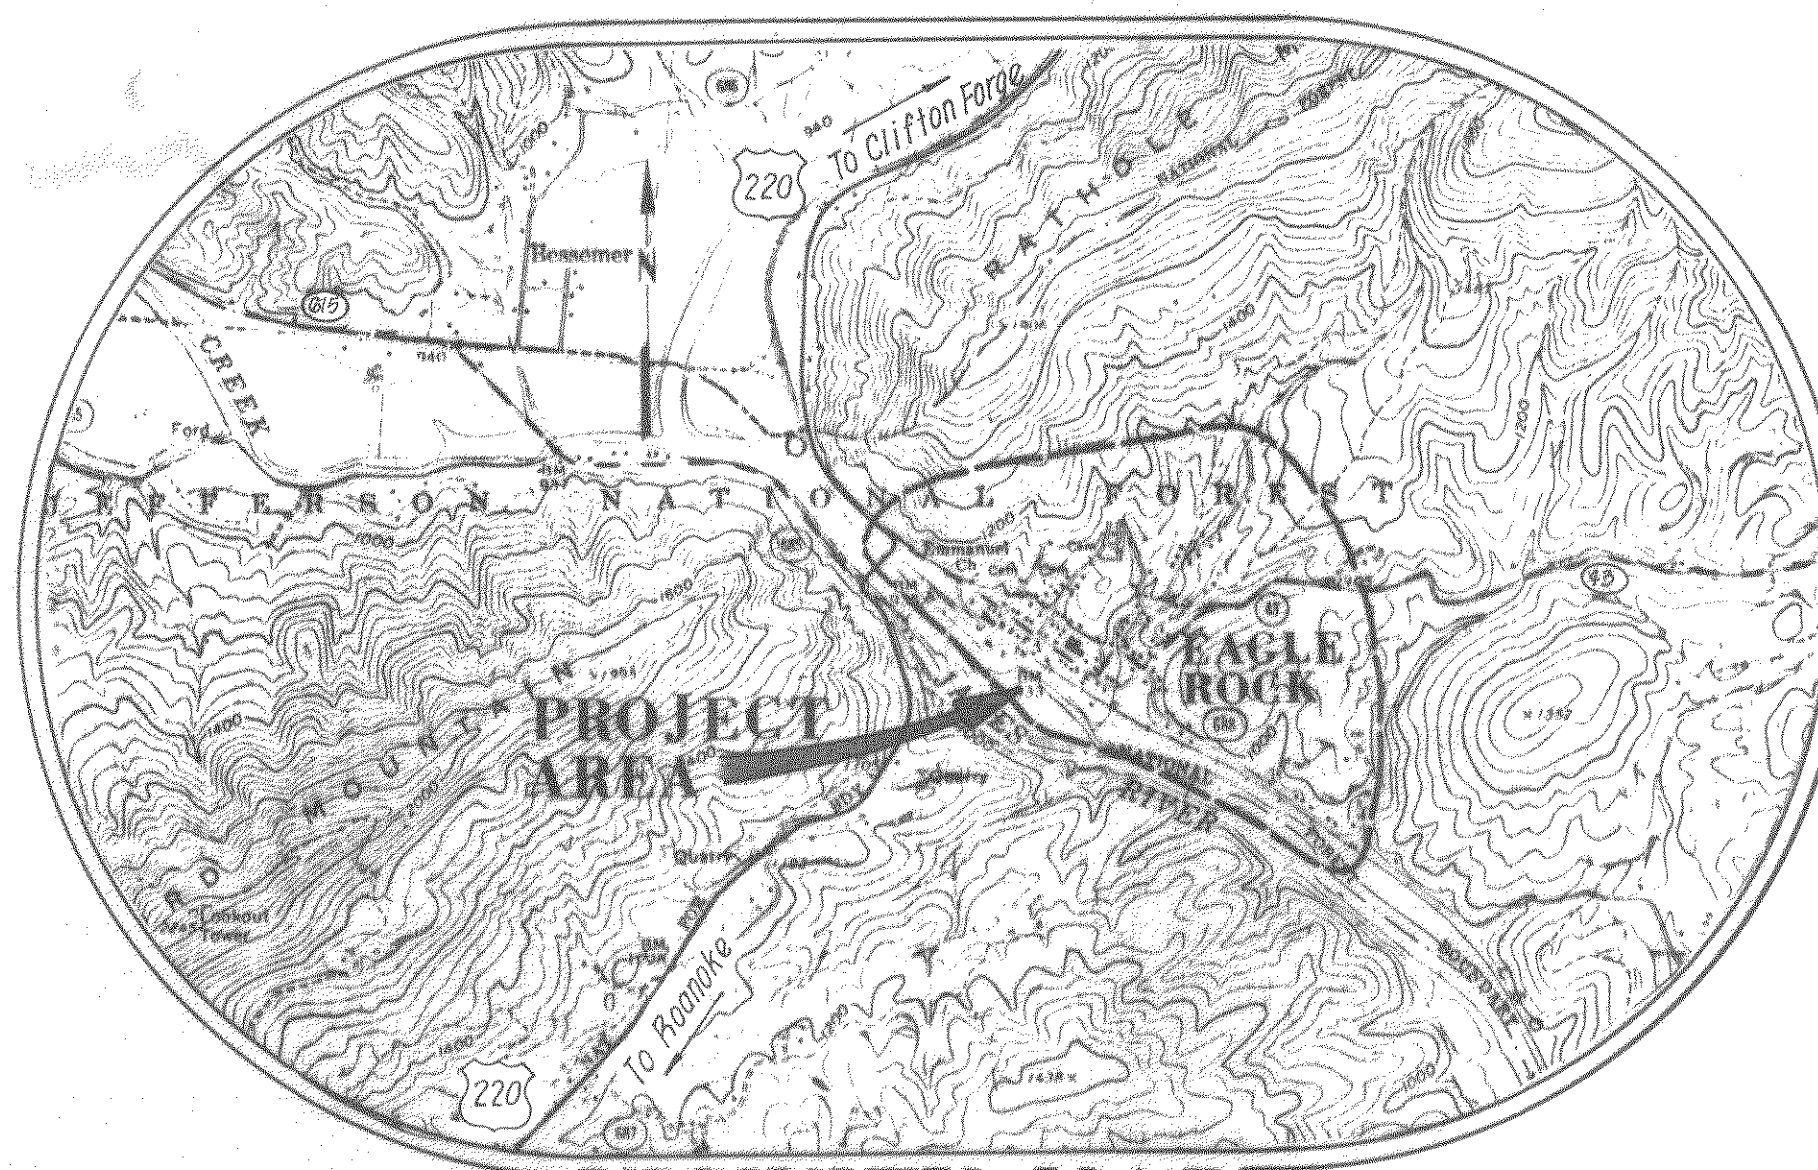

VICINITY MAP

Scale: 1" = 2000'

WASTEWATER COLLECTION & TREATMENT SYSTEM FOR BOTETOURT COUNTY BOARD OF SUPERVISORS

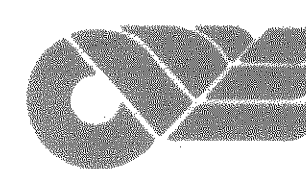 Clean Water Engineers, Inc.
7 East Main Street
Fincastle, Virginia 24090

Project No. 90142
Date: April, 1991

"AS BUILT"


(16) Eagle Rock Wastewater
Collection & Treatment System
PROJECT NAME: Eagle Rock Wastewater
DATE: April 1991
TYPE: Sewer
LOCATION: Eagle Rock
TOTAL # SHEETS: 14
OF SETS: 1
A/E/FIRM: Cleanwater


LEGEND

- PROPOSED SANITARY SEWER MANHOLE
- PROPOSED SANITARY SEWER CLEANOUT
- PROPOSED FORCE MAIN
- APPROXIMATE LOCATION OF EXISTING SEWER LINES
- SERVICE CONNECTION
- WELDED STEEL CASING
- S.S. SANITARY SEWER
- BRANCH

INDEX	
COVER SHEET	SHEET 1
SITE PLAN & INDEX	2
CONTRACT II : SEWAGE COLLECTION SYSTEM	
PLAN SHEETS	3 - 6
PROFILES	7 - 11
CONTRACT I : TREATMENT PLANT	
SITE PLAN & DESIGN CRITERIA	12
HYDRAULIC PROFILE	13
PUMP STATION	14
AERATION CASCADE & EQUIPMENT SCHEDULE	15
WASTEWATER TREATMENT PLANT	16
SAND DRYING BEDS	17
CONTROL BUILDING & ELECTRICAL	18
DETAILS	19


- GENERAL NOTES
- VERTICAL CONTROL: NATIONAL GEODETIC VERTICAL DATUM MEAN SEA LEVEL 1929
HORIZONTAL CONTROL: STATE PLANE COORDINATE SYSTEM (SOUTH ZONE)
 - AERIAL TOPOGRAPHY ACCOMPLISHED JANUARY, 1987 BY WOOLPERT CONSULTANTS, CHARLOTTE, NORTH CAROLINA
 - HORIZONTAL/VERTICAL CONTROL ESTABLISHED BY CHARLES R. MCHURRY, CCS, DALEVILLE, VIRGINIA
 - ROCK QUANTITIES ARE THE ENGINEER'S ESTIMATE ONLY. THEY ARE TO BE USED BY THE CONTRACTOR AS AN AID TO PRICING THE LINE WORK AND IT SHALL BE THE CONTRACTOR'S RESPONSIBILITY TO SATISFY HIMSELF AS TO ALL CONDITIONS OF WORK BEFORE BIDDING
 - UNLESS OTHERWISE NOTED, THE LOCATIONS OF EXISTING UNDERGROUND UTILITIES ARE APPROXIMATE AND SHOULD BE VERIFIED BY CONTRACTOR PRIOR TO CONSTRUCTION. CONTRACTOR SHALL NOTIFY "UNDERGROUND CABLE LOCATION," 1-800-552-7001, AT LEAST 48 HOURS IN ADVANCE OF EXCAVATION IN ORDER TO VERIFY LOCATION OF UNDERGROUND UTILITIES
 - UNLESS OTHERWISE NOTED, EXISTING SURFACES DISTURBED BY CONTRACTOR'S WORK SHALL BE RESTORED TO THEIR PRECONSTRUCTION CONDITION
 - CONTRACTOR SHALL PERFORM WORK IN SUCH A MANNER AS TO MINIMIZE SOIL EROSION
 - HIGHWAY TRAFFIC SHALL BE PROTECTED AT ALL TIMES BY ADEQUATE LIGHTS, BARRICADES, AND CONSTRUCTION SIGNS. SIGNS SHALL BE IN ACCORDANCE WITH "VIRGINIA MANUAL ON UNIFORM TRAFFIC CONTROL DEVICES" AND ARE TO BE LOCATED AS DIRECTED BY THE RESIDENT ENGINEER OF THE DEPARTMENT OF HIGHWAYS. CONTRACTOR SHALL PROVIDE FLAGPERSONS AS REQUIRED
 - THERE SHALL BE 10' MINIMUM HORIZONTAL SEPARATION BETWEEN WATER AND SEWER LINES AND 18" MINIMUM VERTICAL SEPARATION WHERE SPECIFIED
 - ALL CONSTRUCTION MATERIAL AND EQUIPMENT SHALL BE KEPT WITHIN STATE RIGHT OF WAY AND NOT ON ADJACENT PROPERTIES (WHERE APPLICABLE)
 - LOCATIONS OF EXISTING WATER LINES ARE APPROXIMATE. CONTRACTOR SHOULD VERIFY EXACT LOCATIONS PRIOR TO PERFORMANCE OF WORK IN AREAS SHOWN NEAR WATER LINES. COPIES OF WATER LINE PLANS MAY BE OBTAINED FROM CLEAN WATER ENGINEERS, INC. CONTACT EAGLE ROCK WATER SYSTEM, MR. TONNY HUNTER, AT 703-884-2433 IN CASE OF EMERGENCIES.
 - LOCATION OF EXISTING SEWER COLLECTION SYSTEM IS APPROXIMATE. NO PLANS ARE AVAILABLE ESTABLISHING PRECISE LOCATIONS. EXISTING COLLECTION SYSTEM IS TO REMAIN IN SERVICE UNTIL COMPLETION OF BOTH CONTRACT I AND CONTRACT II. CONTRACTOR IS RESPONSIBLE FOR LOCATION AND PROTECTION OF EXISTING SEWAGE COLLECTION SYSTEM
 - CONTRACTOR SHALL PERFORM WORK IN SUCH A MANNER TO MINIMIZE DAMAGE TO EXISTING ROCK CHANNELS AND RETAINING WALLS. ANY DAMAGE TO CHANNELS OR WALLS SHALL BE REPAIRED AND CHANNELS AND WALLS RESTORED TO THEIR PRECONSTRUCTION CONDITION
 - PLANT ROADWAY IS TO REMAIN OPEN DURING CONSTRUCTION, OR, IF NECESSARY, THE CONTRACTOR SHALL PROVIDE TEMPORARY ROADWAY AS NECESSARY TO PERFORM WORK
 - FLOODPLAIN INFORMATION PROVIDED WAS TAKEN FROM FEDERAL INSURANCE ADMINISTRATION FLOOD INSURANCE STUDY, BOTETOURT COUNTY, VIRGINIA, DECEMBER 1977.

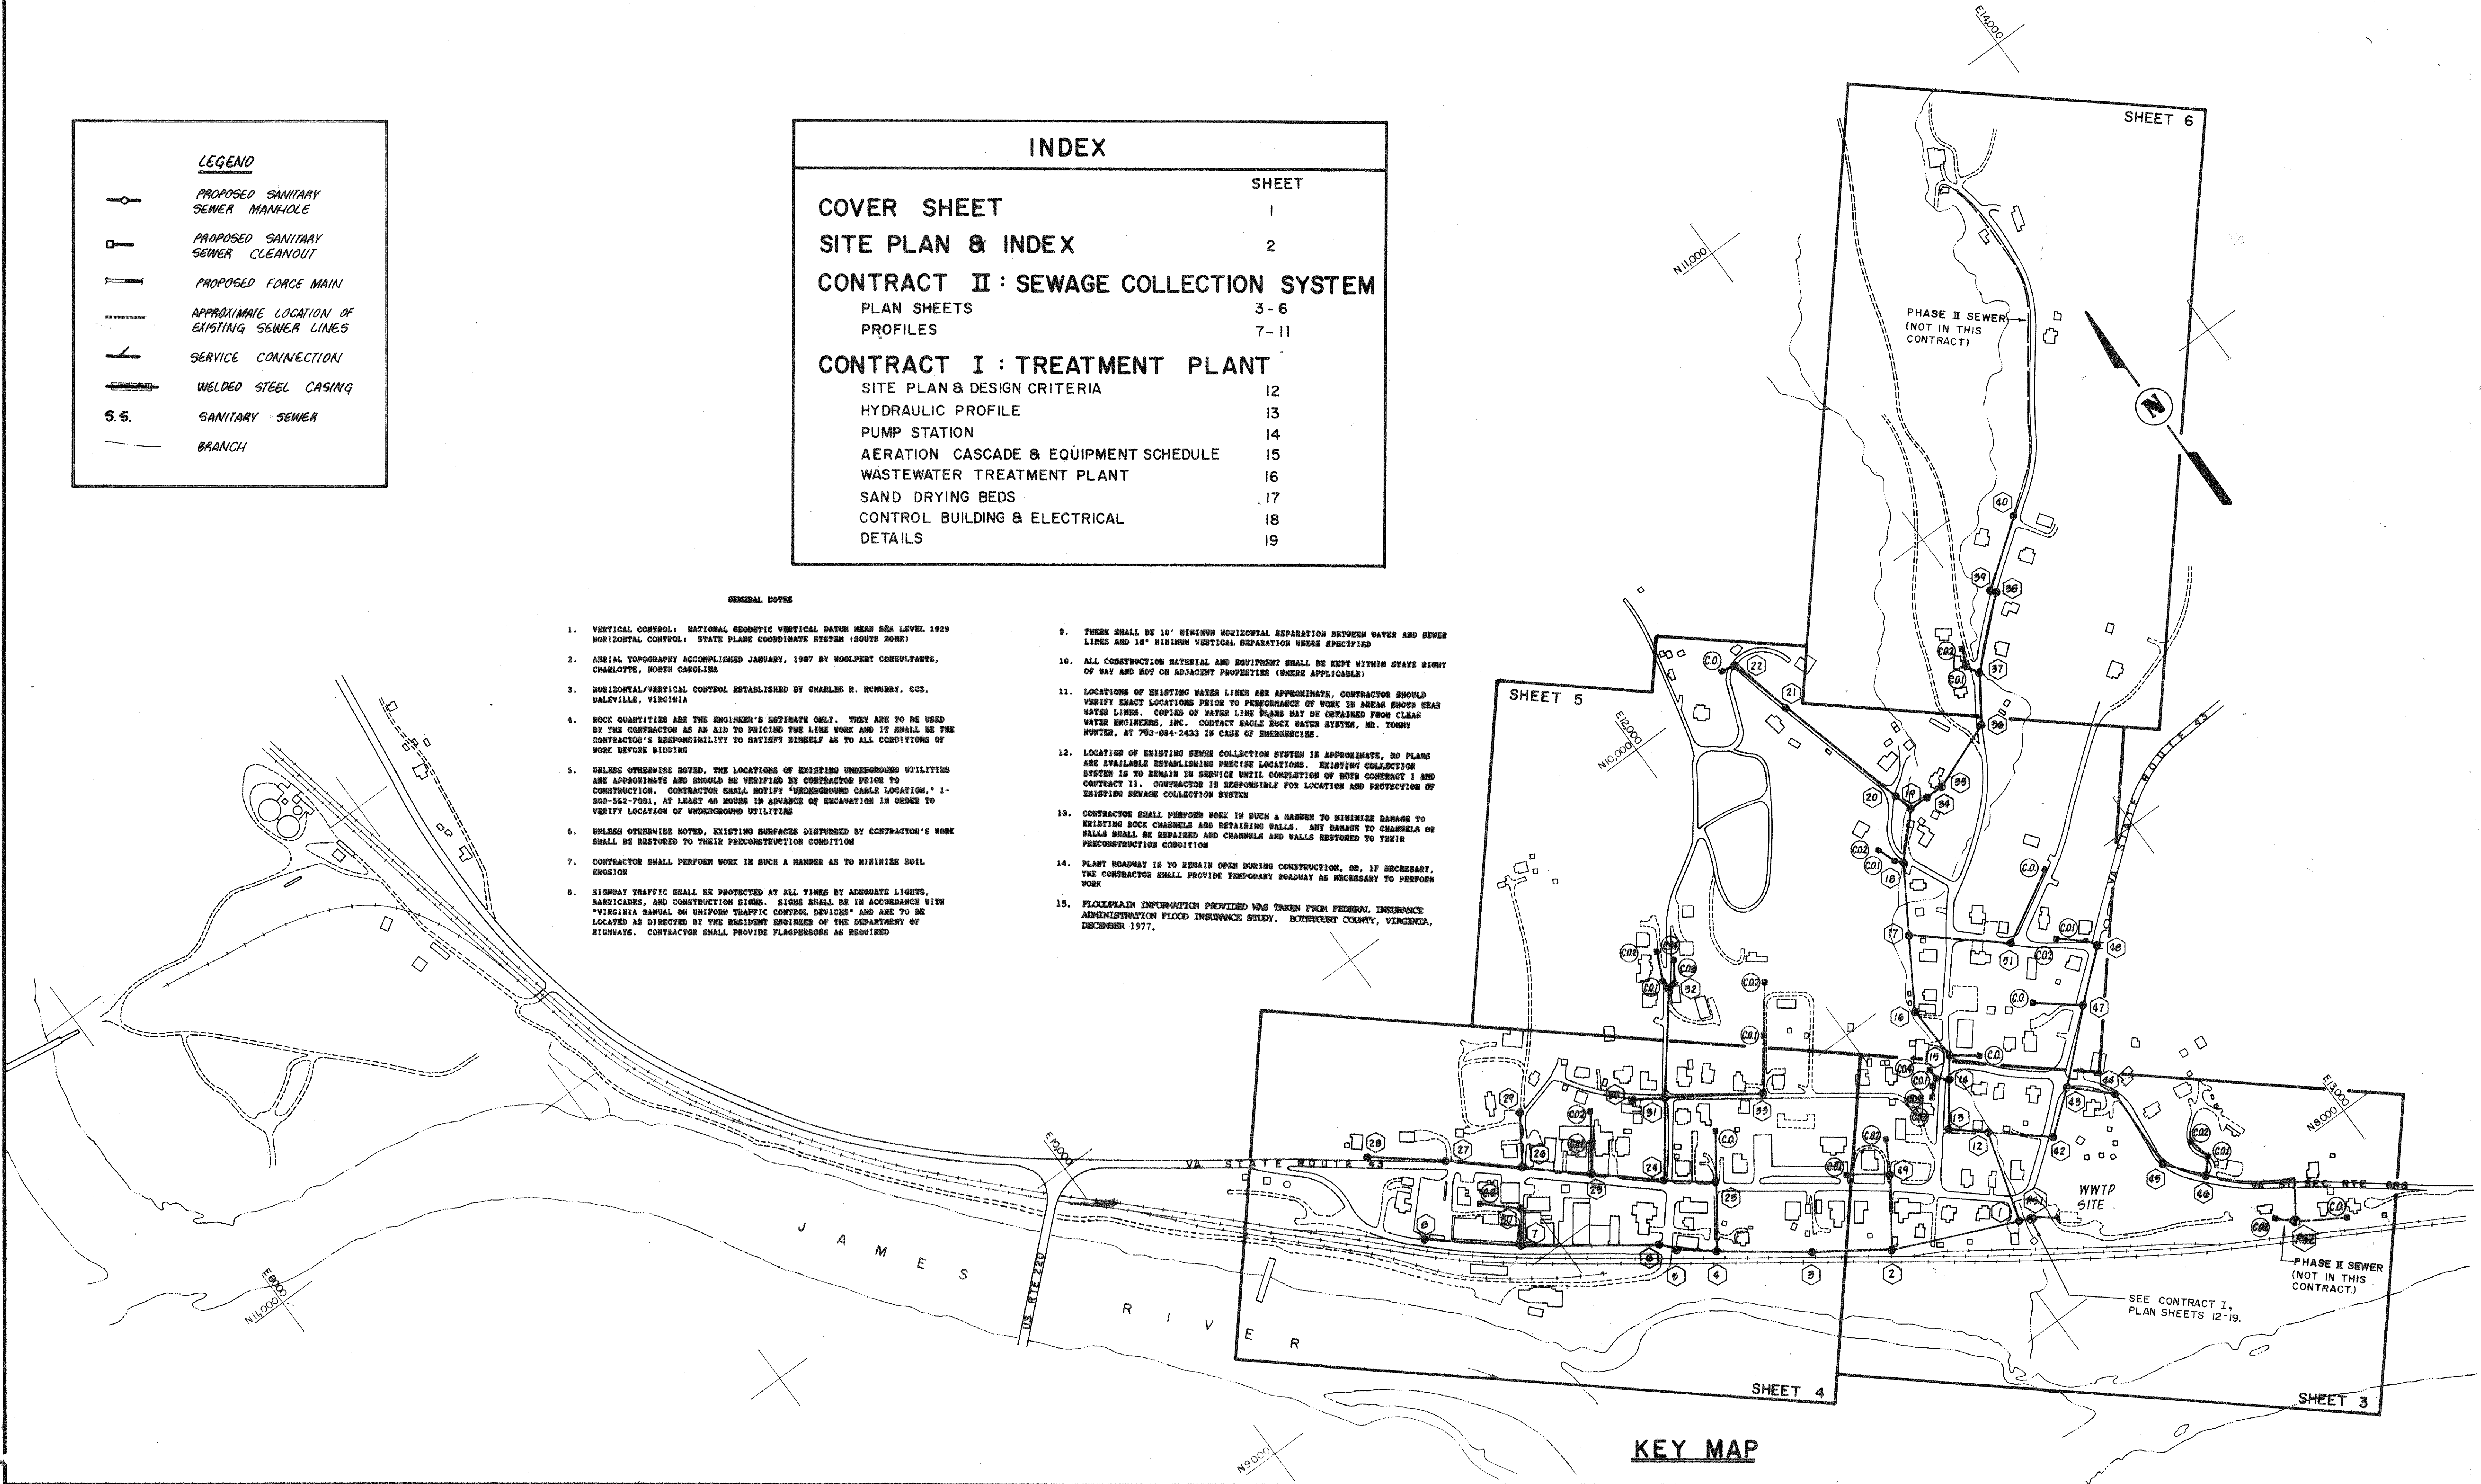


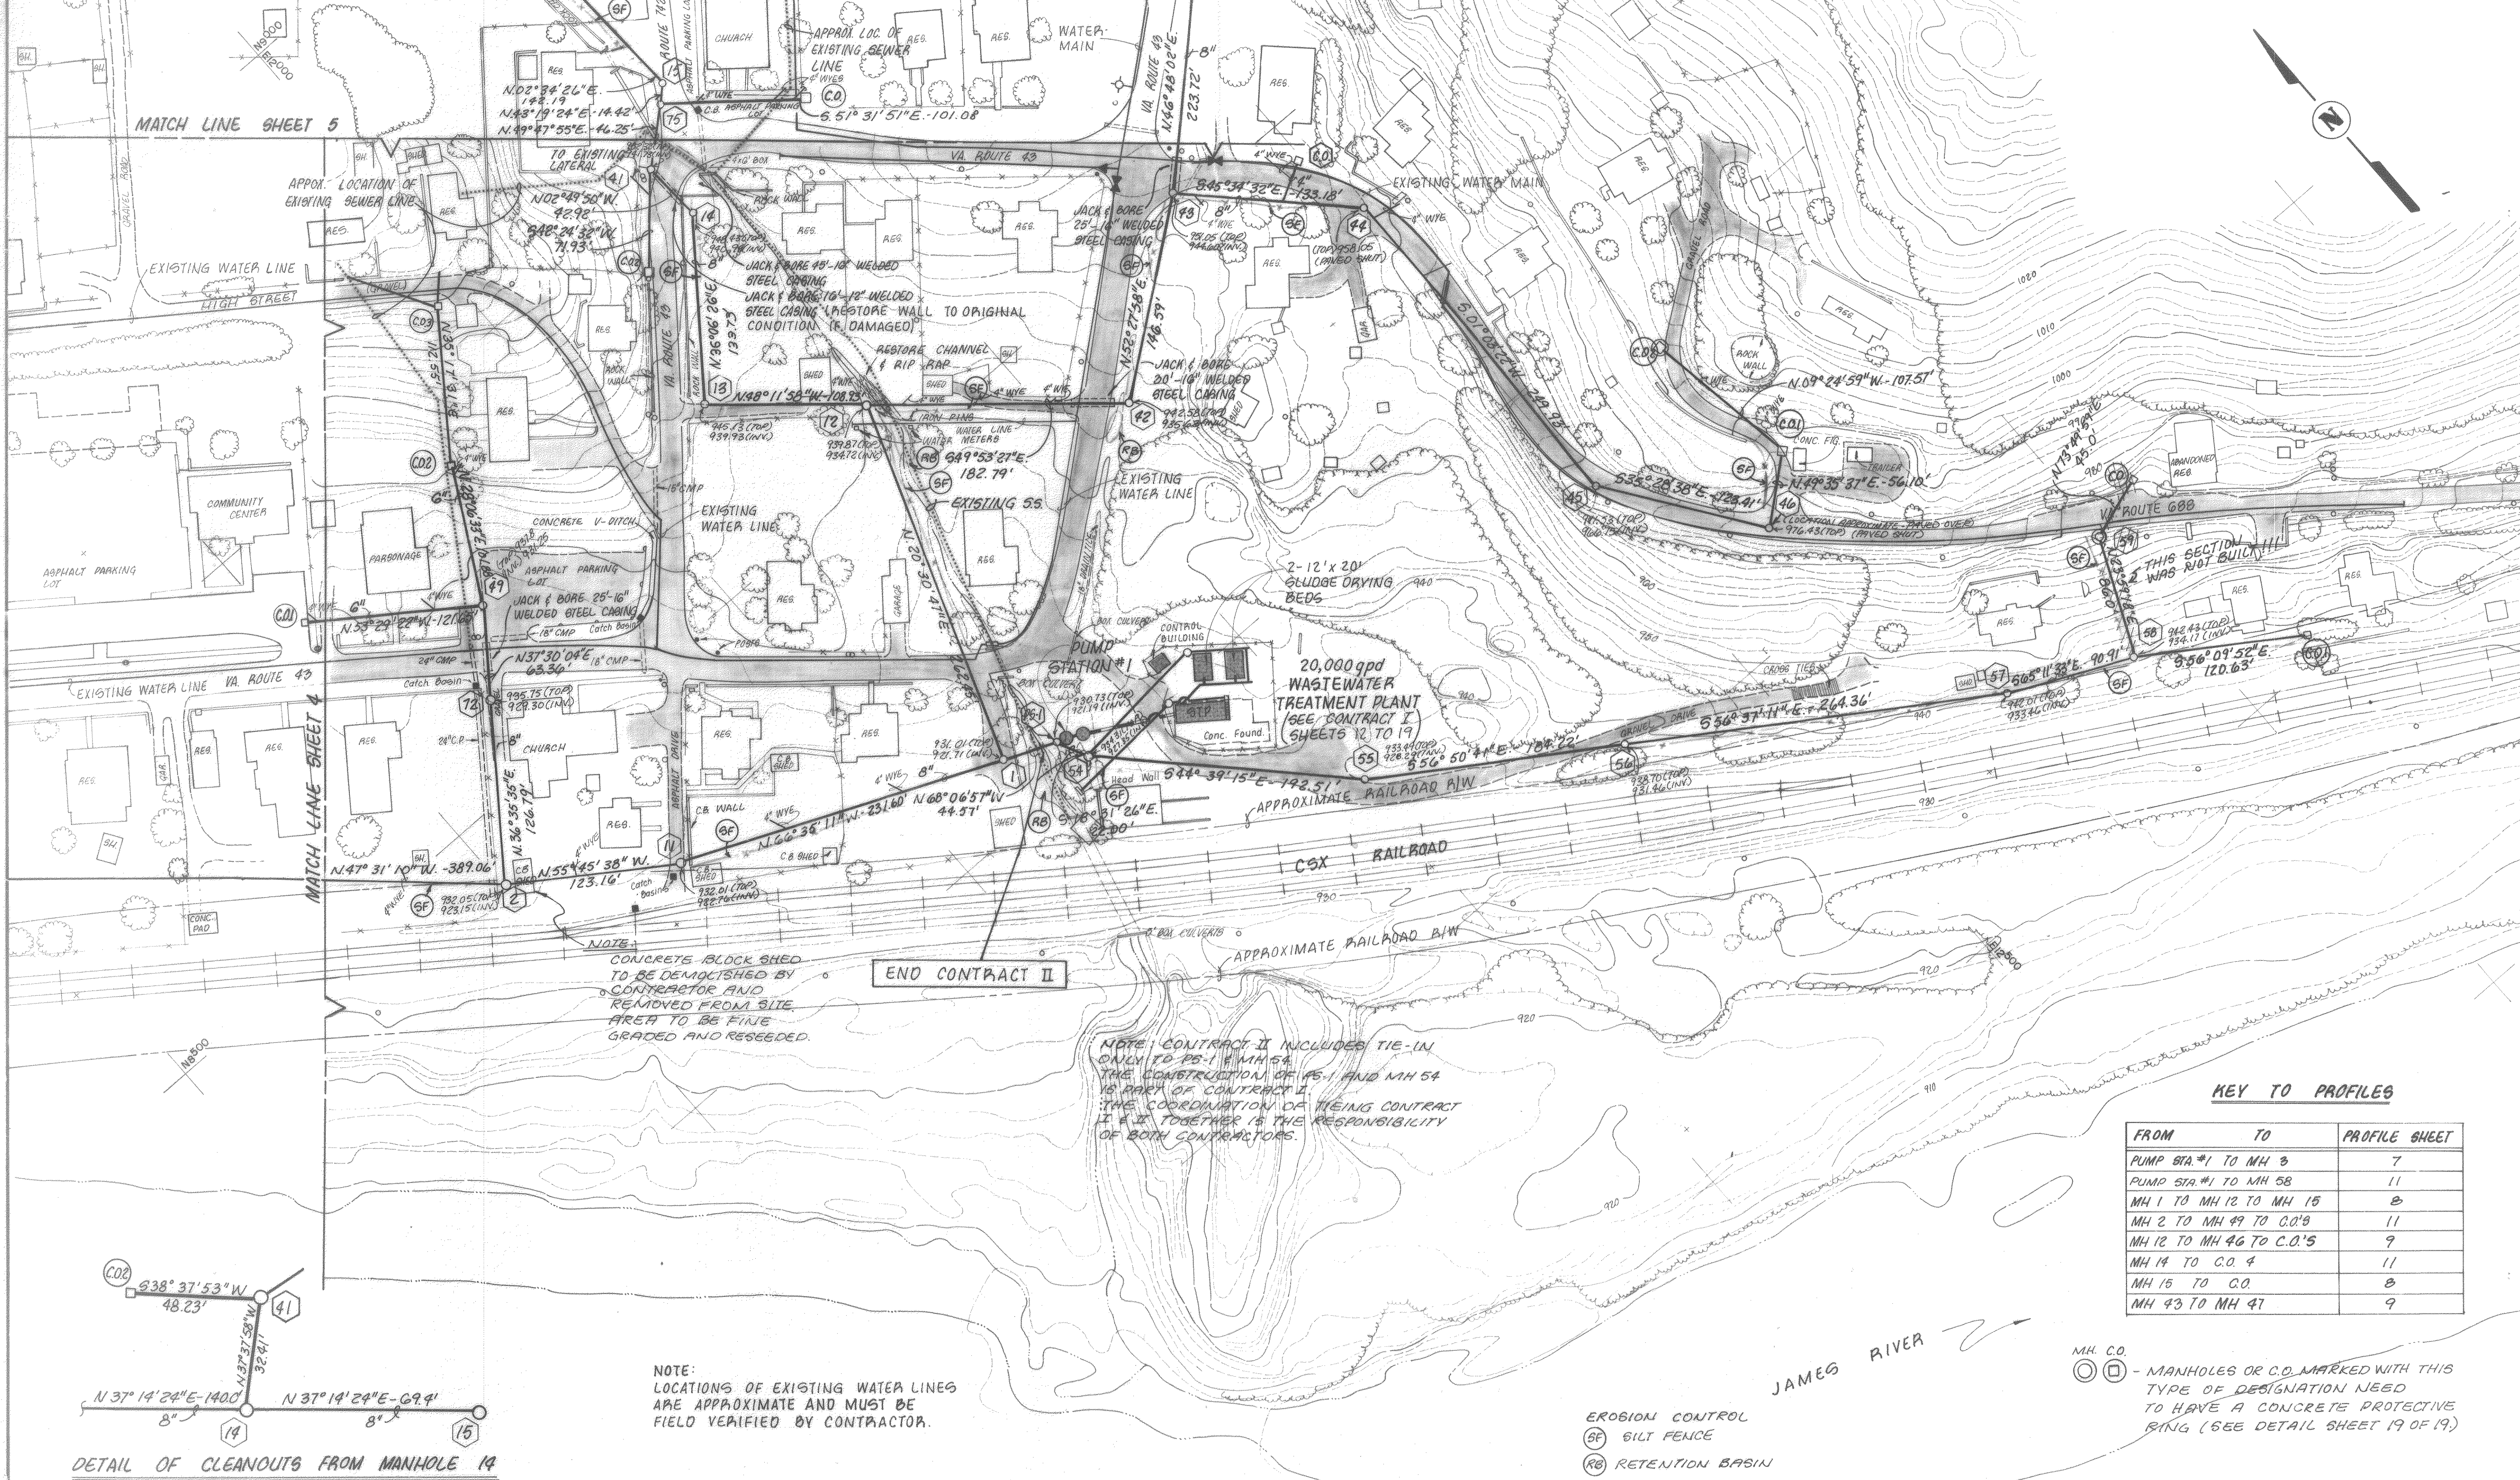

KEY TO PROFILES

FROM	TO	PROFILE SHEET
PUMP STA. #1 TO MH 3		7
PUMP STA. #1 TO MH 58		11
MH 1 TO MH 12 TO MH 15		8
MH 2 TO MH 49 TO C.O.'S		11
MH 12 TO MH 46 TO C.O.'S		9
MH 14 TO C.O. 4		11
MH 16 TO C.O.		8
MH 43 TO MH 47		9

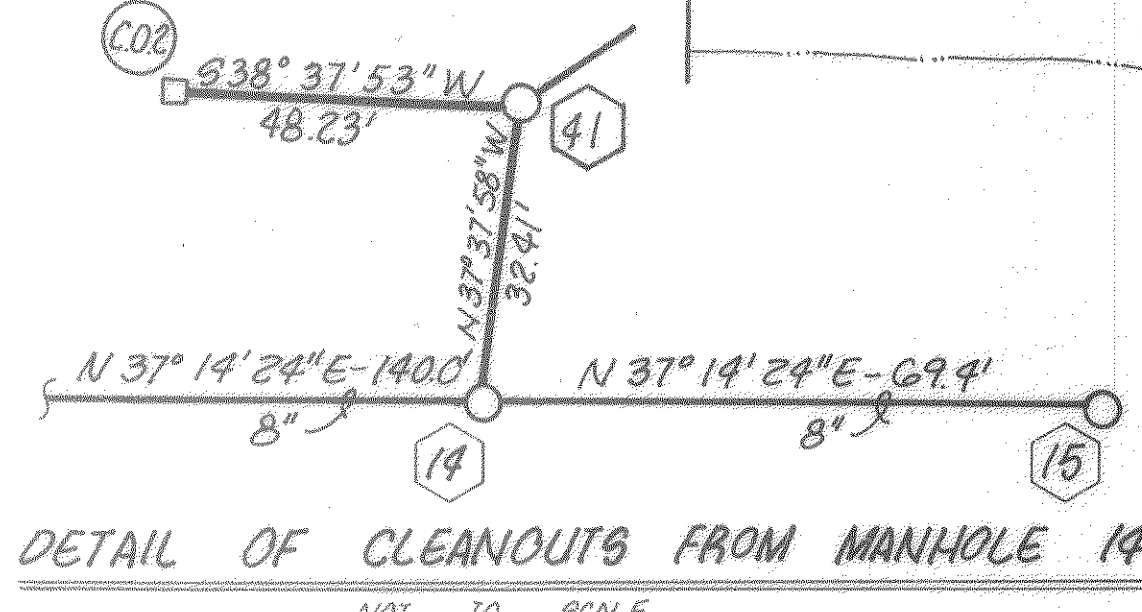

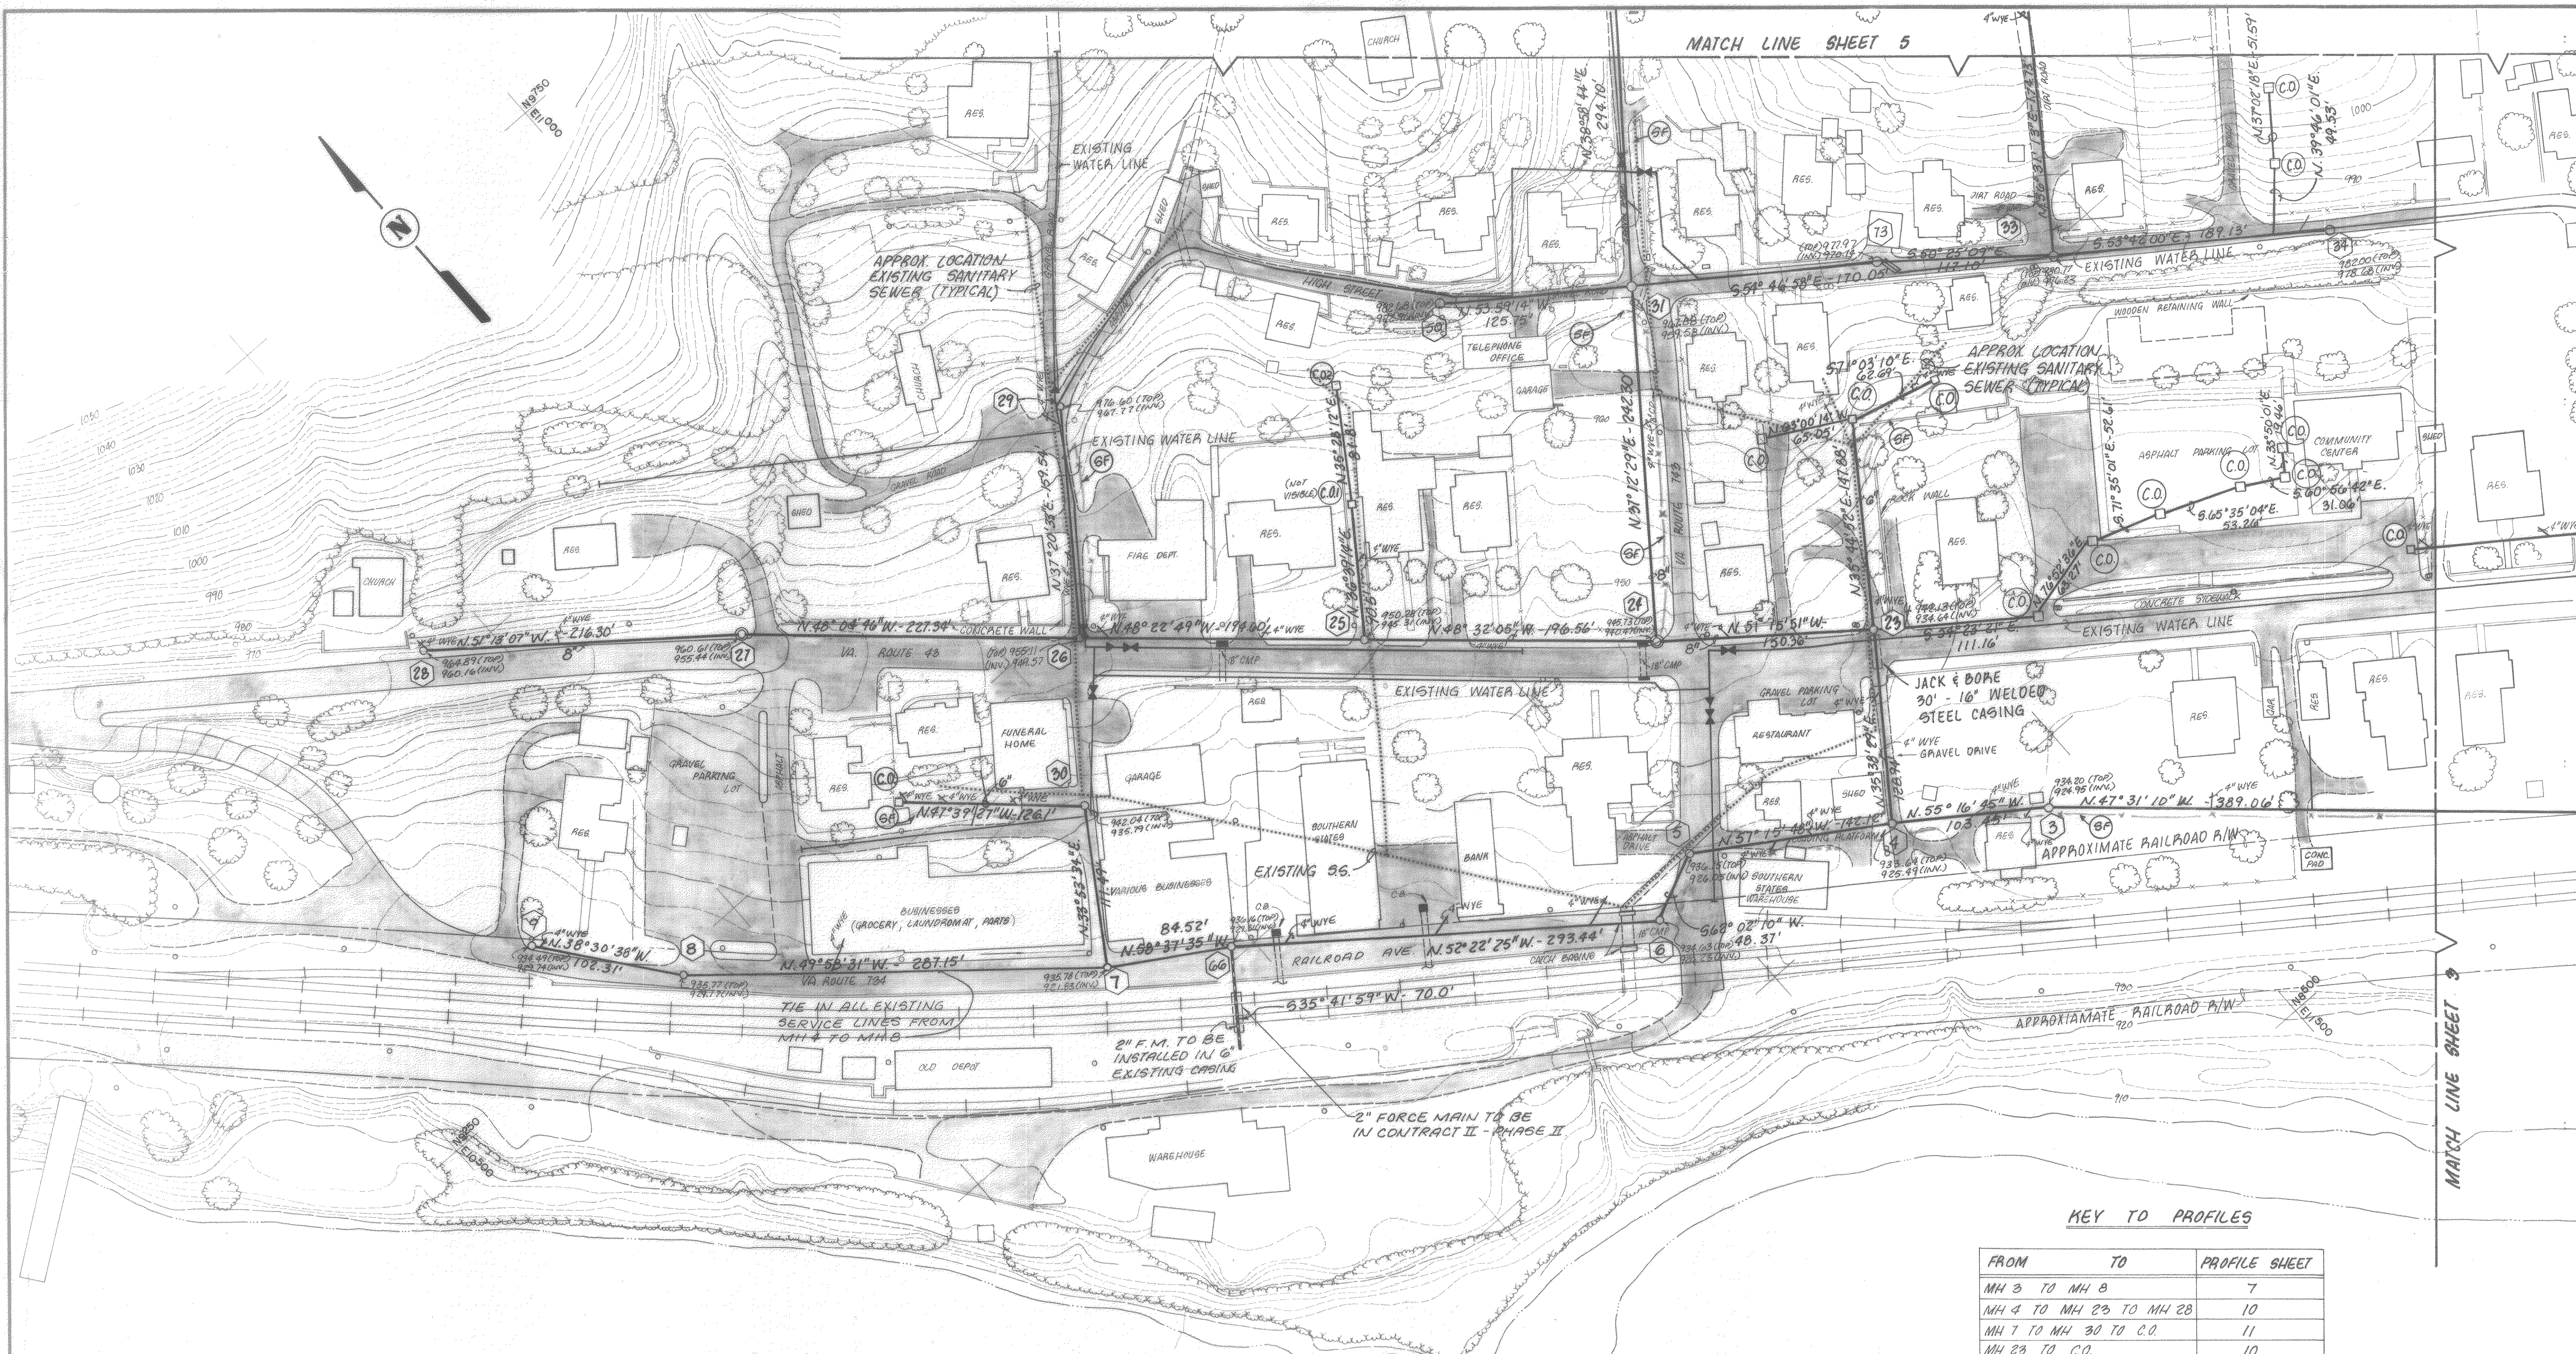

NOTE:
 LOCATION OF EXISTING WATER LINES
 ARE APPROXIMATE AND MUST BE
 FIELD VERIFIED BY CONTRACTOR

M.H. C.O.
 (C.O.) - MANHOLES OR C.O. MARKED WITH THIS
 TYPE OF DESIGNATION NEED
 TO HAVE A CONCRETE PROTECTIVE
 RING (SEE DETAIL SHEET 19 OF 19)

JAMES RIVER

KEY TO PROFILES

FROM	TO	PROFILE SHEET
MH 3 TO MH 8		7
MH 4 TO MH 23 TO MH 28		10
MH 7 TO MH 30 TO C.O.		11
MH 23 TO C.O.		10
MH 24 TO MH 31 TO MH 32		10
MH 26 TO C.O.'S		10
MH 26 TO MH 29		11
MH 31 TO MH 33 TO C.O.'S		10
MH 31 TO MH 50		11

NOTE: ROCK CHANNEL TO
BE RESTORED TO
ORIGINAL CONDITION

APPROX. LOCATION
EXISTING SANITARY
SEWER (TYPICAL)


- MANHOLES OR C.O. MARKED WITH THIS TYPE OF DESIGNATION NEED TO HAVE A CONCRETE PROTECTIVE RING (SEE DETAIL SHEET 19 OF 19).

APPROX LOCATION
EXISTING SANITARY
SEWER (TYPICAL)


Clean Water Engineers, Inc.

Fincastle, Virginia

CONTRACT II
"AS BUILT"

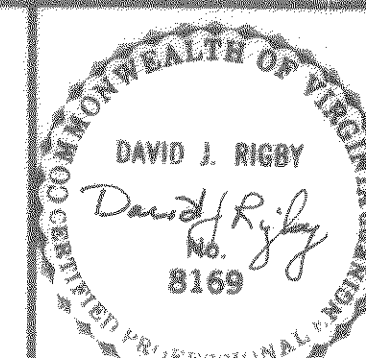

Sheet: 5 of 19
Scale: 1" = 50'
Date: DEC. 1987
Project: 86019




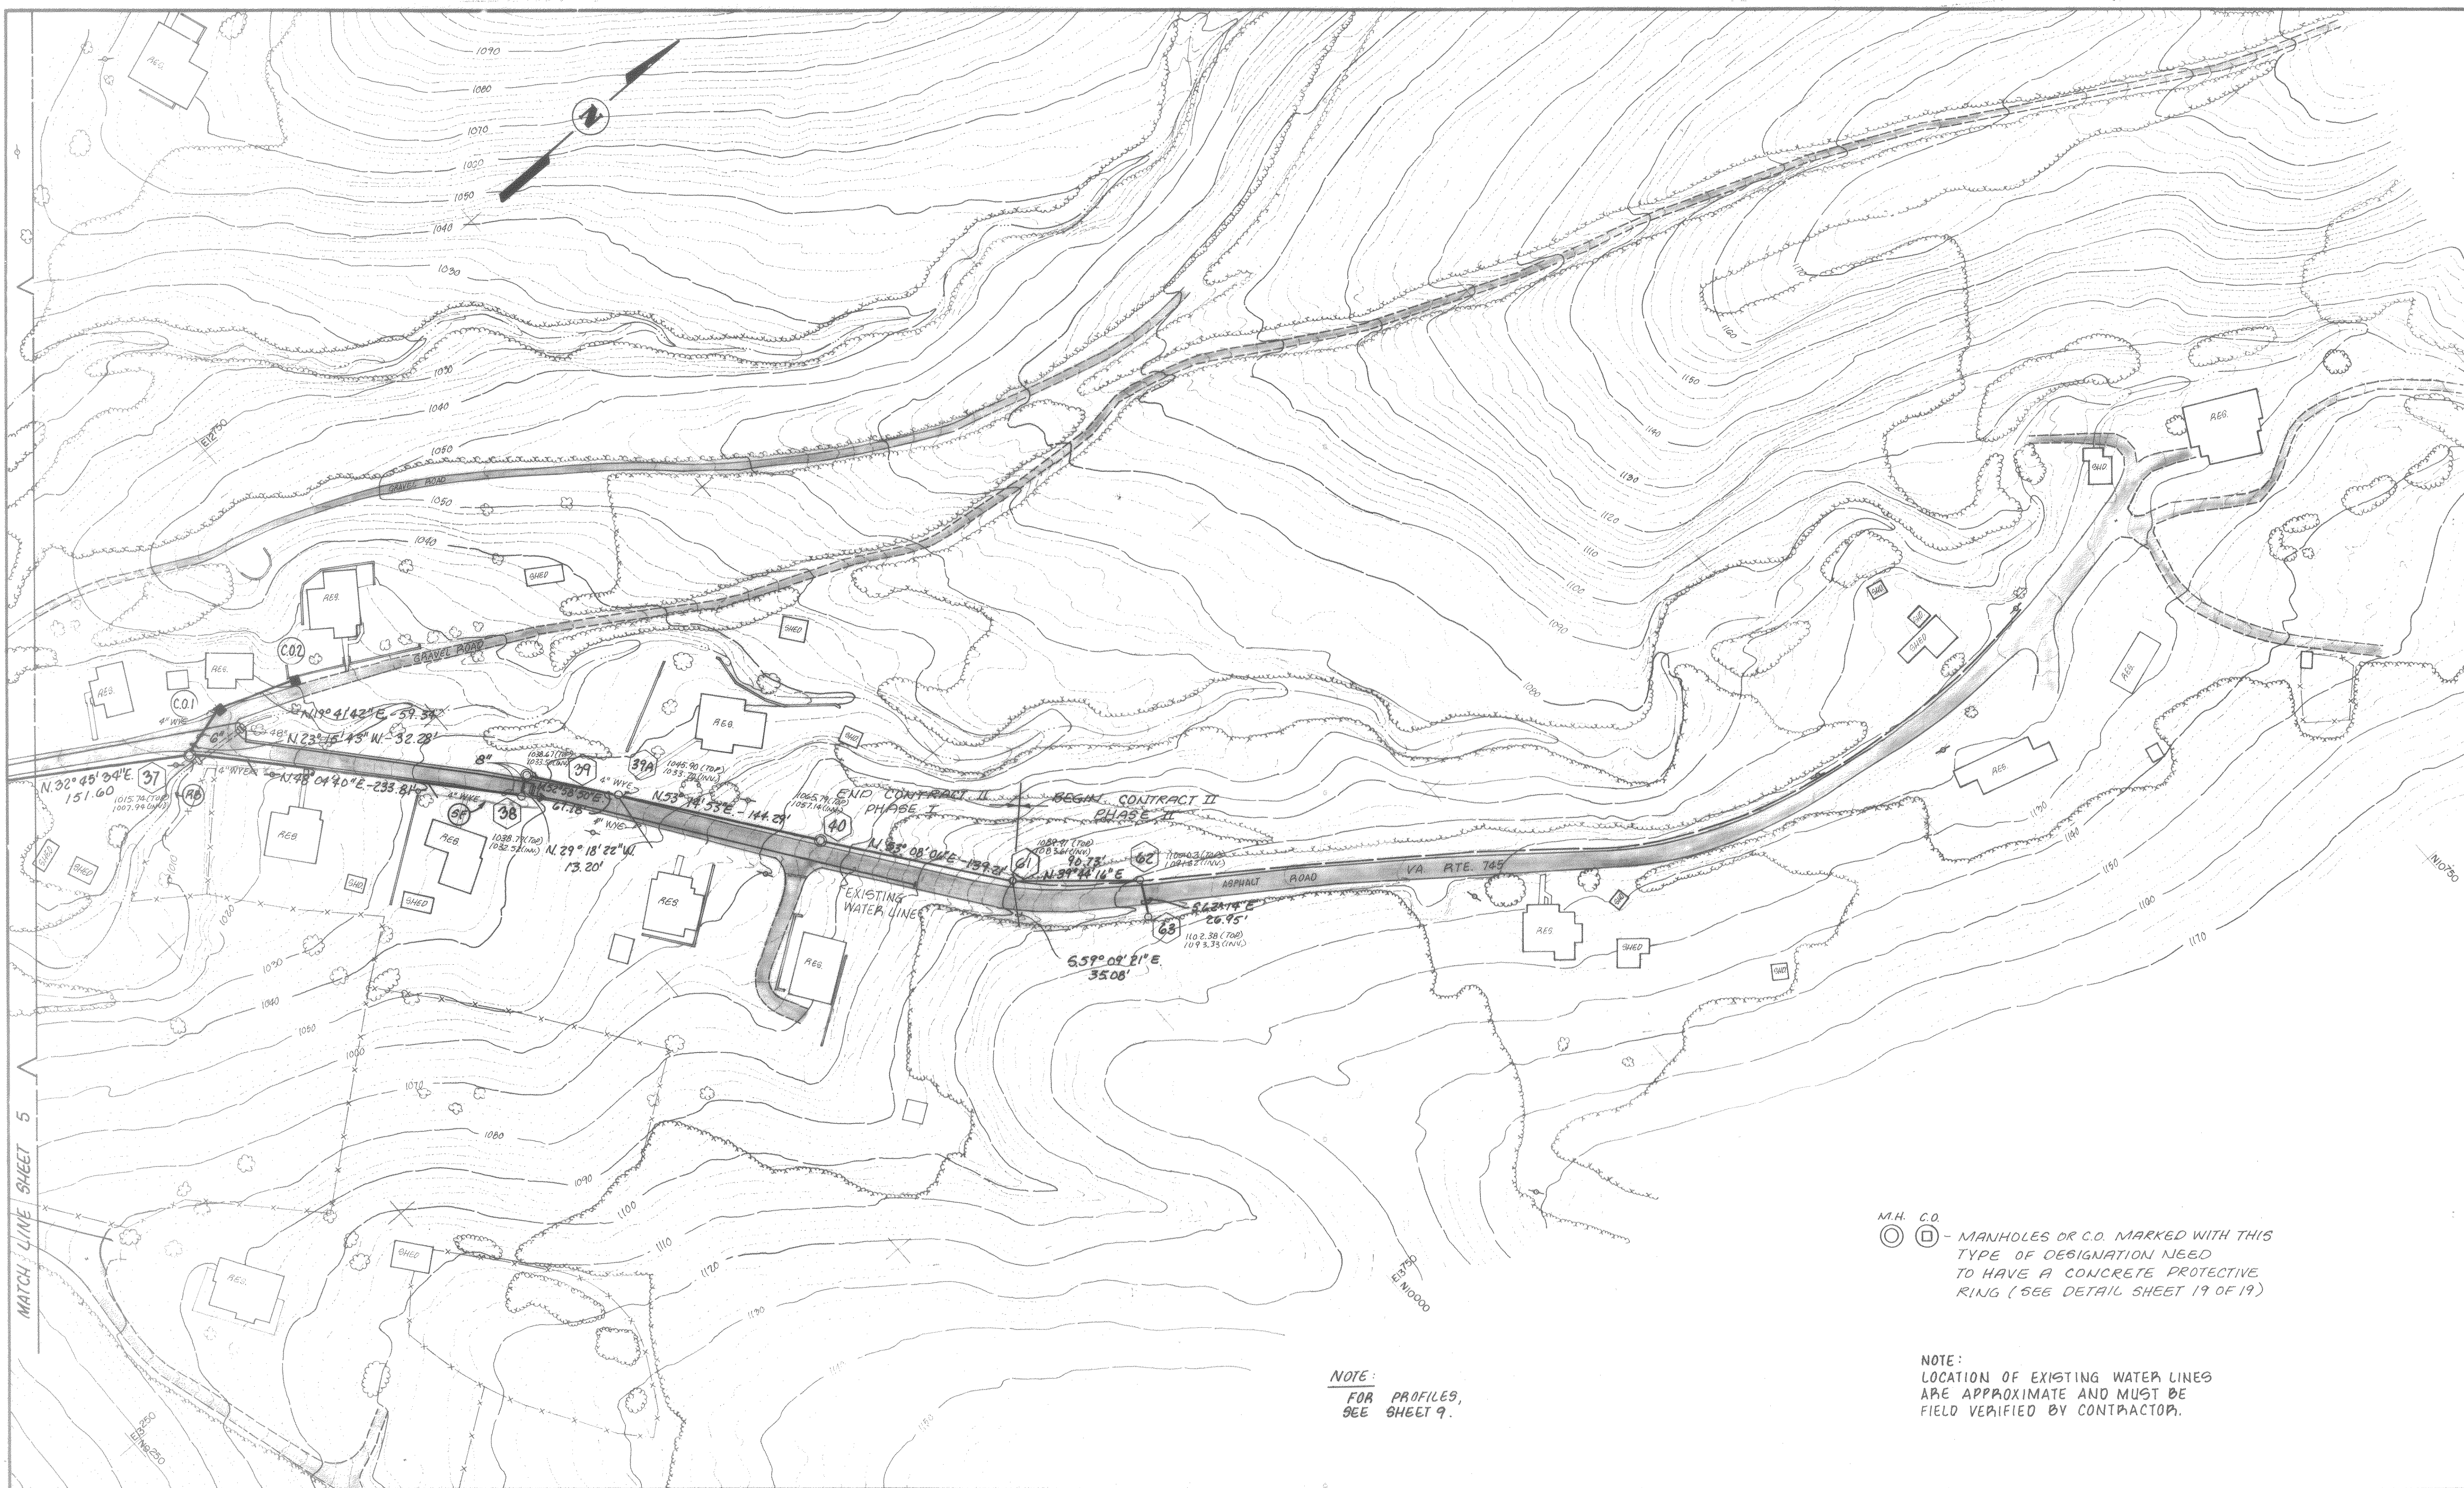




M.H. C.O.
 (C) (O) - MANHOLES OR C.O. MARKED WITH THIS TYPE OF DESIGNATION NEED TO HAVE A CONCRETE PROTECTIVE RING (SEE DETAIL SHEET 19 OF 19)



NOTE:
 FOR PROFILES,
 SEE SHEET 9.

NOTE:
 LOCATION OF EXISTING WATER LINES
 ARE APPROXIMATE AND MUST BE
 FIELD VERIFIED BY CONTRACTOR.

Designed: WGP Drafted: JRM Checked: CCB Approved: JMD	Clean Water Engineers, Inc. Fincastle, Virginia	COMMUNITY OF EAGLE ROCK WASTEWATER COLLECTION AND TREATMENT SYSTEM BOTETOURT COUNTY, VIRGINIA CONTRACT II "AS BUILT"		Sheet: 6 of 19 Scale: 1"= 50' Date: DEC. 1987 Project: 86019
--	---	---	--	---

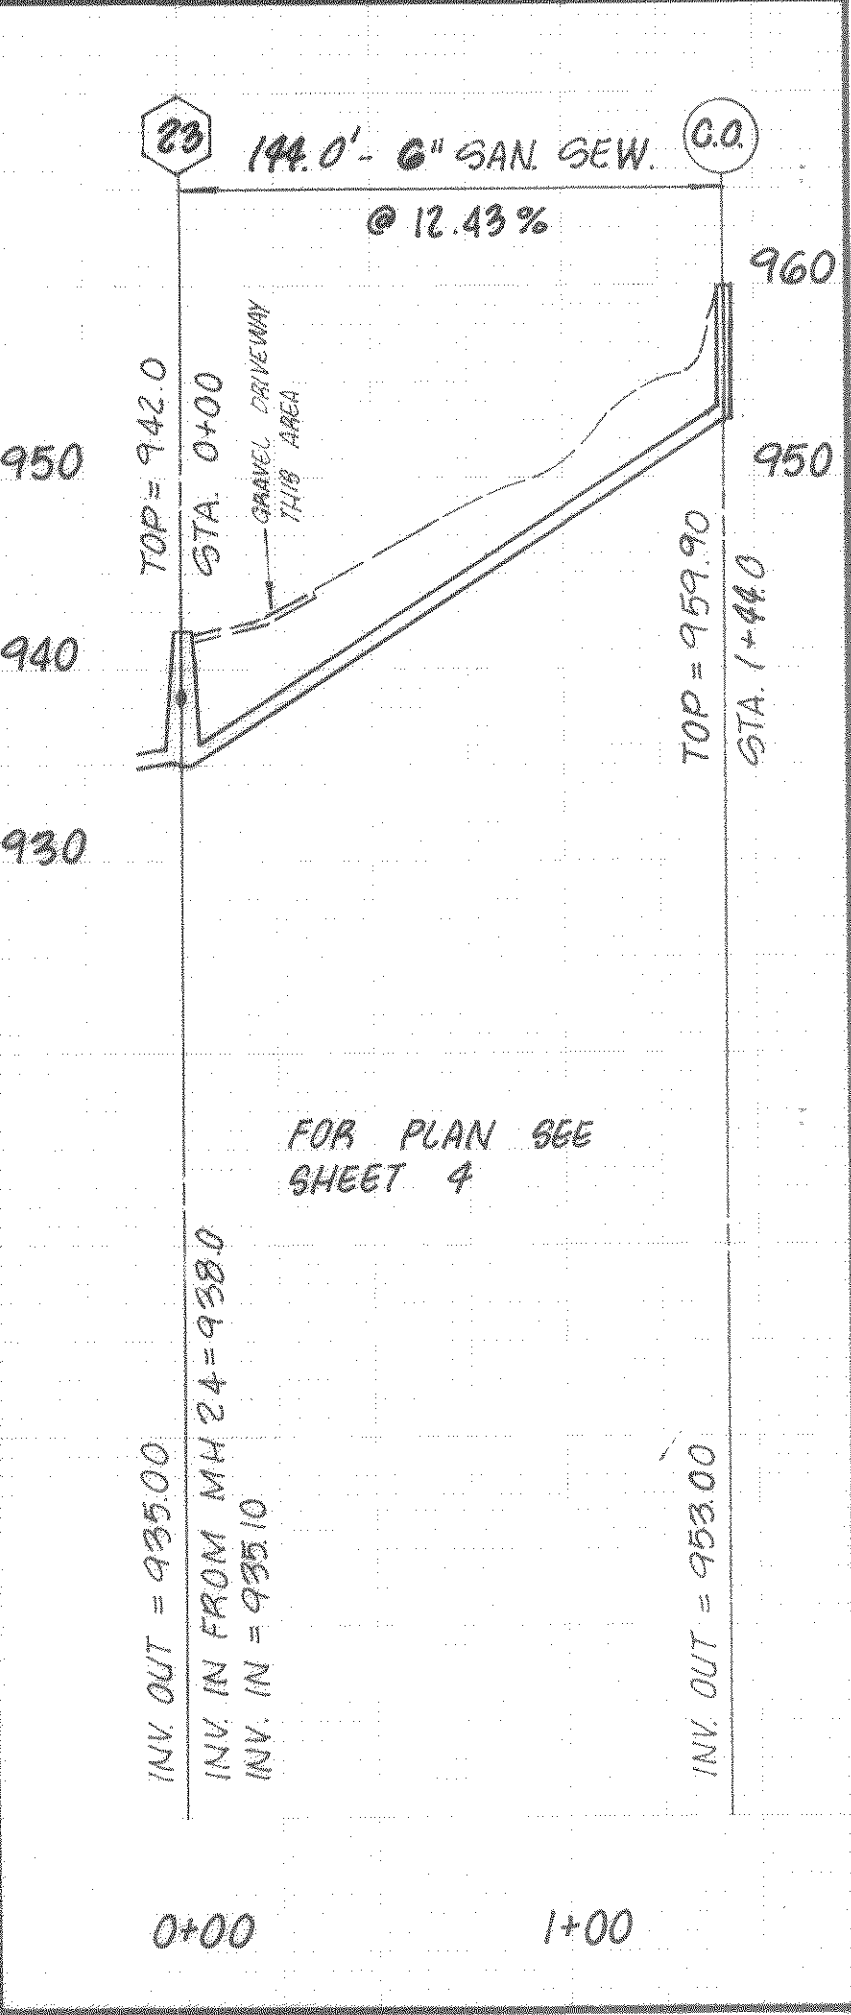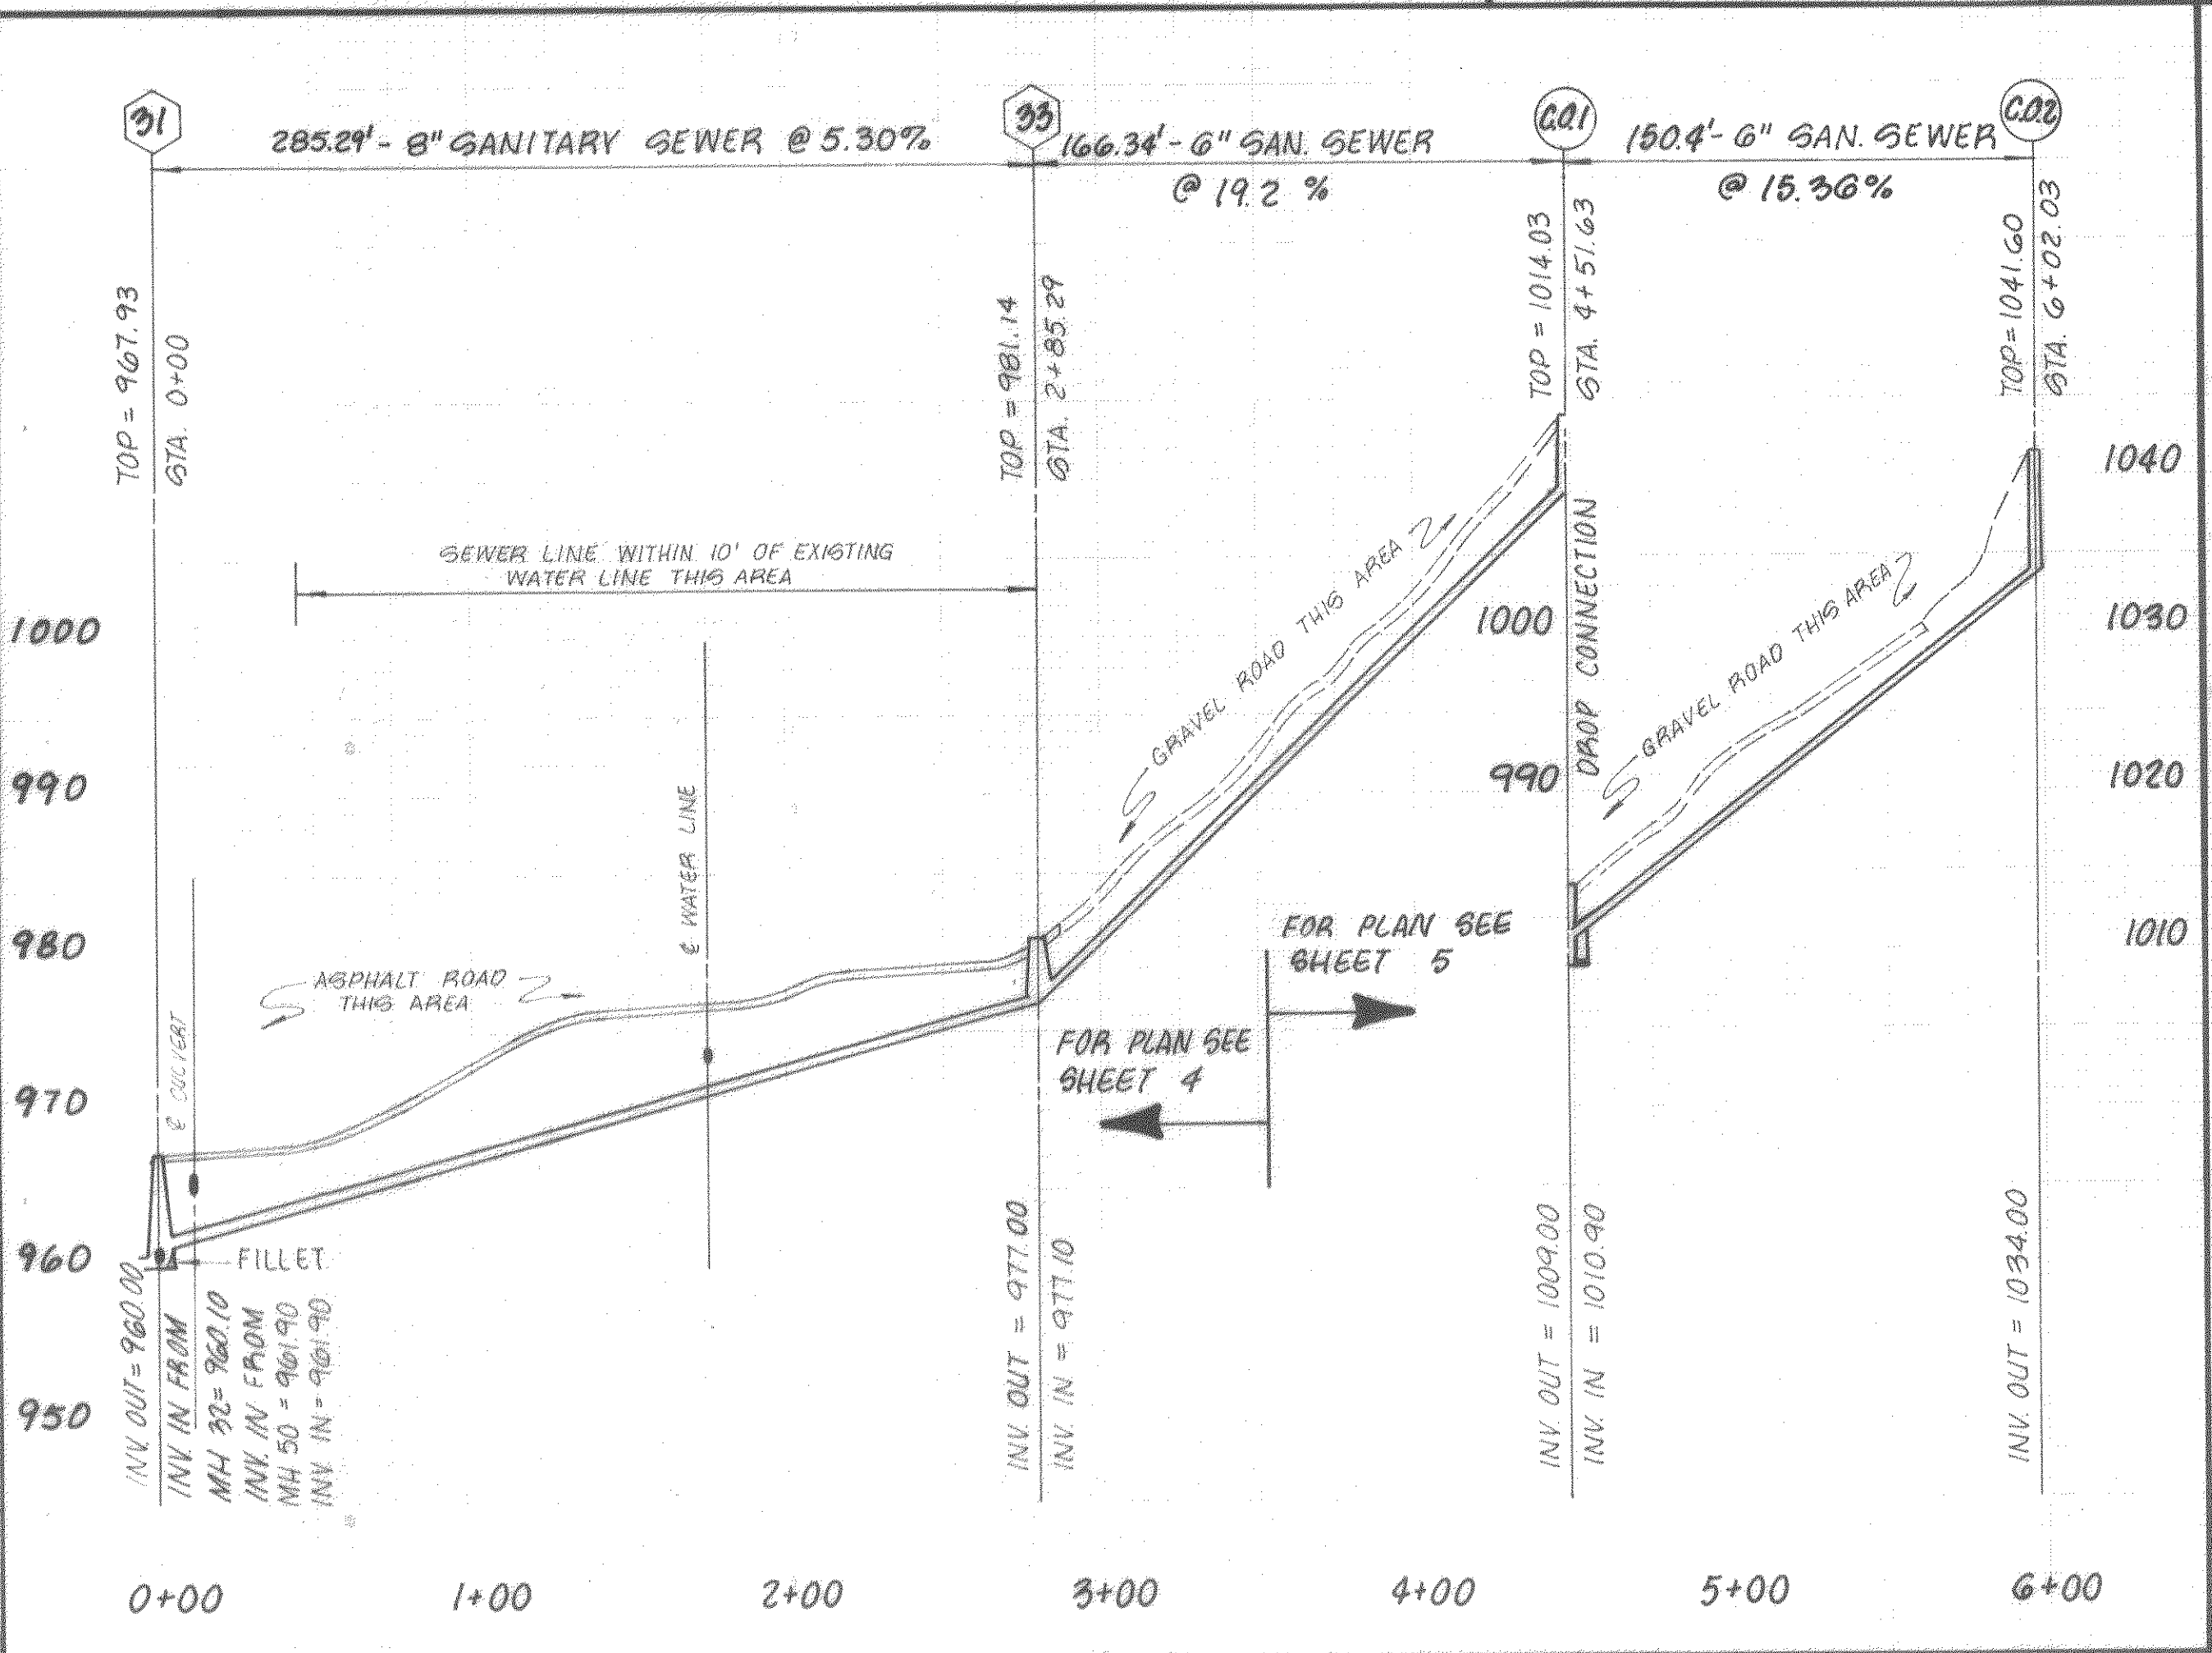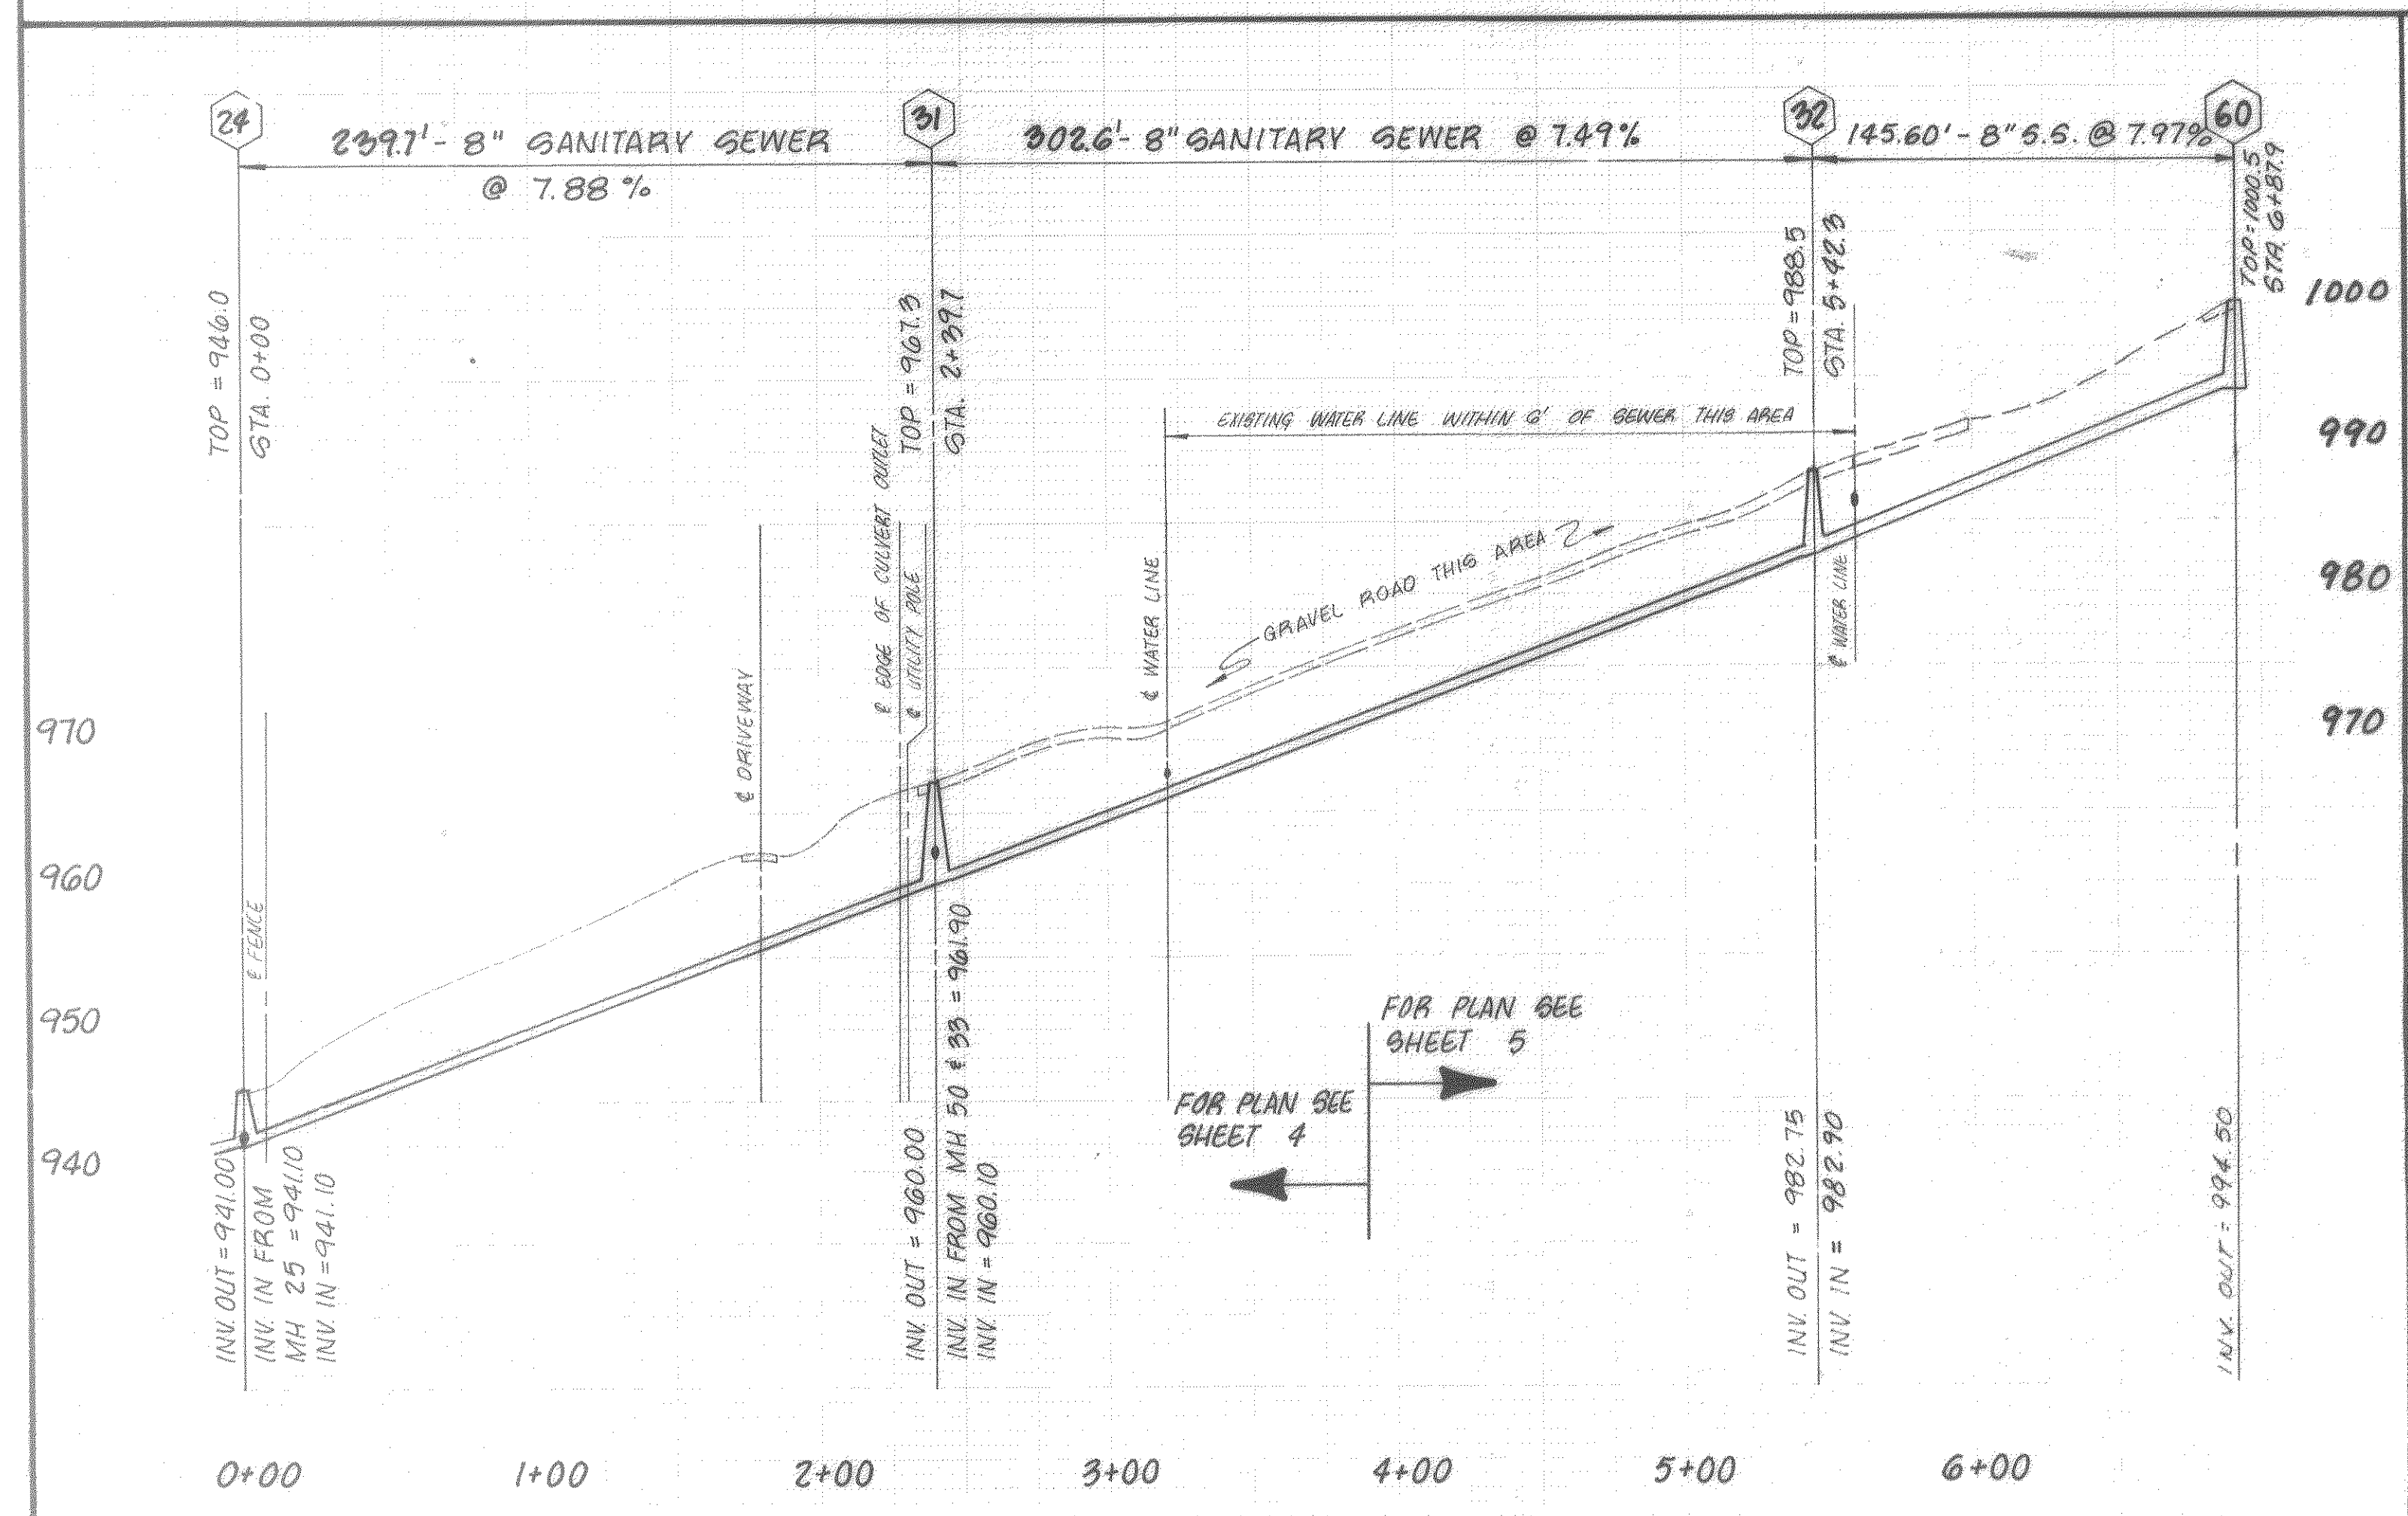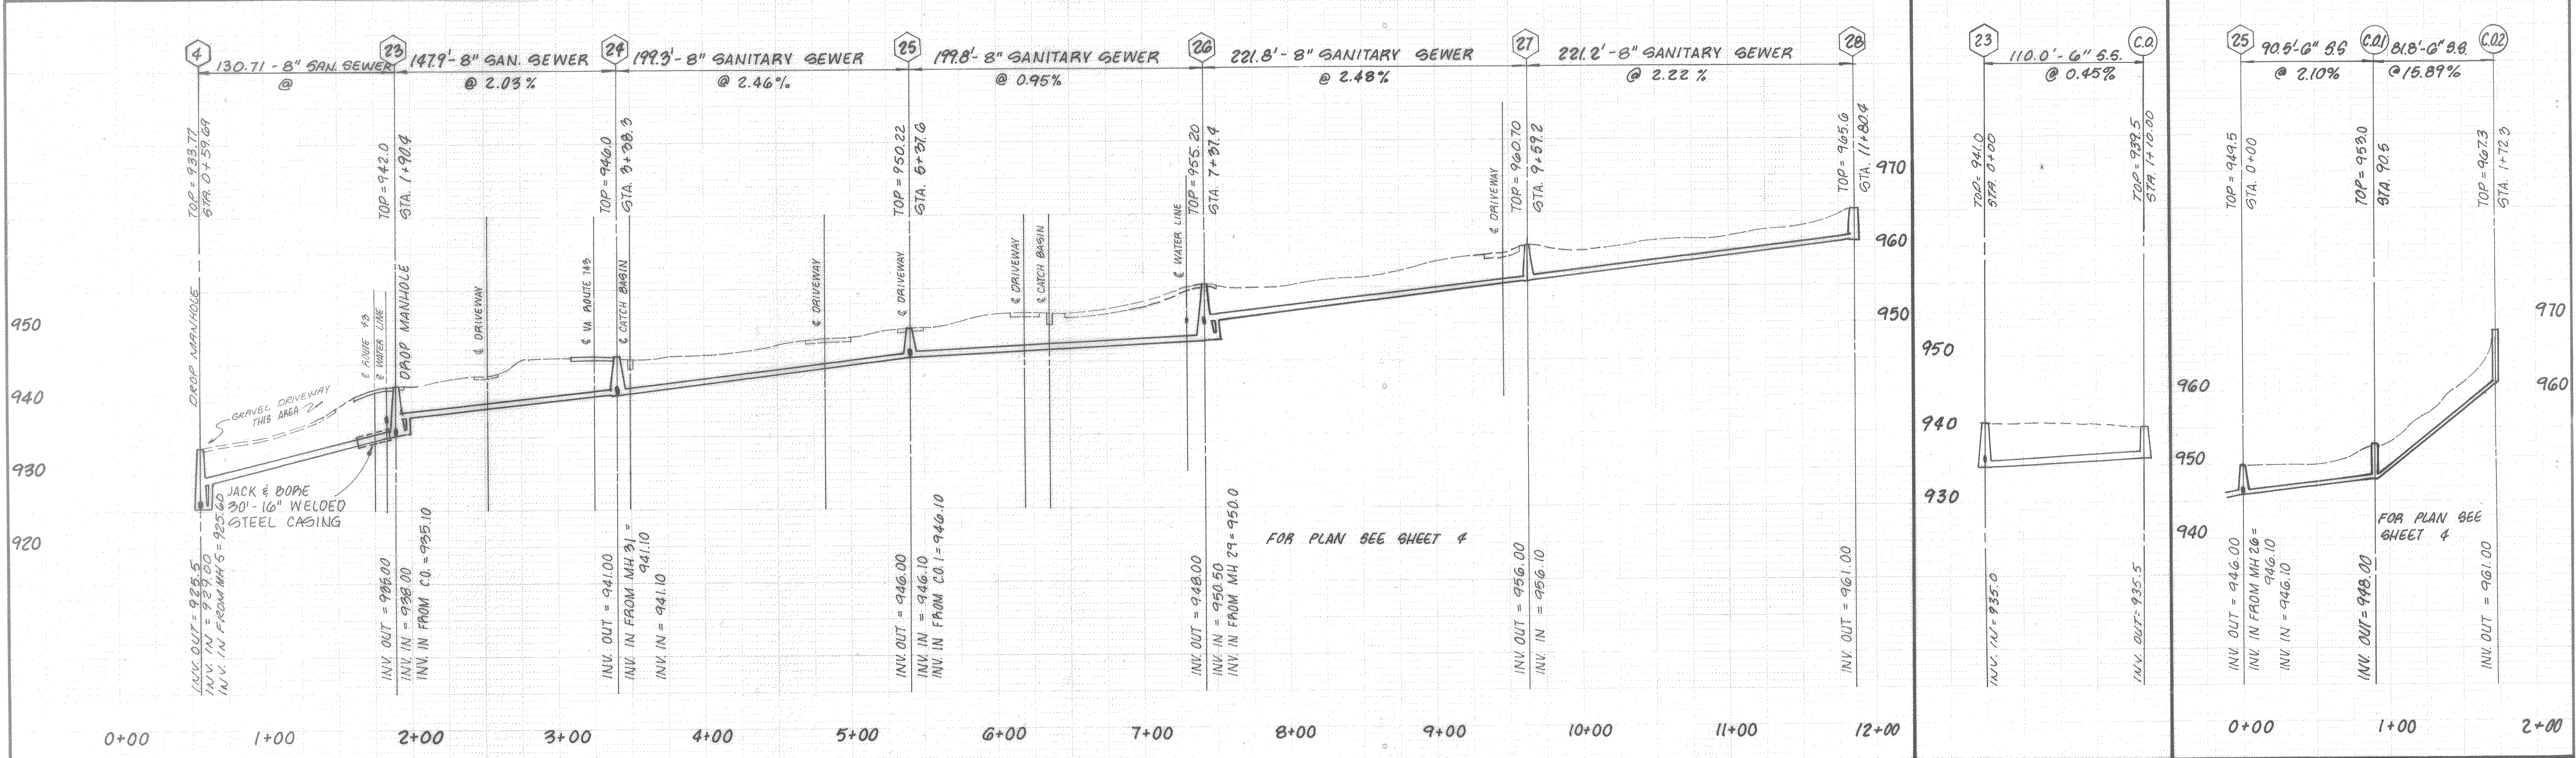

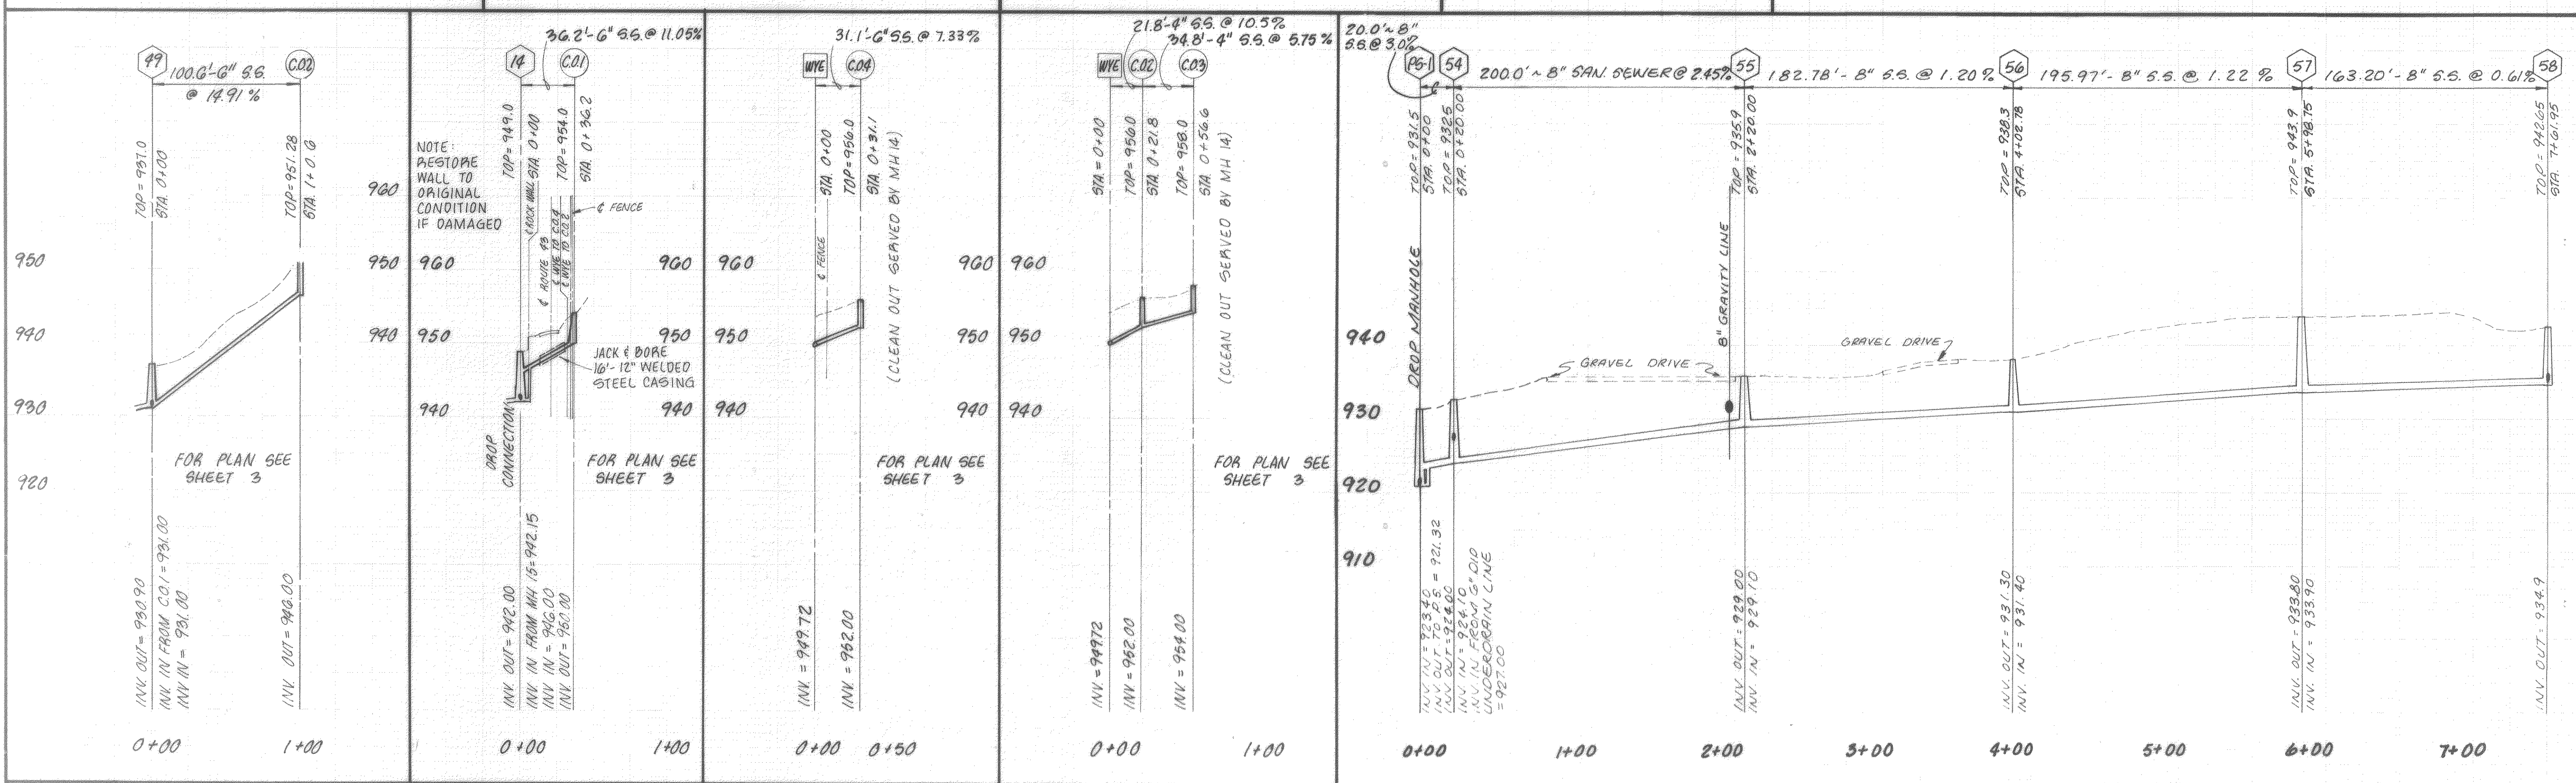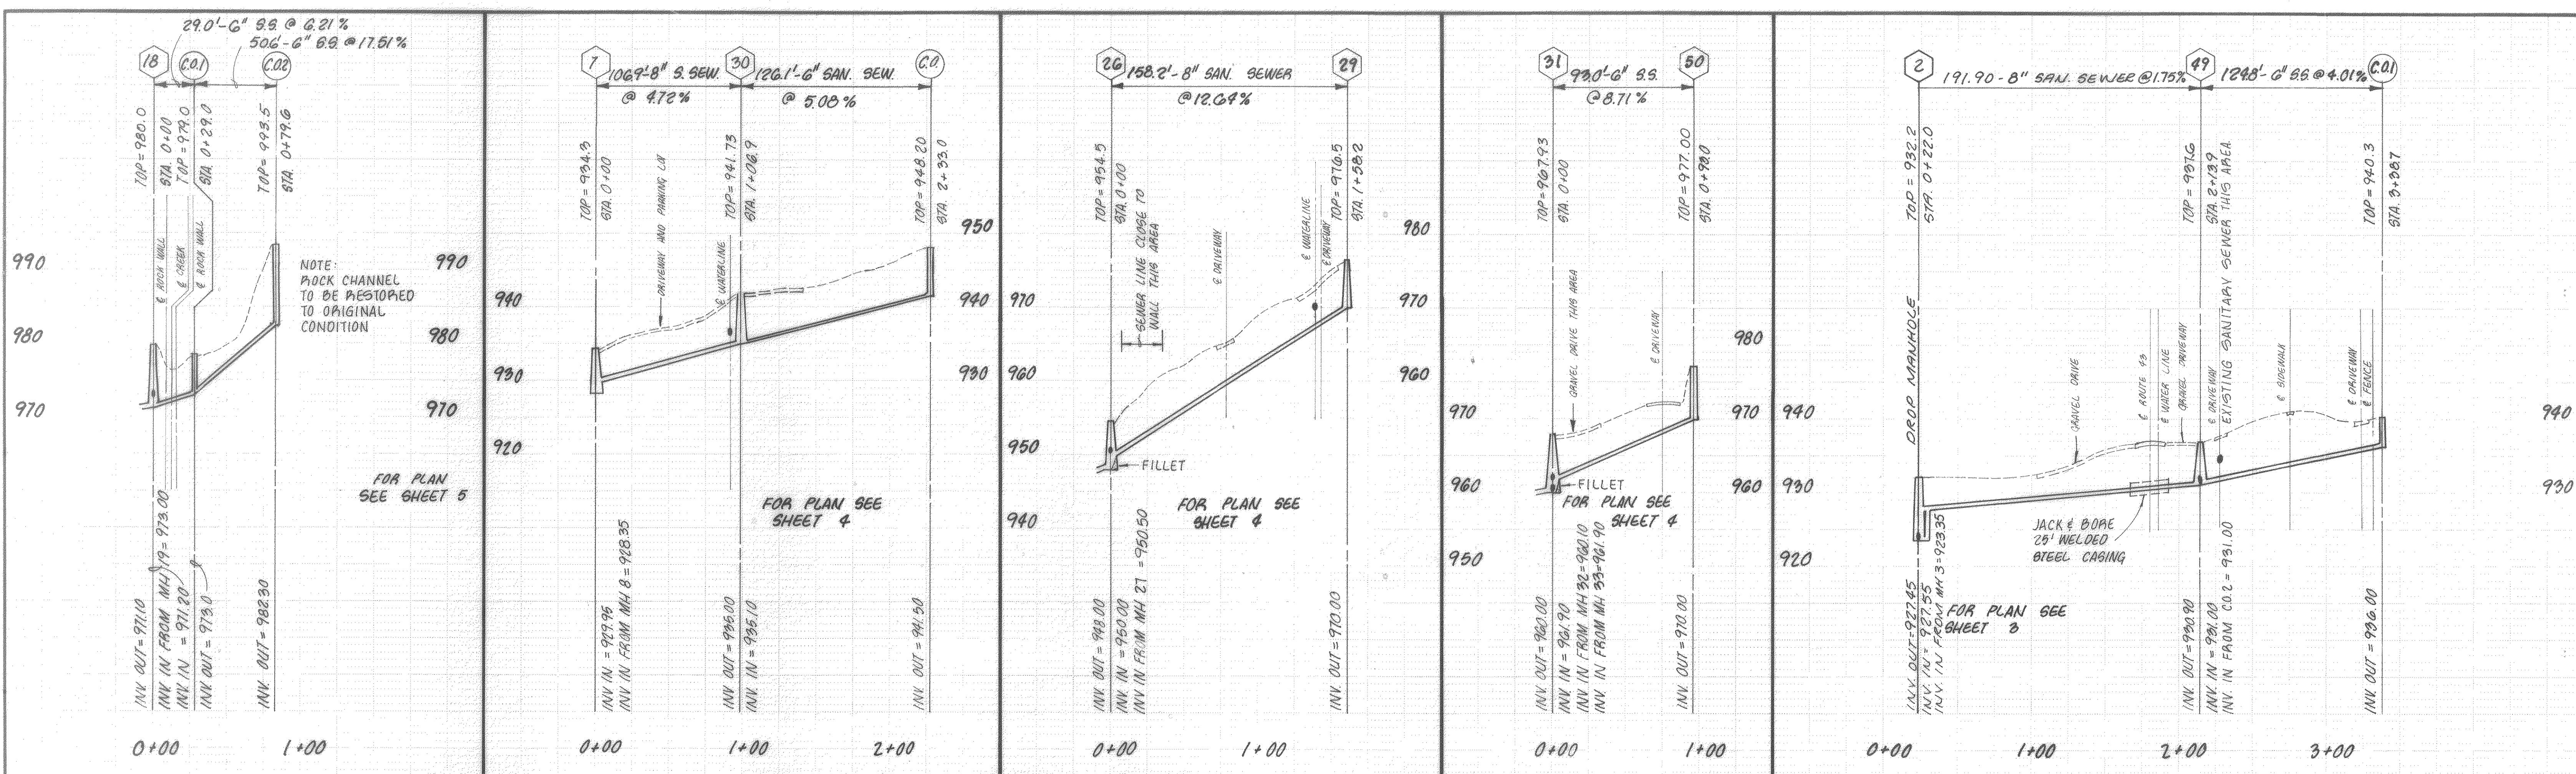

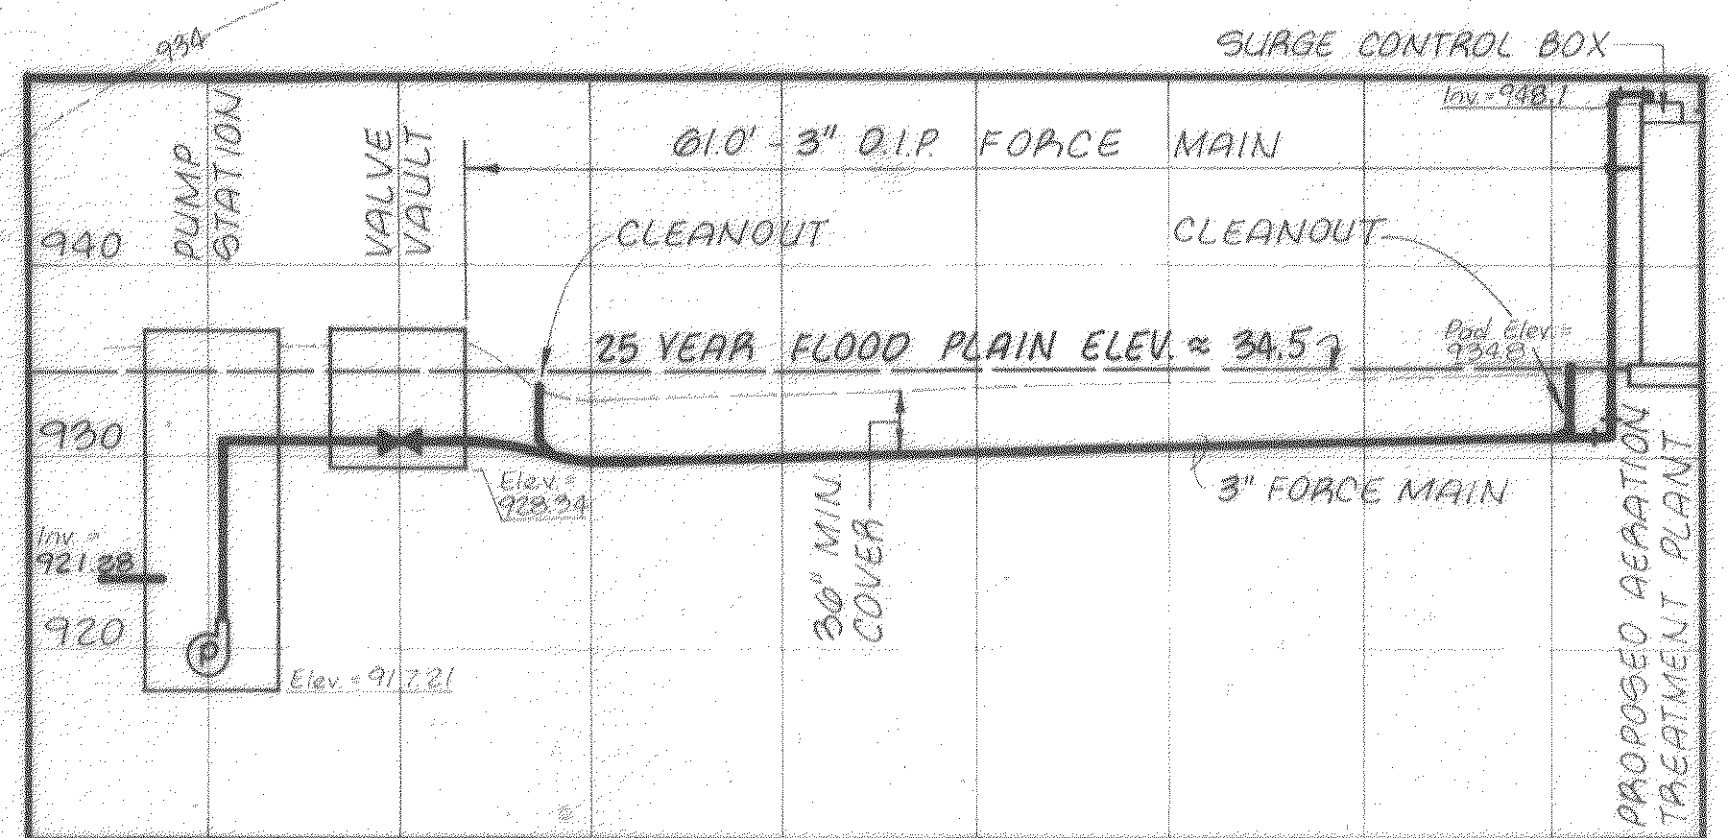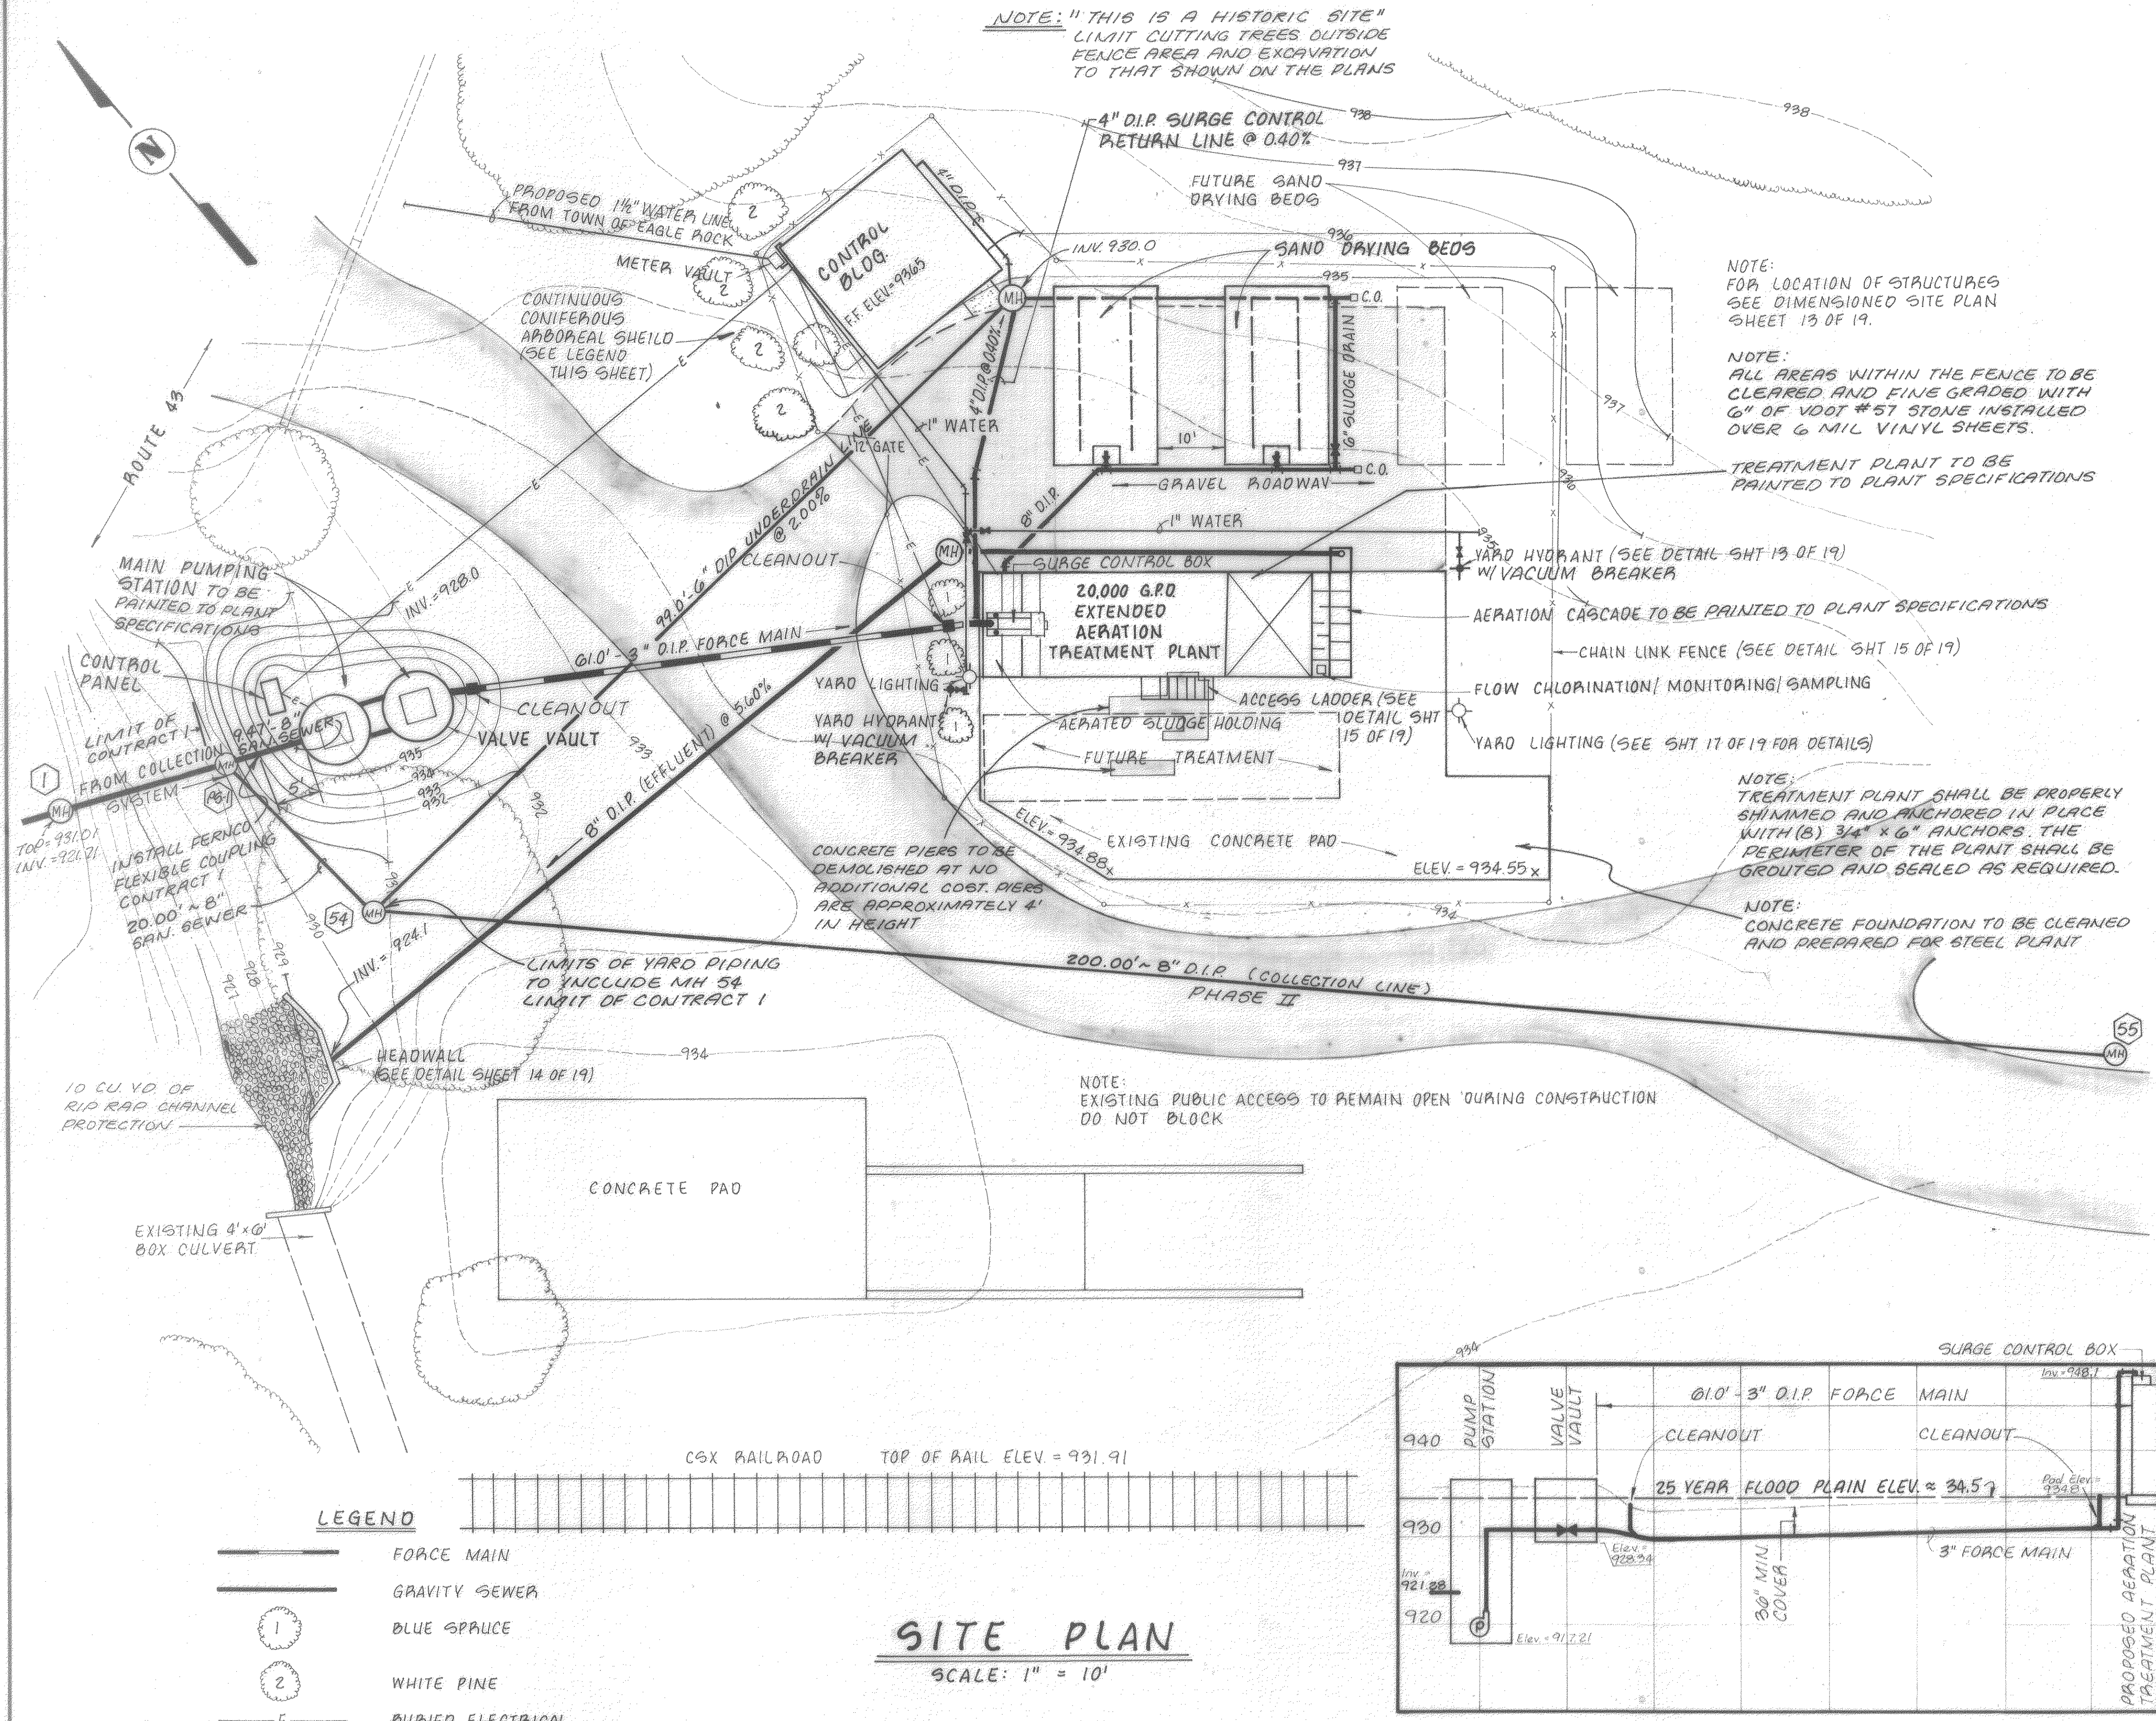

DESIGN CRITERIA

I. WASTEWATER CHARACTERISTICS:

Design Population	300 @ 65 gpcd
Design Flow	20,000 gpd
Biochemical Oxygen Demand	225 mg/l
Total Suspended Solids	225 mg/l
100 Year Flood Elevation	936'

II. DESIRED EFFLUENT QUALITY

Biochemical Oxygen Demand	30 mg/l
Total Suspended Solids	30 mg/l
Dissolved Oxygen	6.0 mg/l

III. TREATMENT COMPONENTS

Wastewater:	Sludge Handling:
Manual Bar Screen	Aerated Holding/Digester
Extended Aeration	Sand Drying Beds
Clarification	Landfill Disposal
Chlorination	
Flow Measurement	
Cascade Aeration	
Discharge to Stream	

IV. TREATMENT PROCESS UNIT DESCRIPTIONS

Aeration Tank:

Length	24.6 ft
Diameter	12.0 ft
Depth	11.0 ft
Total Volume	2673 ft ³ or 20,000 gals
Detention Time	24 hrs
Organic Loading	14 lbs BOD/1000 ft ³
Air requirements	@ 2100 ft ³ /lb BOD 78,800 ft ³ /day = 54.7 cfm
Air Supplied by two (2) rotary blowers	@ 70 cfm each

Final Clarifier (Hopper Bottomed)

Length	10.0 ft
Width	10.0 ft
Depth	11.0 ft
Total Volume	524 ft ³ or 3,950 gals
Detention Time	4.75 hrs
Surface loading rate	200 gal/ft ²
Weir Overflow rate	2,000 gal/ft

Disinfection:

Chlorine Contact Basin	
Length	10 ft
Width	2 ft
Depth	4 ft
Total Volume	80 ft ³ or 600 gals
Detention Time	43 min @ 20,000
	21.5 min @ 40,000

Flow Measurement (Instantaneous):

V-Notch Weir w/ Staff Gauge	
Aeration Cascade	
Length	14.5 ft
Width	1.0 ft
Step Height	6.0 in
Elevation Differential	10 ft

Steps Required:


Deficit Ratio = $R = 140.11 AB (140.046T) H = N \sqrt{\frac{C's-CA}{C's-CB}}$

Where $C's=O_2$ Saturation at critical temperature and elevation = 7.63 mg/l; $A = 0.8$
 $B = 1.3$, $T = 28^\circ C$, $H = 6'$, $N = \#$ of steps, $CA=O_2$ conc. above steps
 By calculation $N=11$


VI. SLUDGE PRODUCTION AND HANDLING

Production	@ 0.35 lbs Sludge Produced/lb BOD Removed
	11.4 lbs/day = 4101 lbs/year
Storage/Digestion	
Length	4 ft
Width	12 ft
Depth	11 ft
Total Volume	398 ft ³ or 2,980 gals
Storage Capacity	40 days
Sand Drying Beds (Duplex)	
Length	20 ft
Width	12 ft
Capacity	240 ft ³
Cycles	7.5/bed/year
Loading	8.7 lbs./ft ² /year



4-1-91

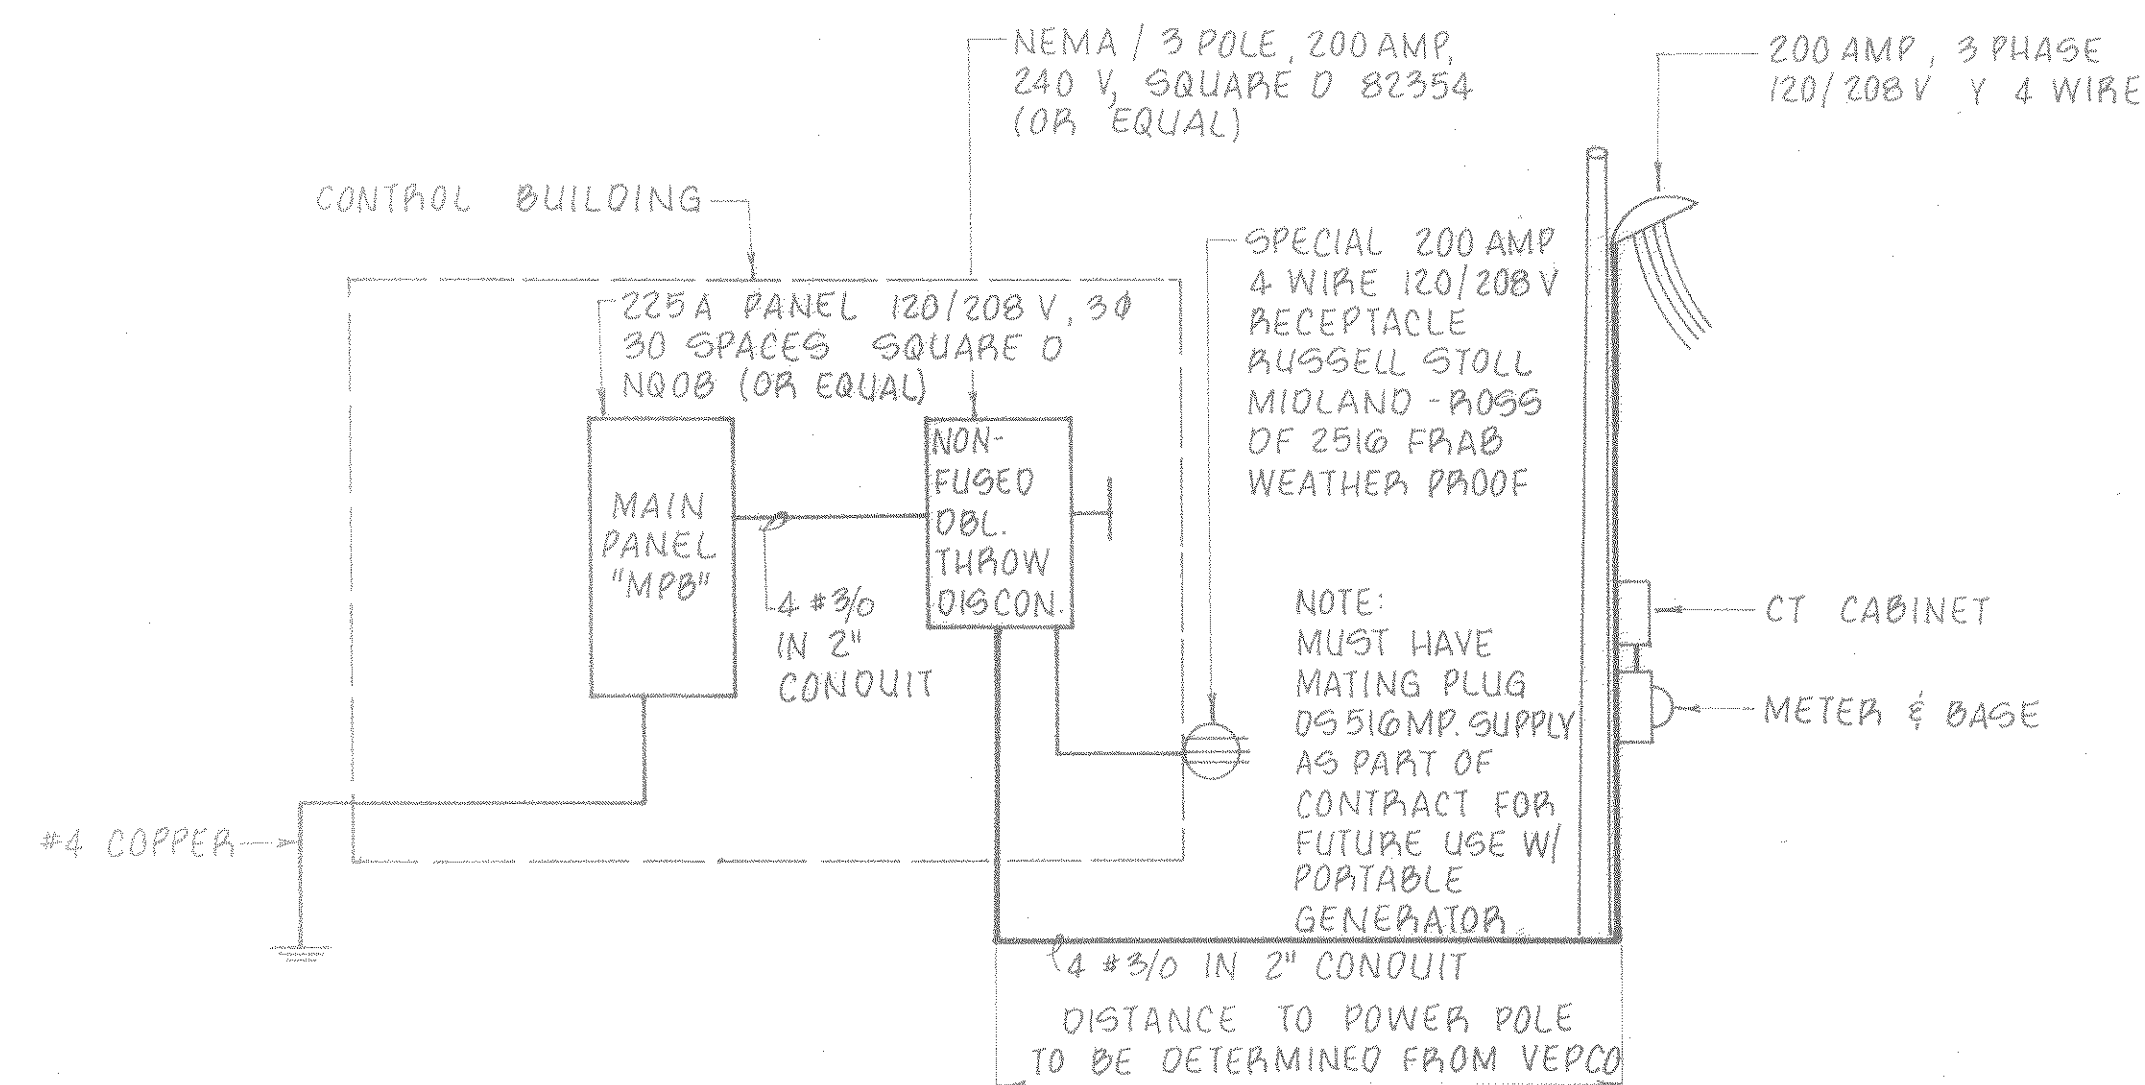

POWER RISER DIAGRAM
NO SCALE

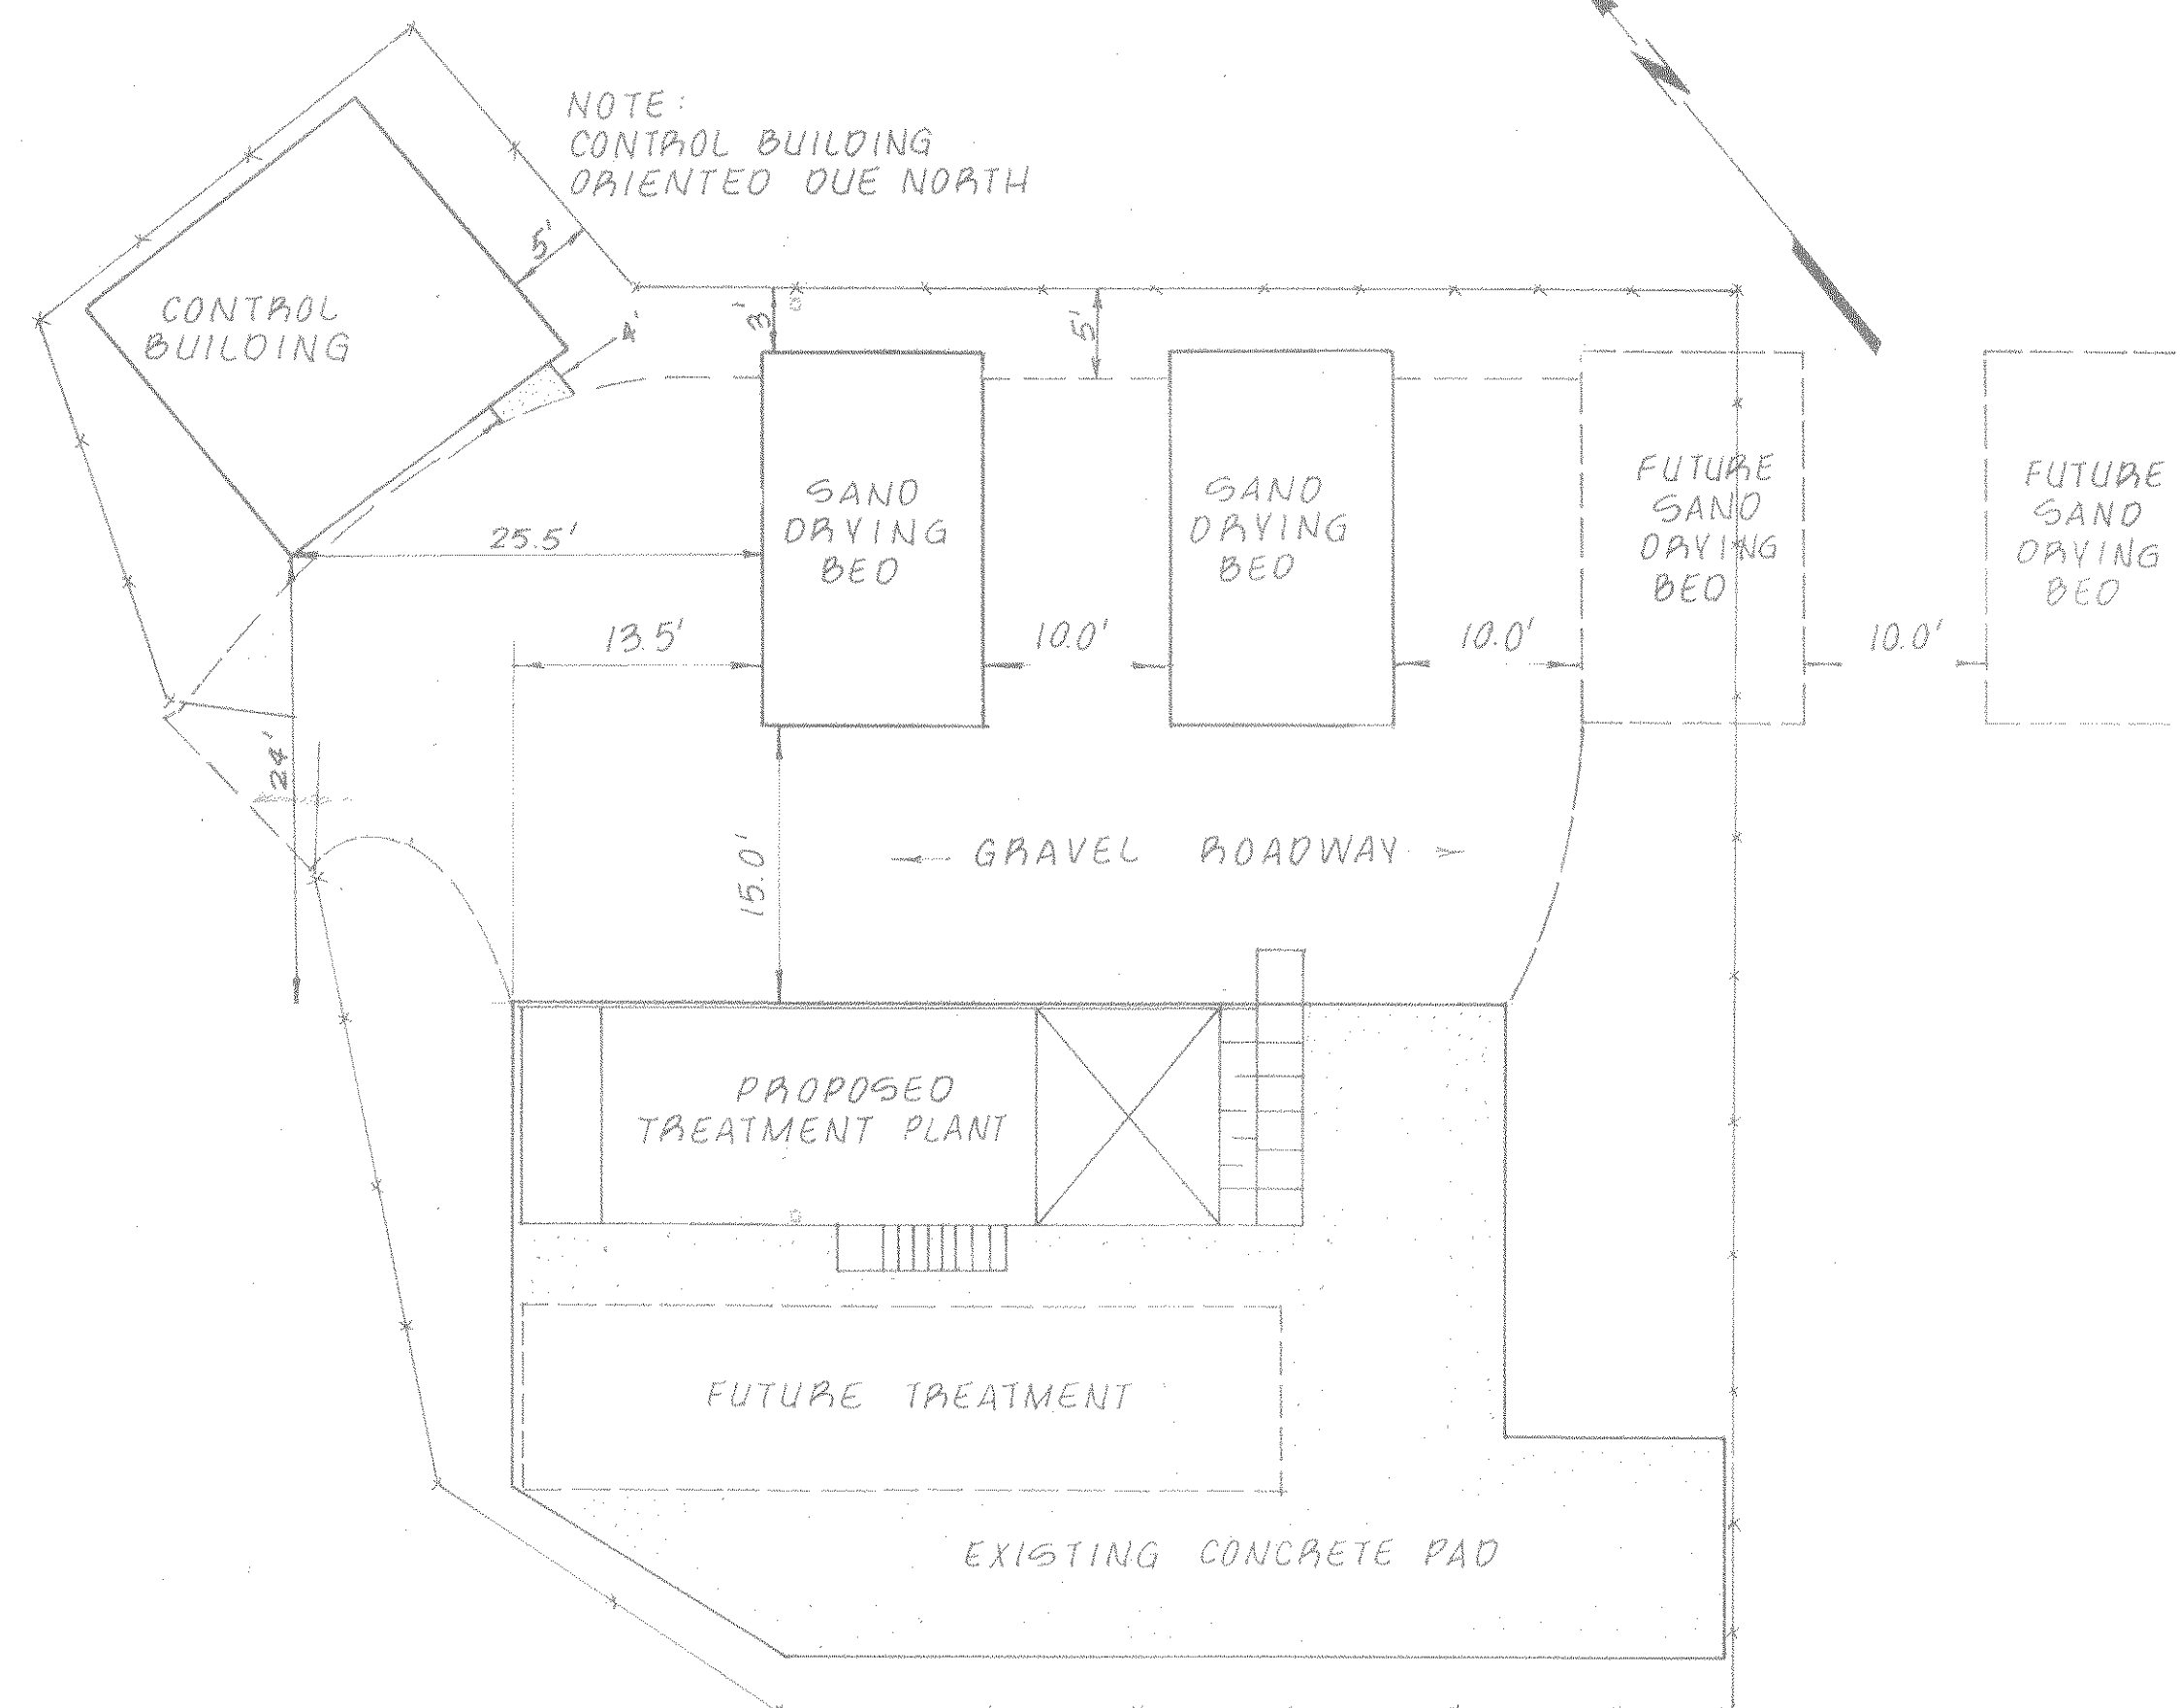


DIMENSIONED SITE PLAN
SCALE: 1" = 10'

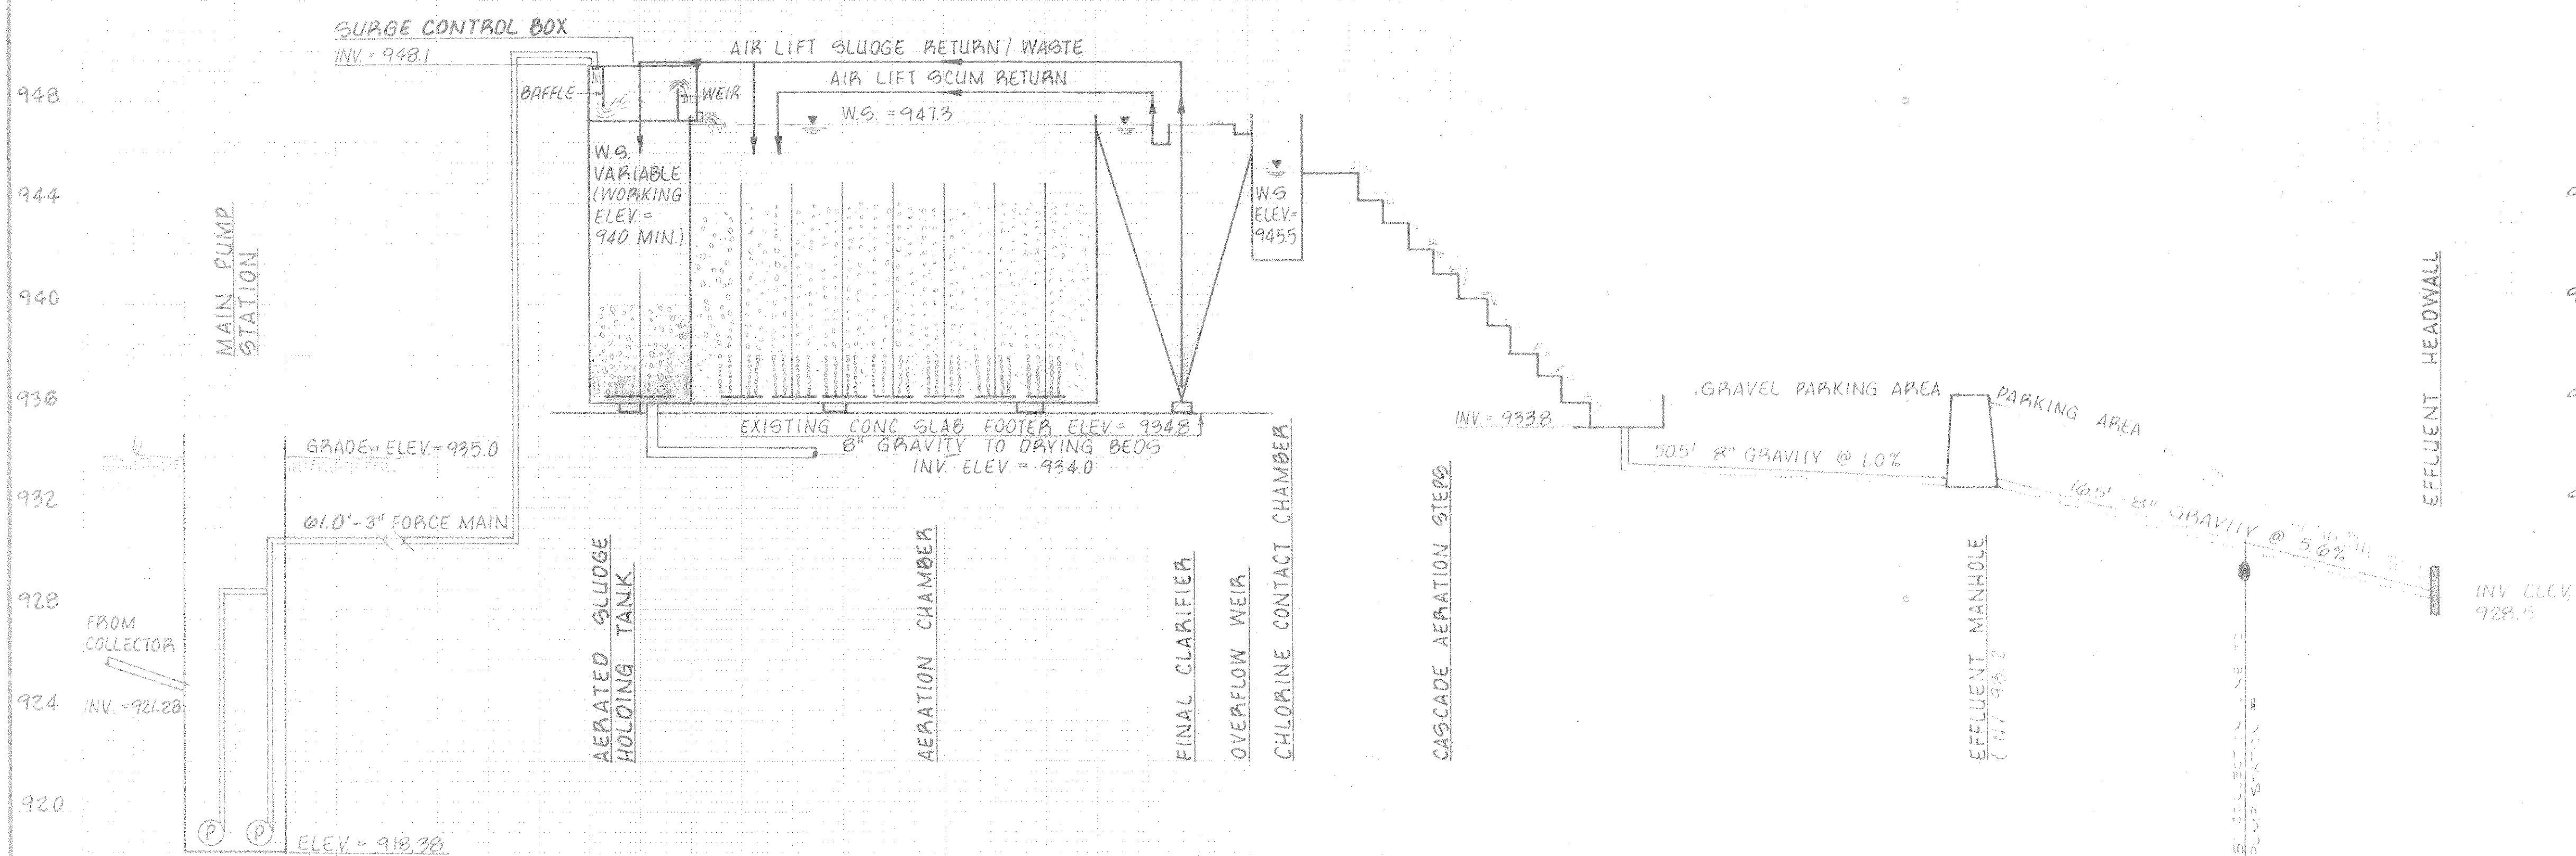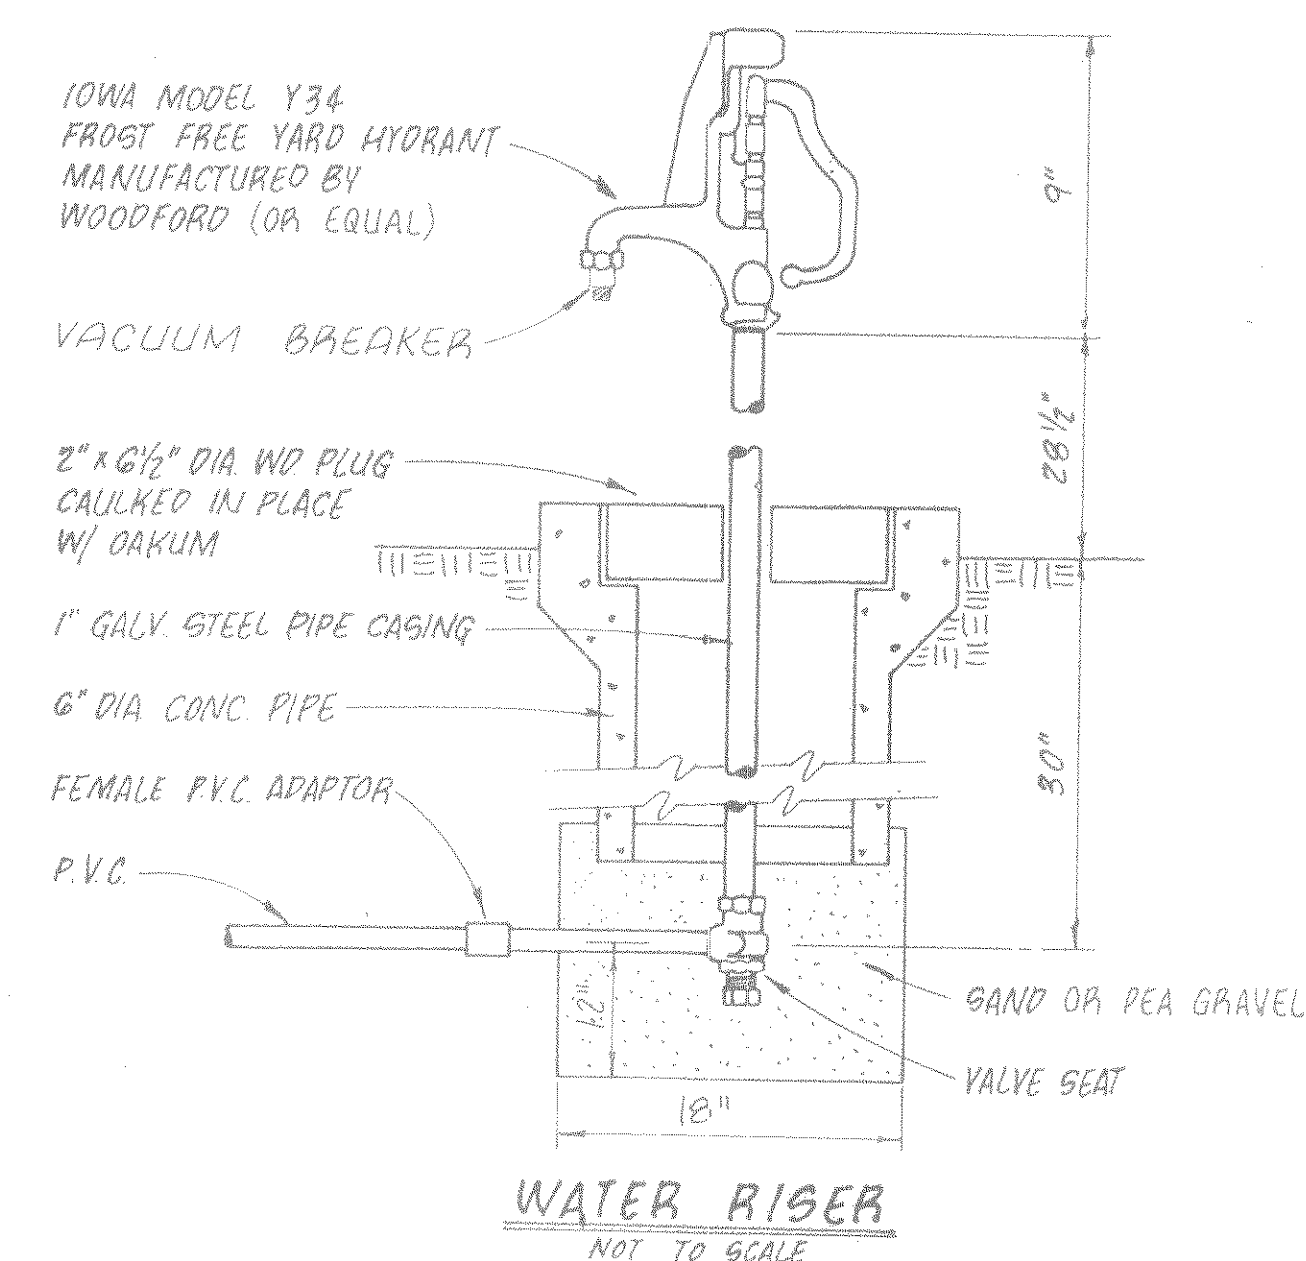

HYDRAULIC PROFILE

SCALE: HORIZ. - NTS
VERT. 1" = 4'-0"

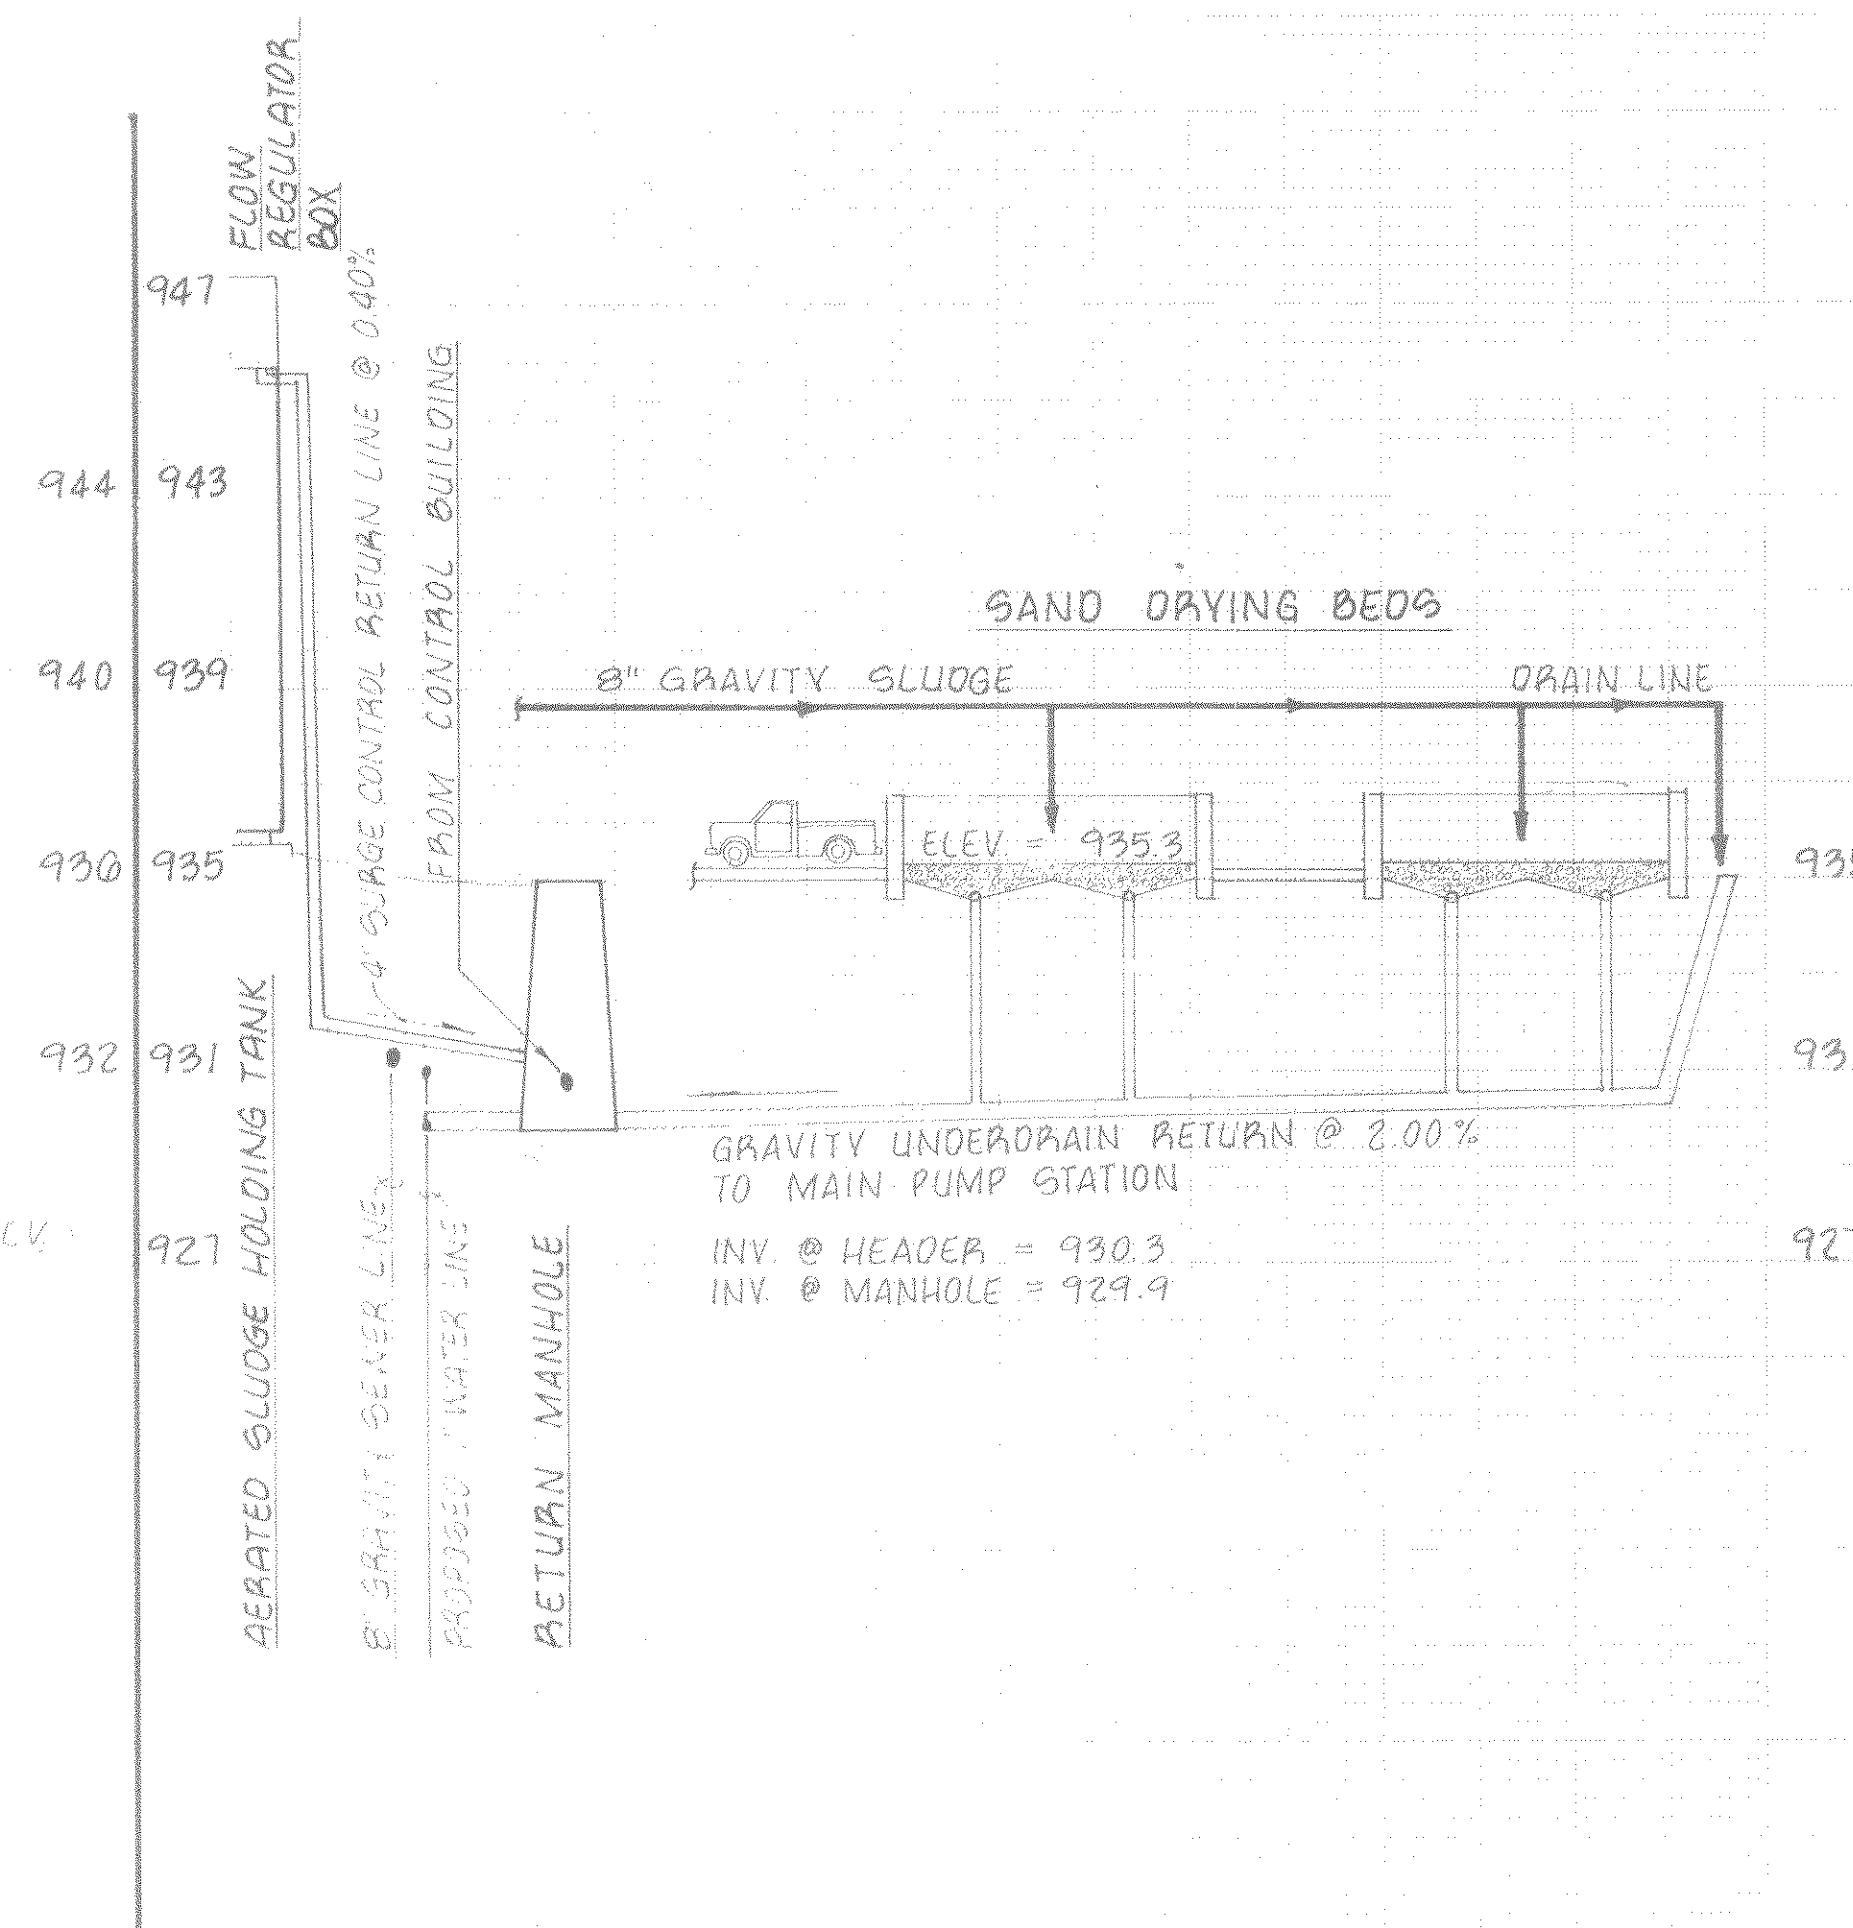

6-1-91 REV. FORCE MAIN SIZE (4" TO 3") TRAP

Designed: WGP
Drafted: TAM
Checked: CCB
Approved: JMD



Clean Water Engineers, Inc.
Fincastle, Virginia

COMMUNITY OF EAGLE ROCK
WASTEWATER COLLECTION AND TREATMENT SYSTEM
BOTETOURT COUNTY, VIRGINIA

CONTRACT I
"AS BUILT"

DAVID J. RIGBY
8169
REGISTERED PROFESSIONAL ENGINEER

Sheet: 13 of 19
Scale: AS SHOWN
Date: DEC. 1987
Project: 86019

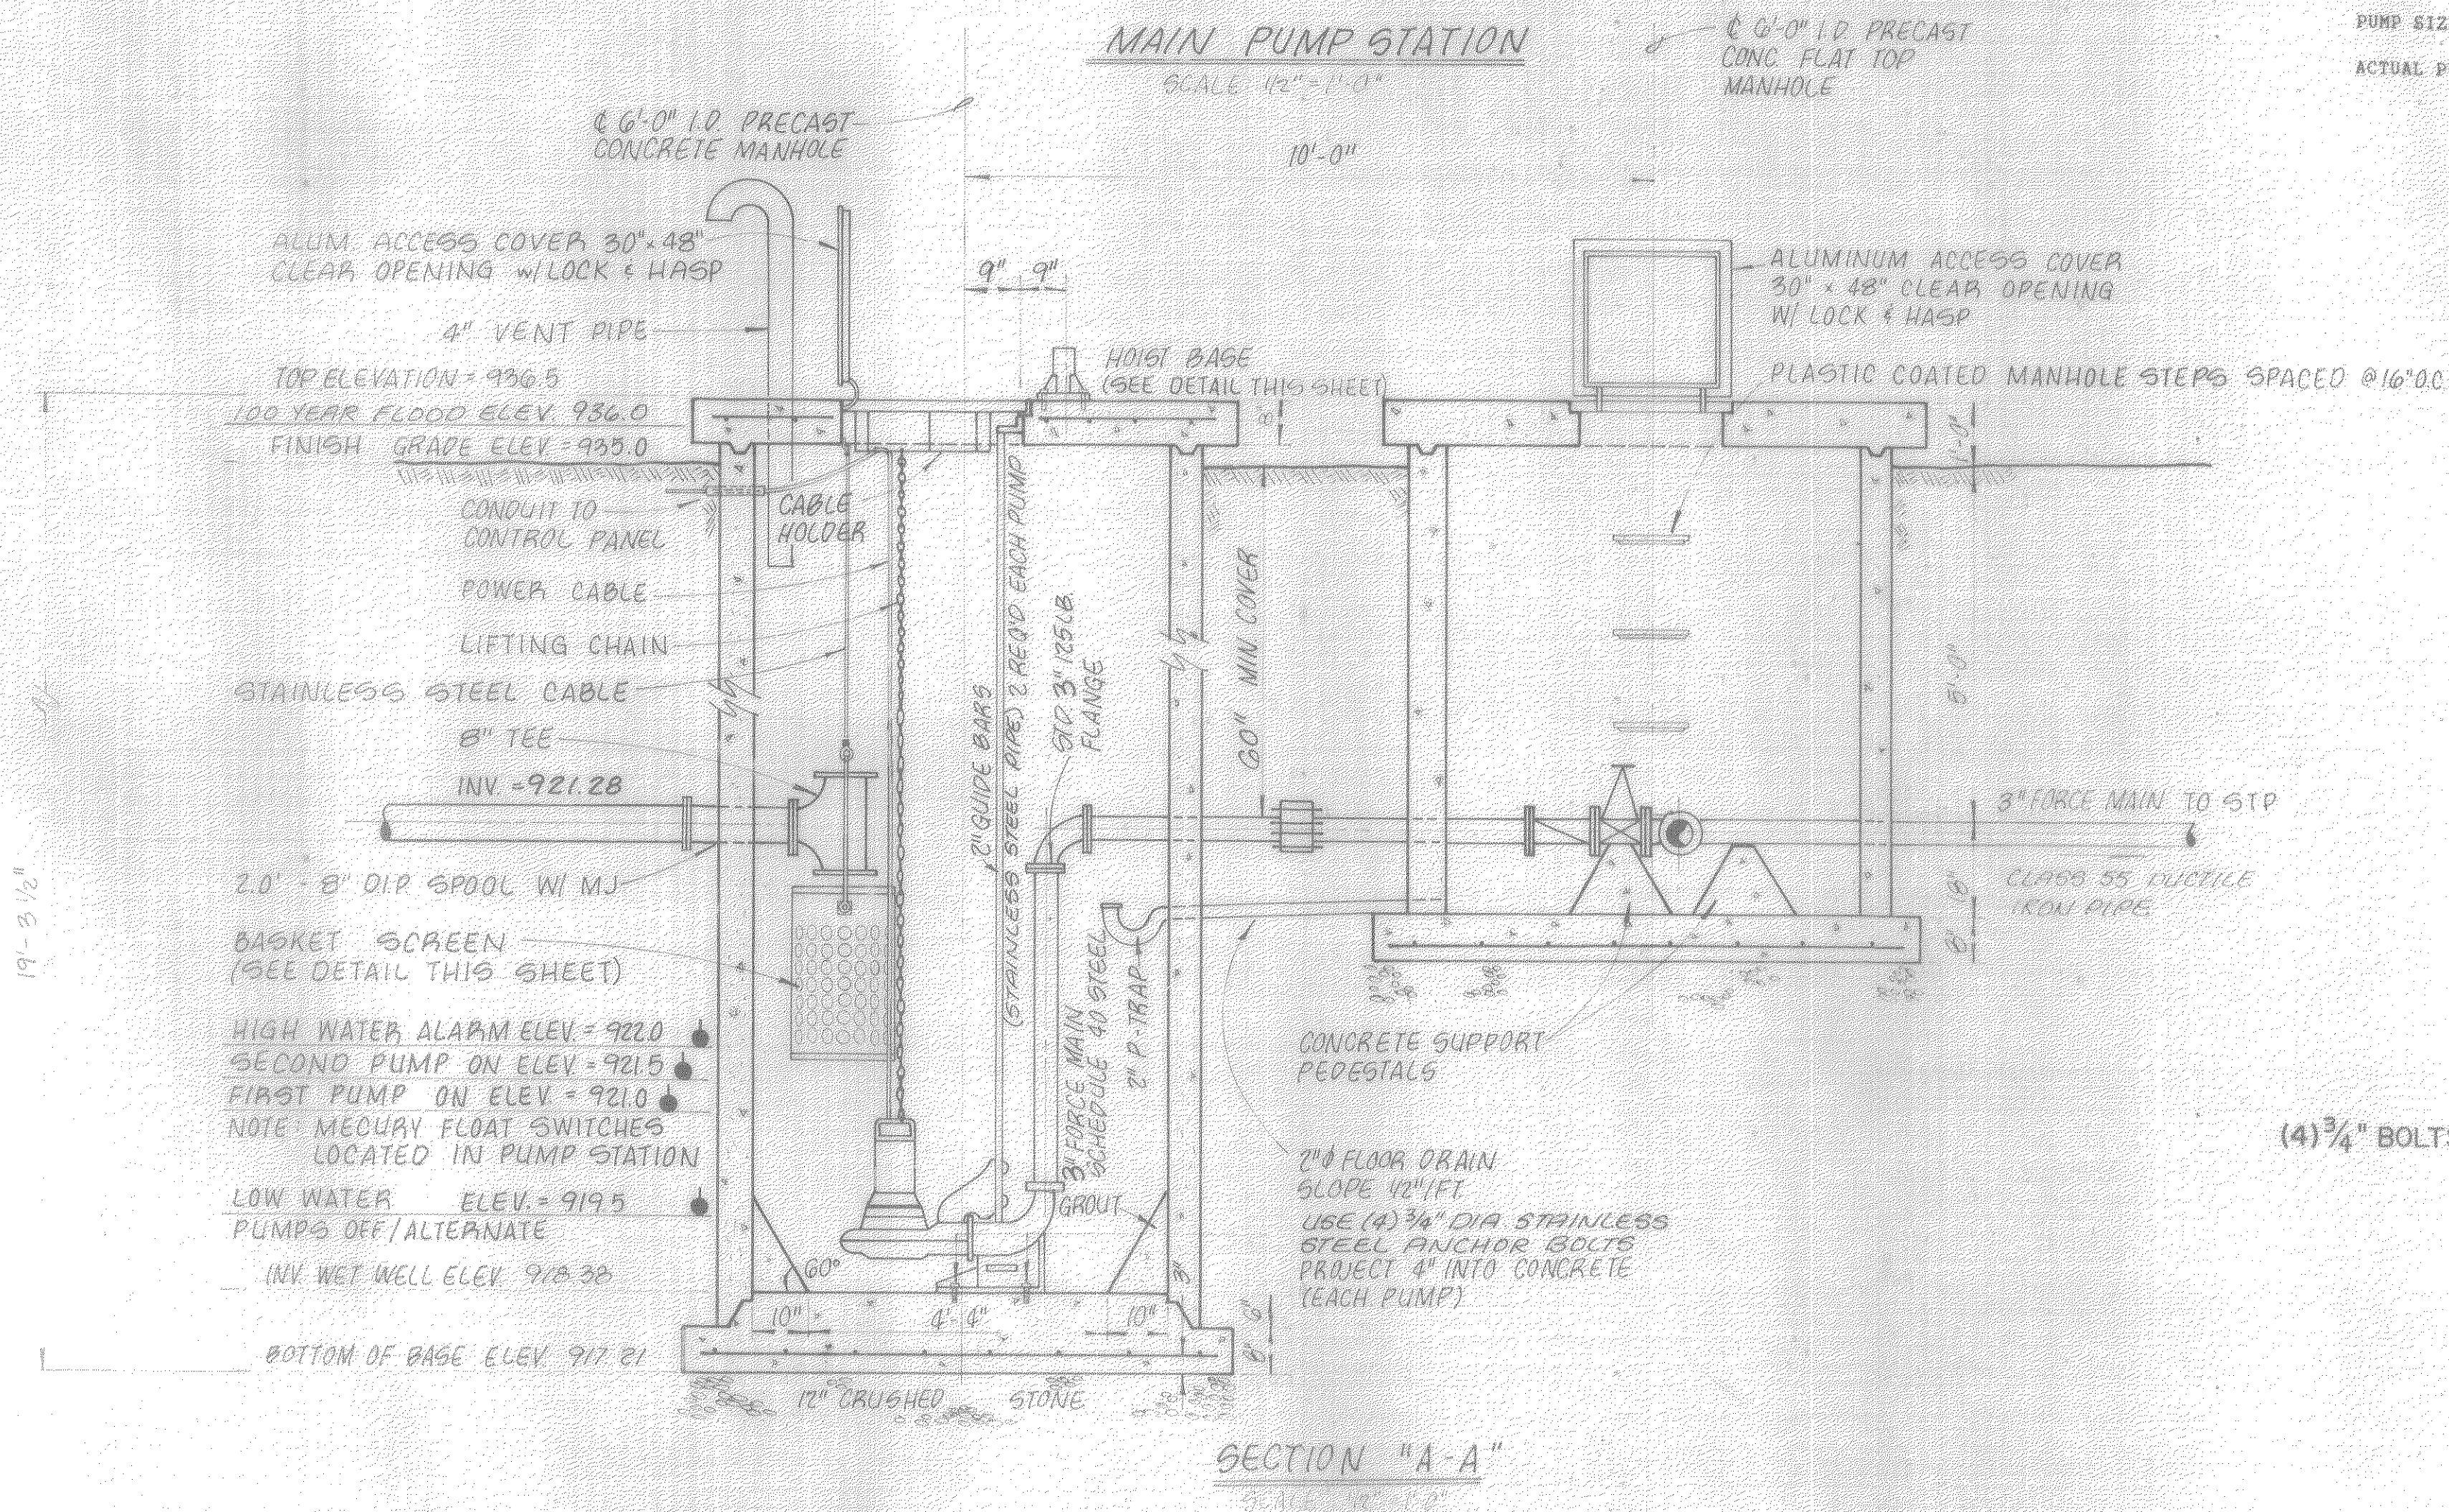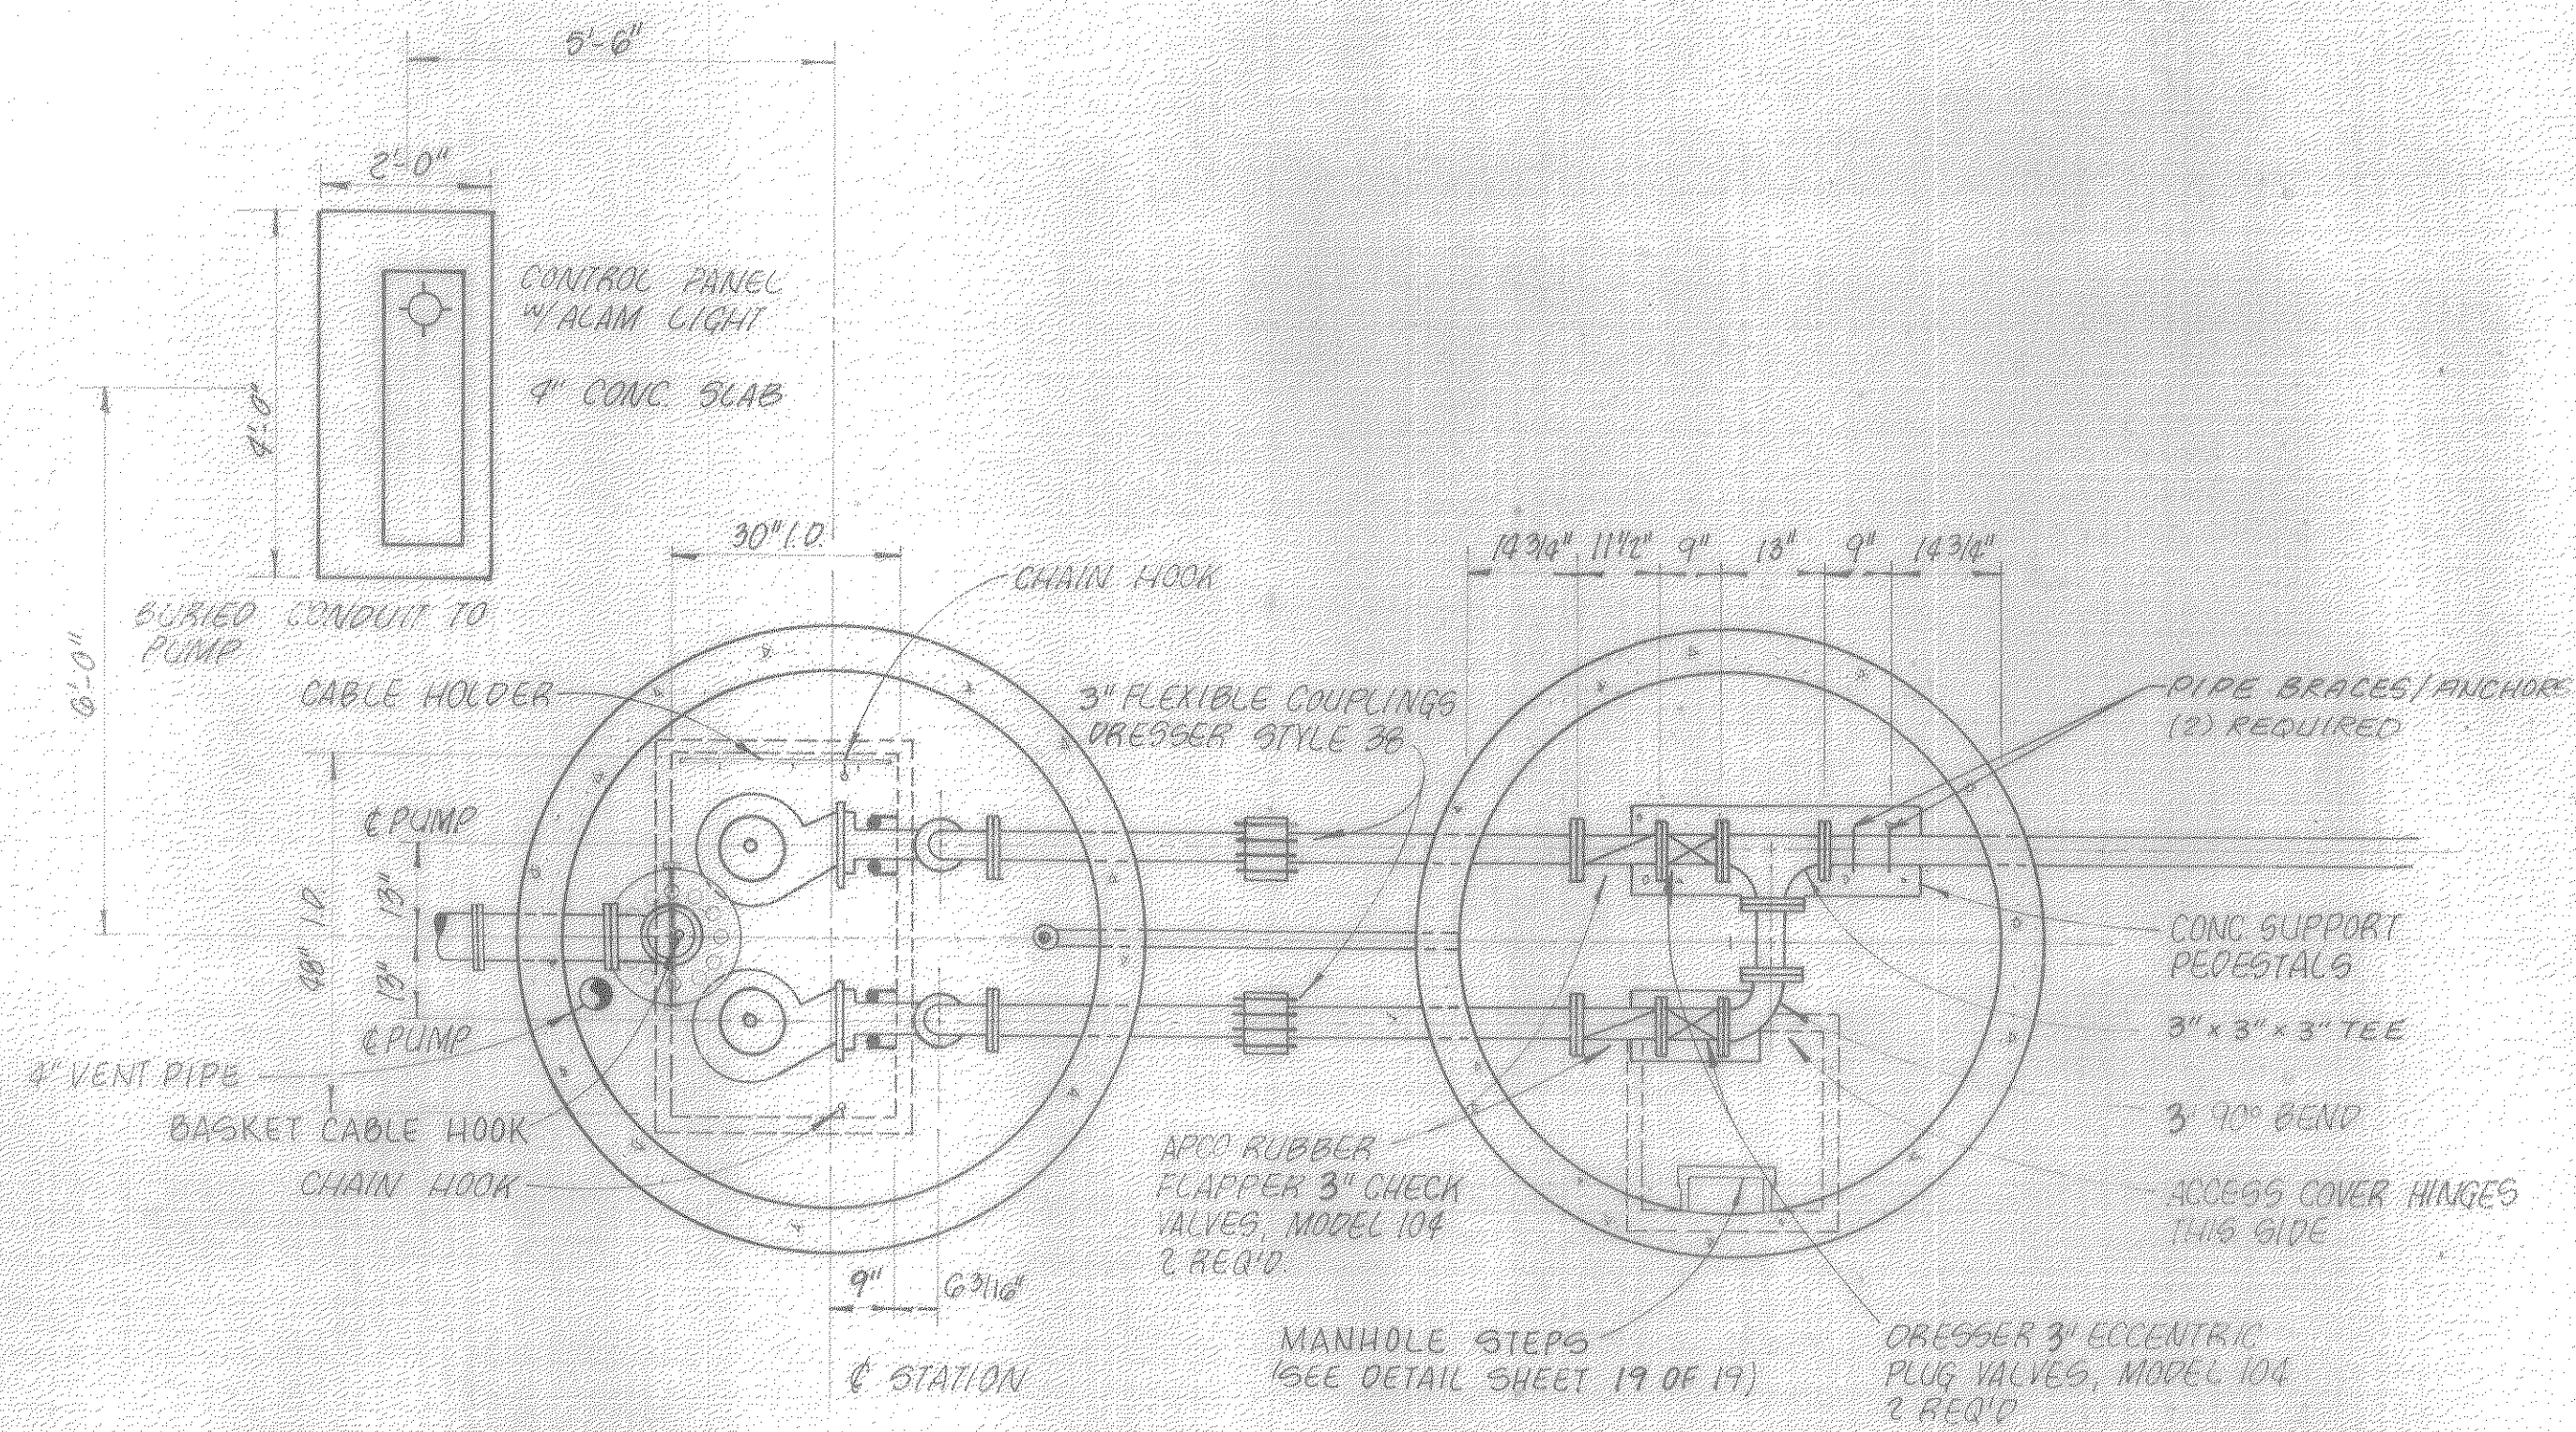

A. DESIGN CRITERIA

FLOW - INTERMITTENT OPERATION
BASED ON WASTEWATER FLOW

REQ'D RATE OF FLOW - 20 GPM

DISCHARGE PIPE SIZE - 8"

MIN. SEWER VELOCITY - 2.0 FPS

DESIGN SEWER VELOCITY - 2.2 FPS

DESIGN RATE OF FLOW - 50 GPM

B. DETERMINATION OF HEAD

ELEVATION OF TOP OF DISCHARGE PIPE - 948.1

LOW WATER SHUT OFF ELEVATION - 921.0

STATIC HEAD IN FEET - 27.1

COEFFICIENT OF ROUGHNESS - 120

FRICTION LOSS FT/100 FT - 1.1

LENGTH OF FORCE MAIN - 115'

EQUIVALENT LENGTH OF FITTINGS - 94

TOTAL EQUIV. LENGTH OF PIPE - 209

FRICTION LOSS IN FEET - 2.3

TOTAL DYNAMIC HEAD - 29.4

C. PUMP SELECTION - DUPLEX STATION

MANUFACTURER - FLYGT OR EQUAL

MODEL NUMBER - CP 3085

HORSE POWER - 3.0


SPEED - 1750 RPM

ELECTRICAL REQUIREMENTS - 3 @ 208


IMPELLER NUMBER 473

PUMP SIZE - 3"


ACTUAL PUMPING CONDITIONS - 48 GPM @ 30.5' TDH

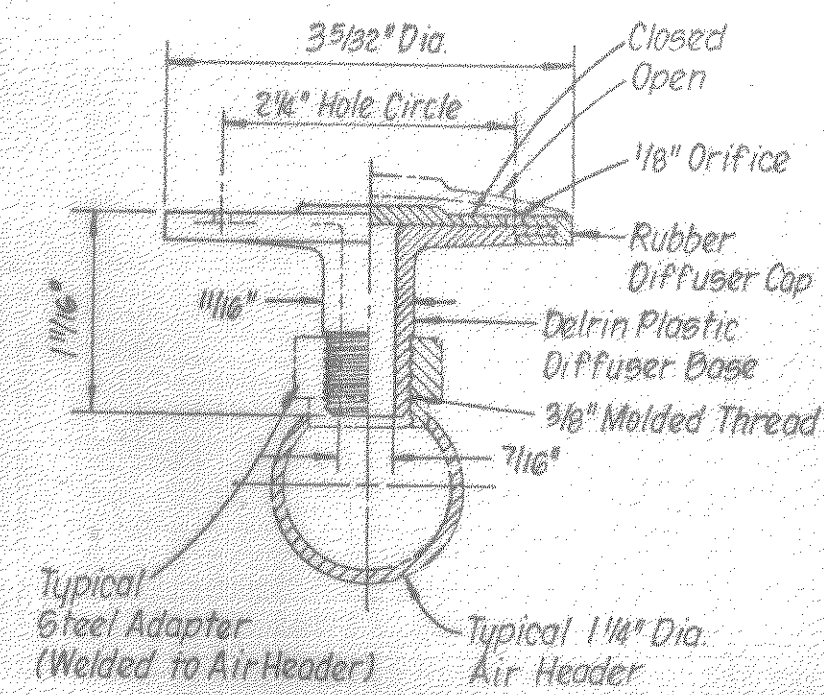

DIFFUSER
NOT TO SCALE

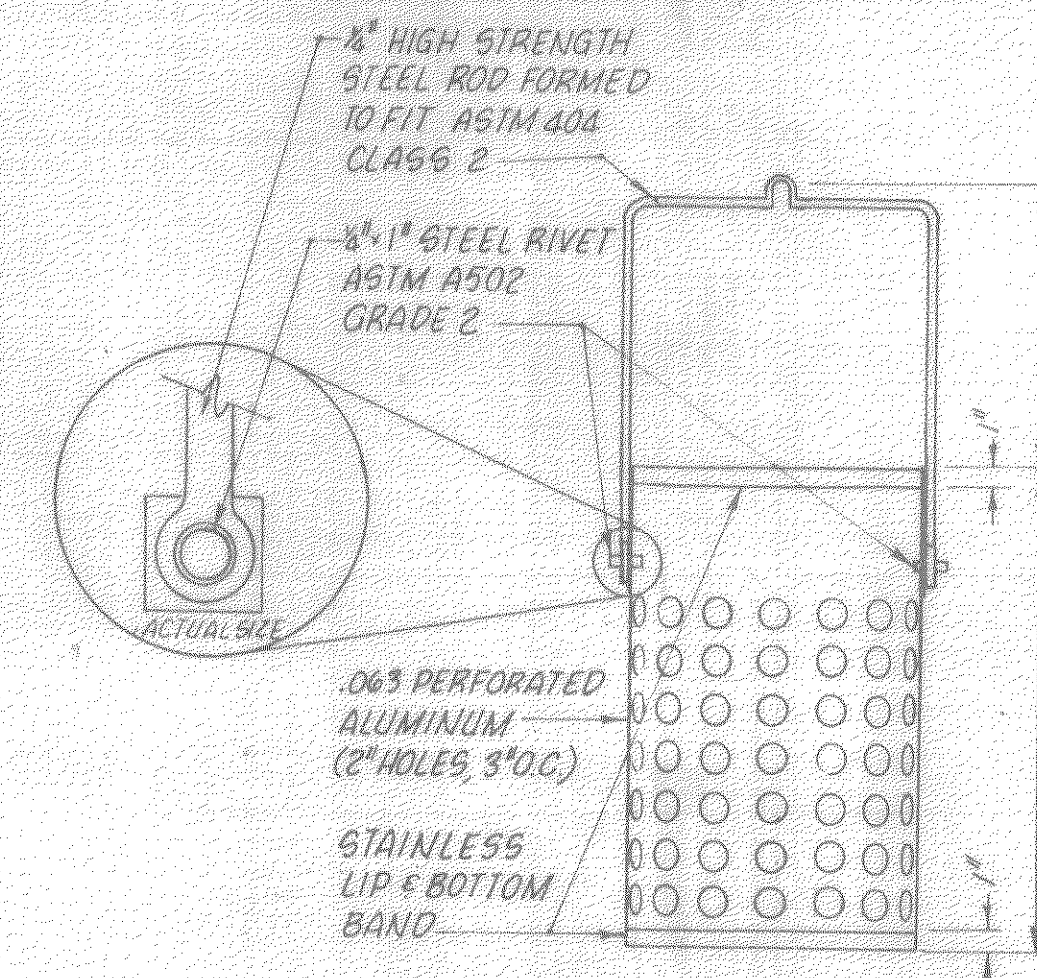


TRASH BASKET DETAIL
SCALE: 1" = 1'-0"

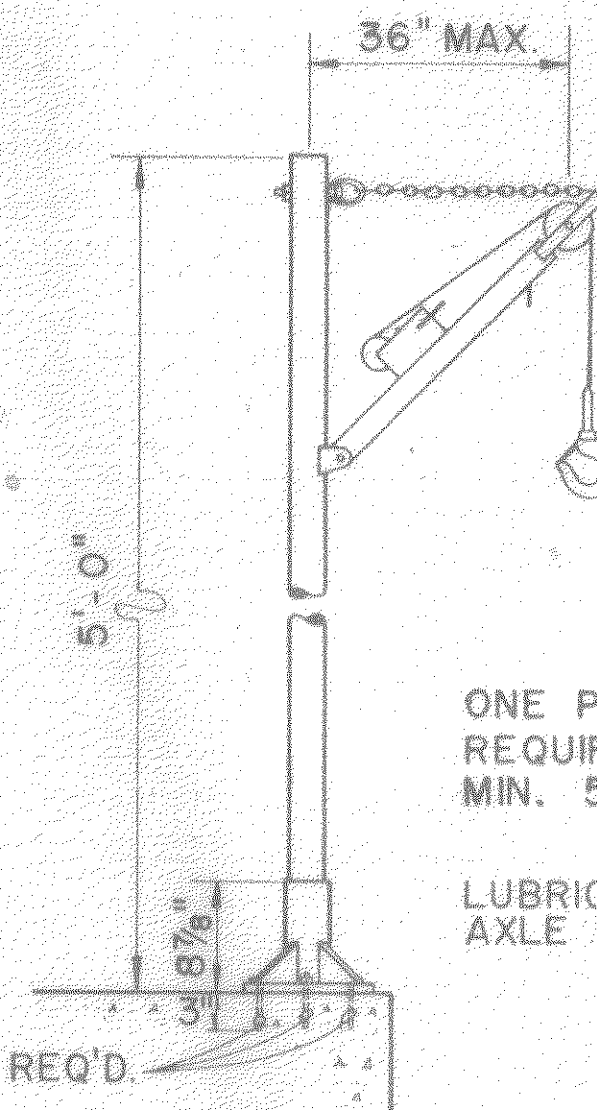


ONE PORTABLE HOIST REQUIRED. HOIST CAP. MIN. 500 LBS.


LUBRICATE SOCKET W/ AXLE GREASE PRIOR TO USE

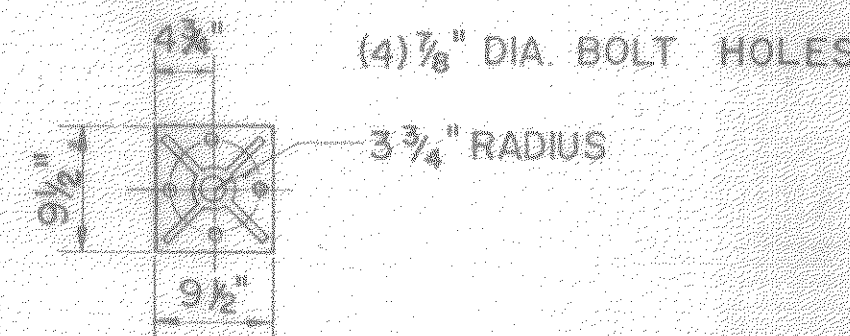


PORTABLE HOIST
NOT TO SCALE

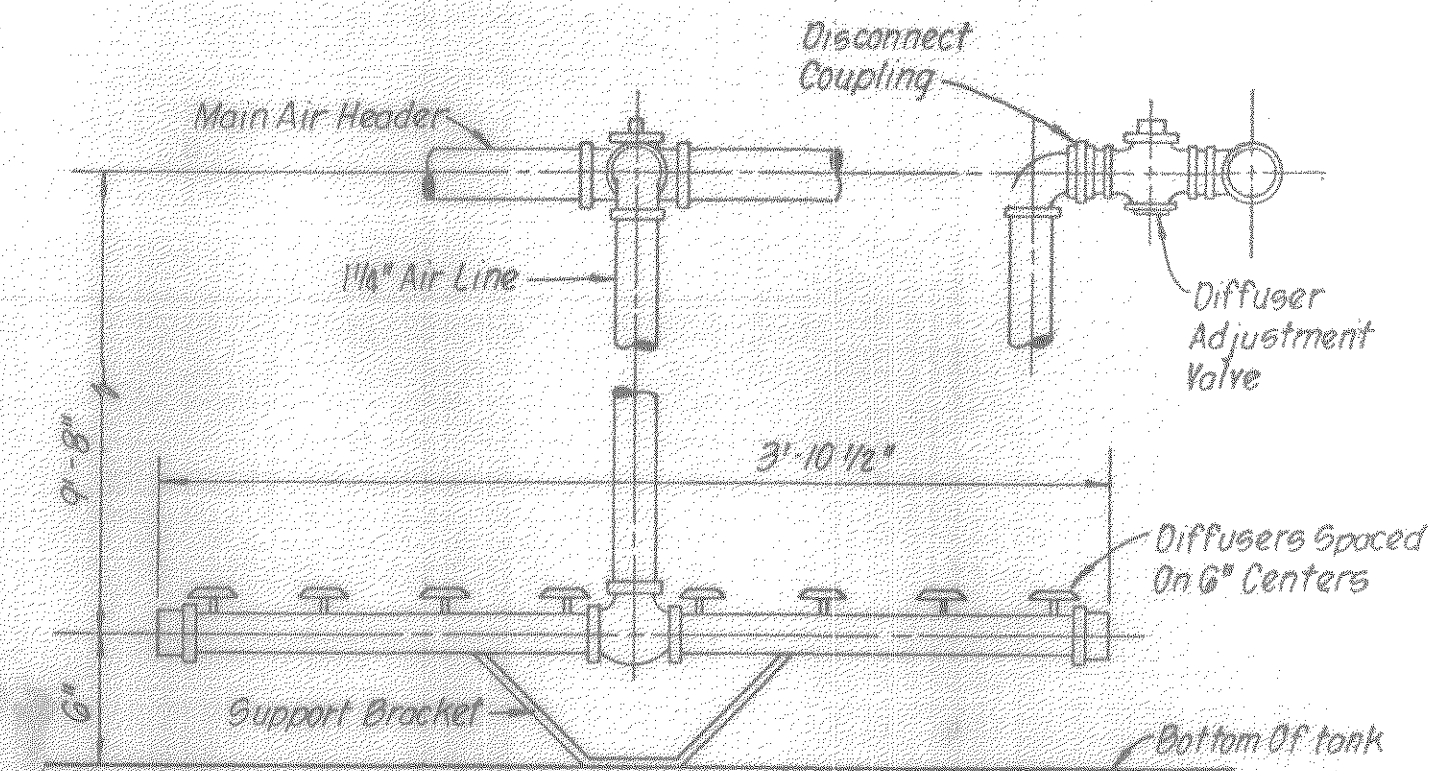

DIFFUSER ASSEMBLY
NOT TO SCALE

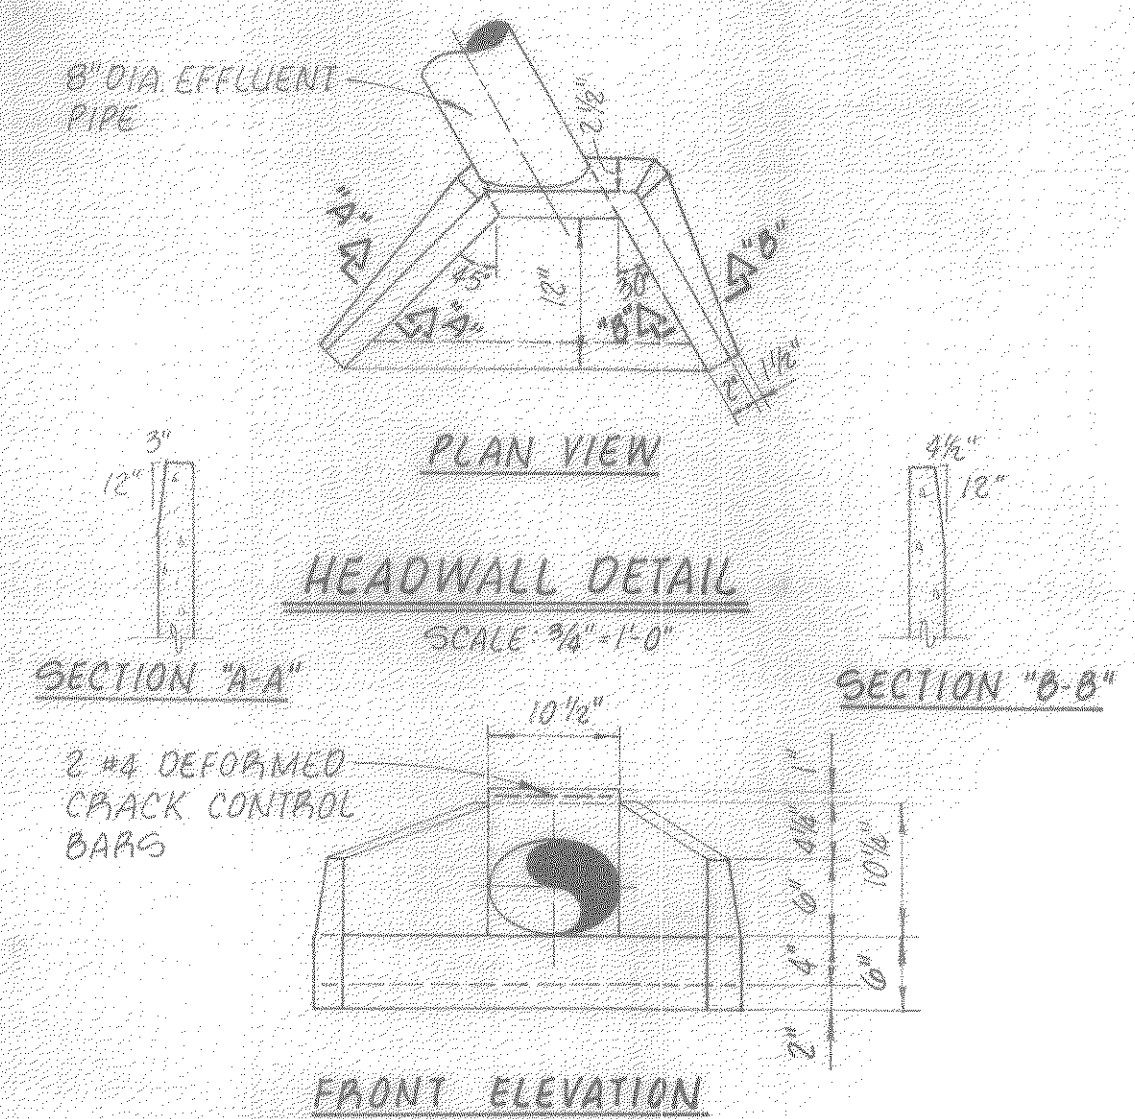

FRONT ELEVATION

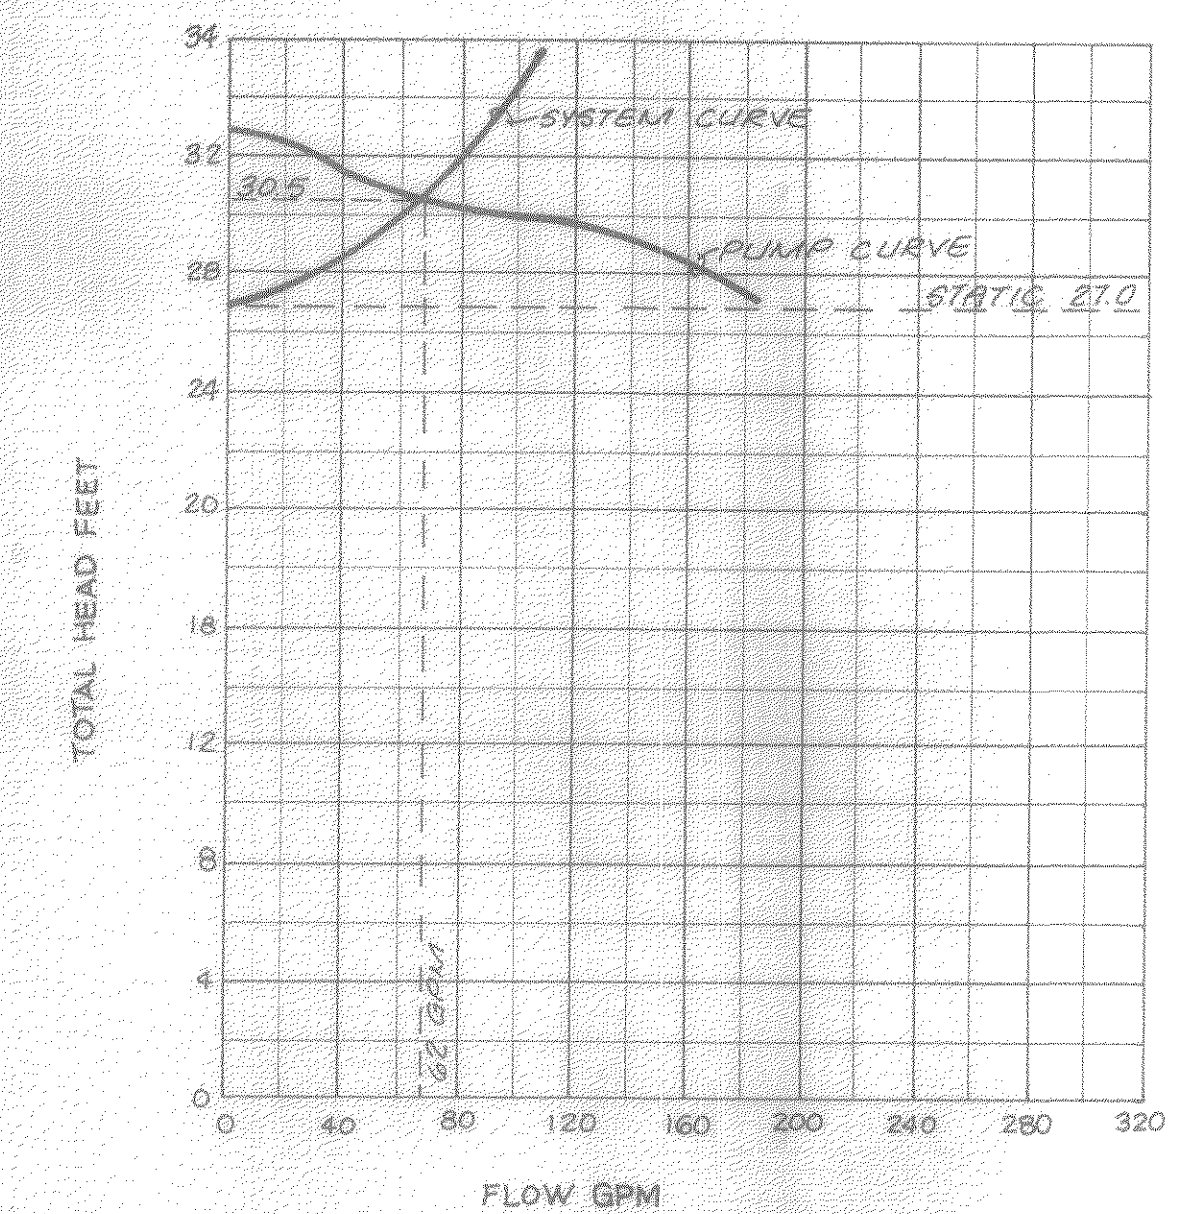


PUMP CURVE
MAIN PUMP STATION

Designed: WGP
Drafted: JRM
Checked: CCB
Approved: JMD


Clean Water Engineers, Inc.
Fincastle, Virginia

COMMUNITY OF EAGLE ROCK
WASTEWATER COLLECTION AND TREATMENT SYSTEM
BOTETOURT COUNTY, VIRGINIA

CONTRACT I
"AS BUILT"

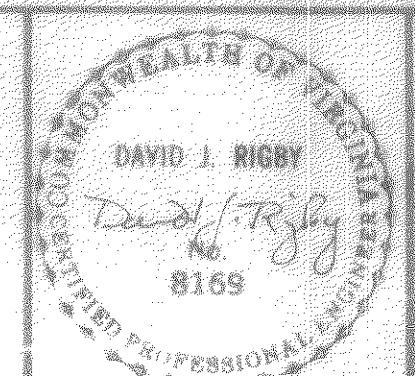


Sheet: 14 of 19
Scale: AS SHOWN
Date: DEC. 1987
Project: 86019

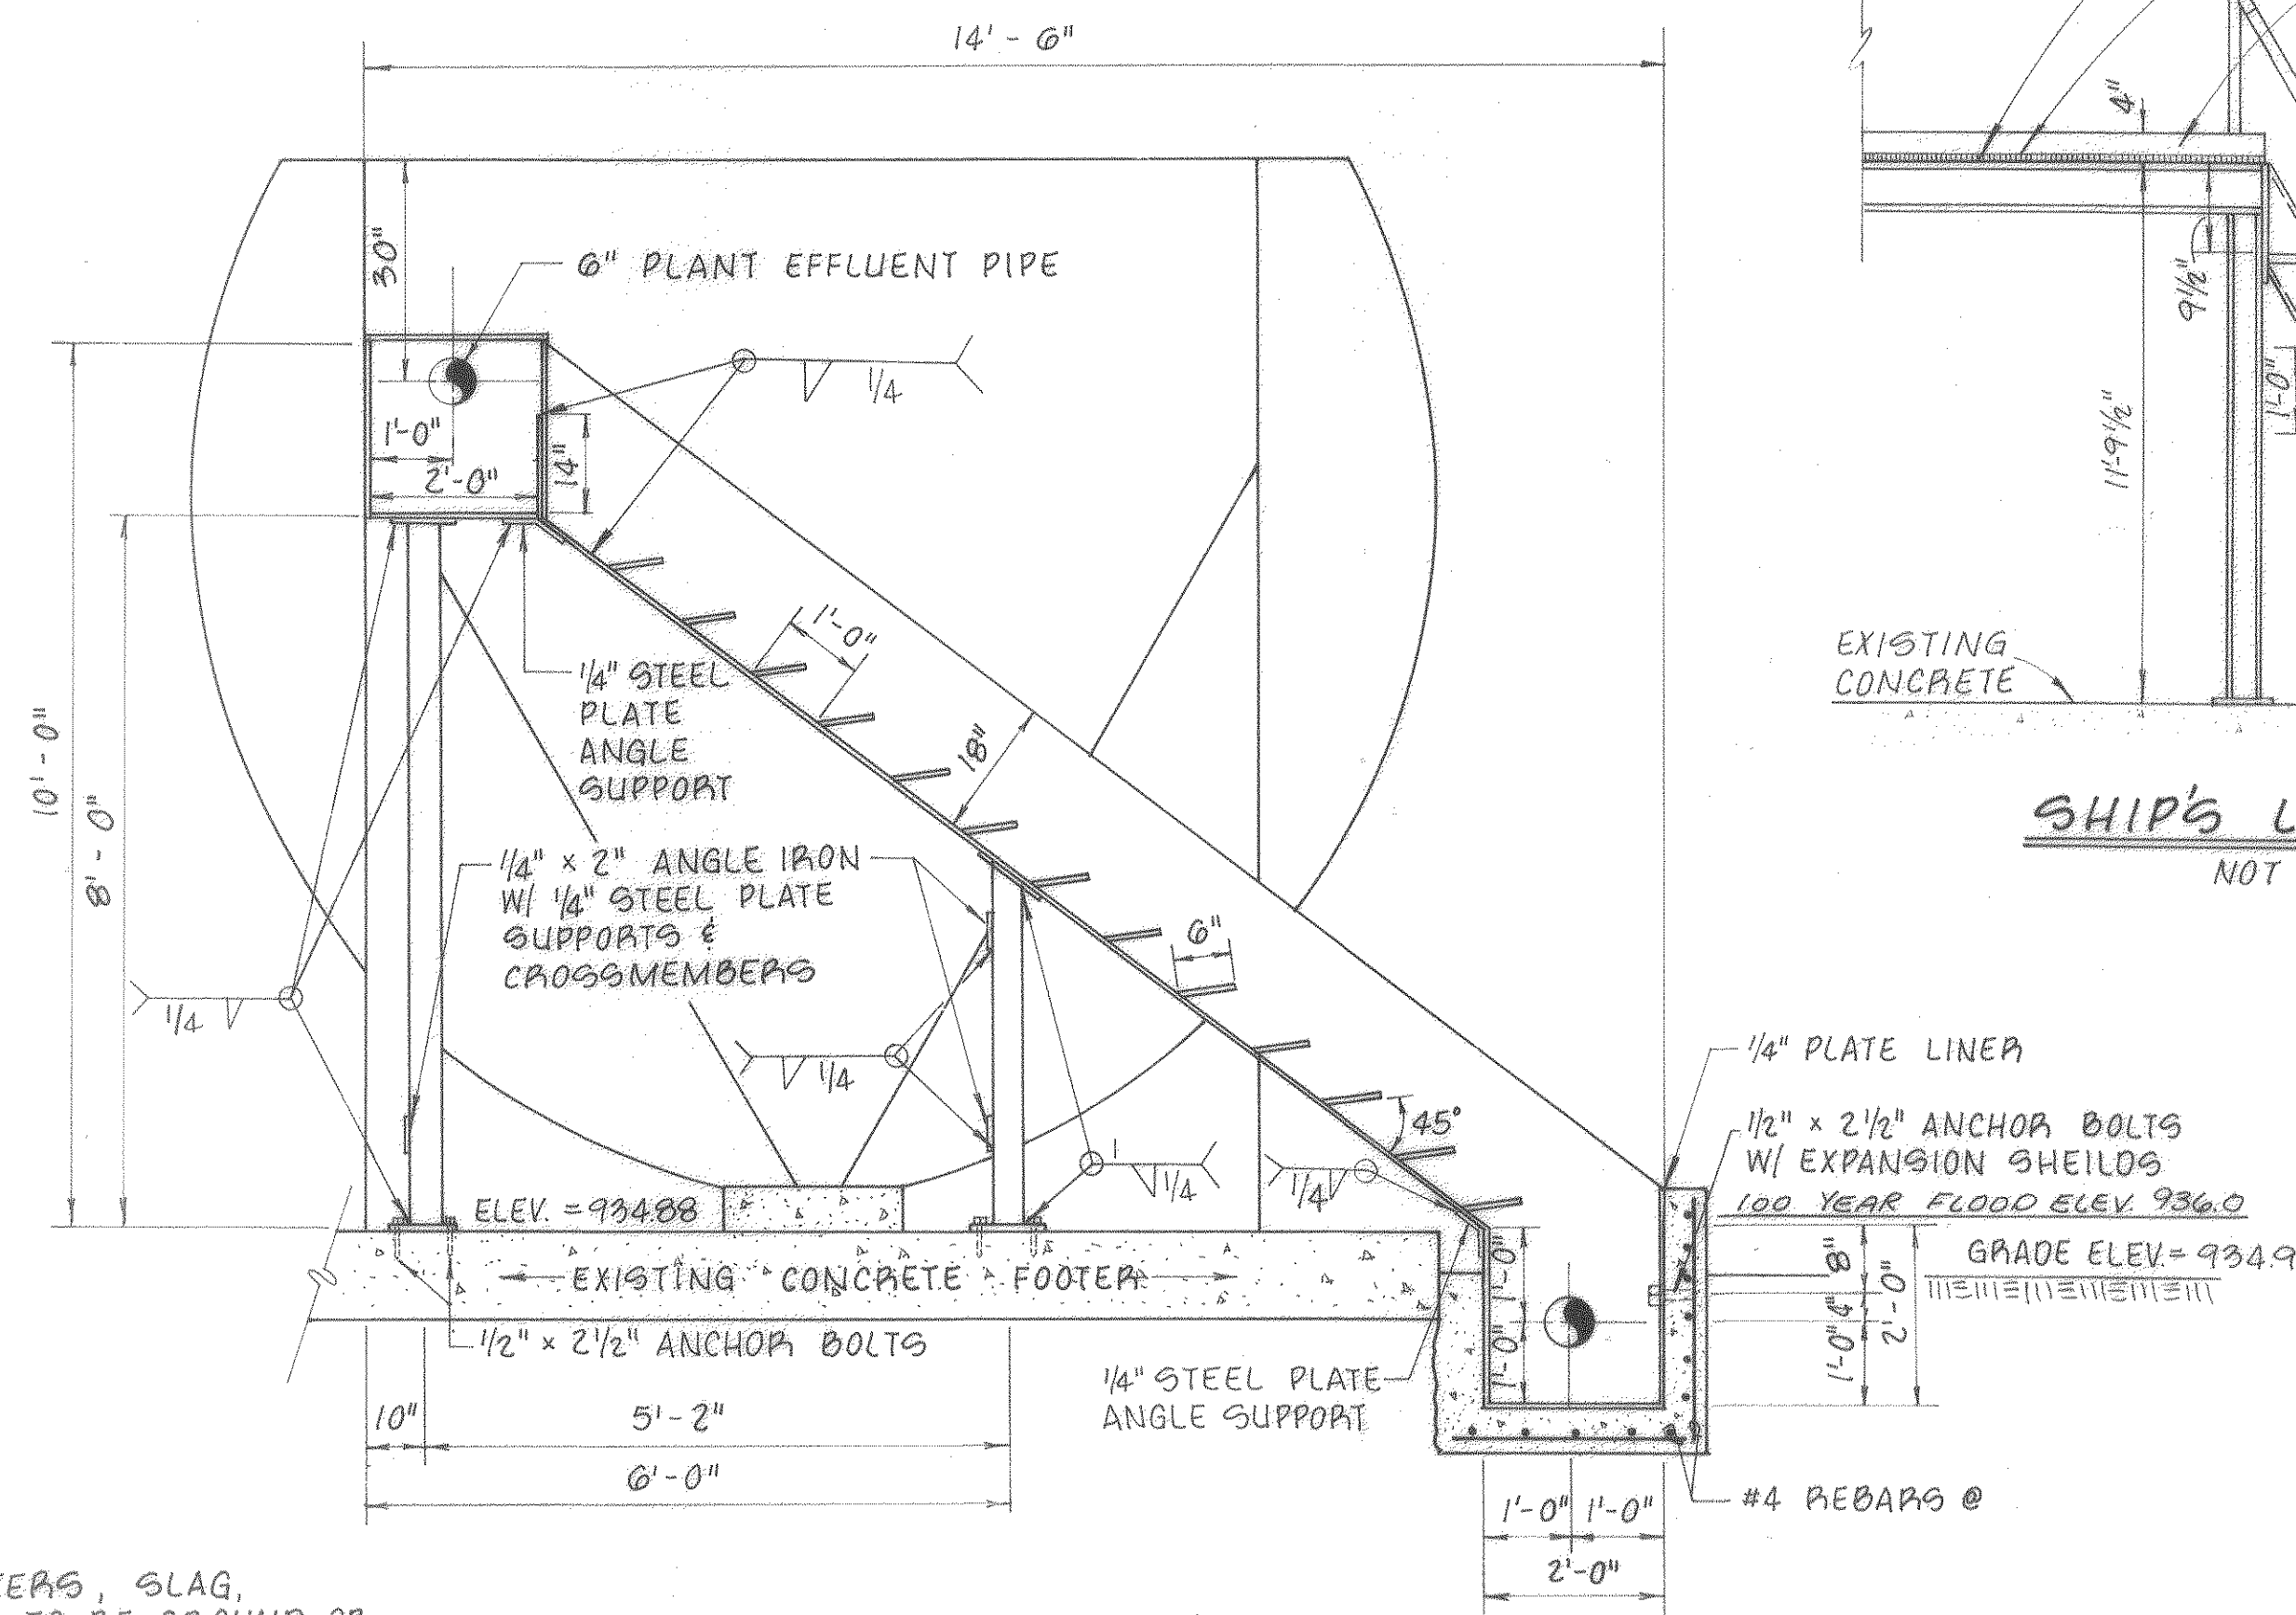


NOTES:

- ALL WELD SPATTERS, SLAG, & SHARP EDGES TO BE GROUND OR CHIPPED SMOOTH.
- CONTRACTOR'S OPTION ON FIELD PRIMING & PAINTING. SEE SPECS. FOR PAINTING REQUIREMENTS
- CASCADE STEPS TO BE CONTINUOUS WELD TO SIDES AND BOTTOM
- CASCADE SHOP FABRICATED AND FIELD ERECTED
- HOLES FOR EACH ANCHOR BOLT TO BE BORED SIMULTANEOUSLY THROUGH ALL MATERIALS


AERATION CASCADE
NOT TO SCALE

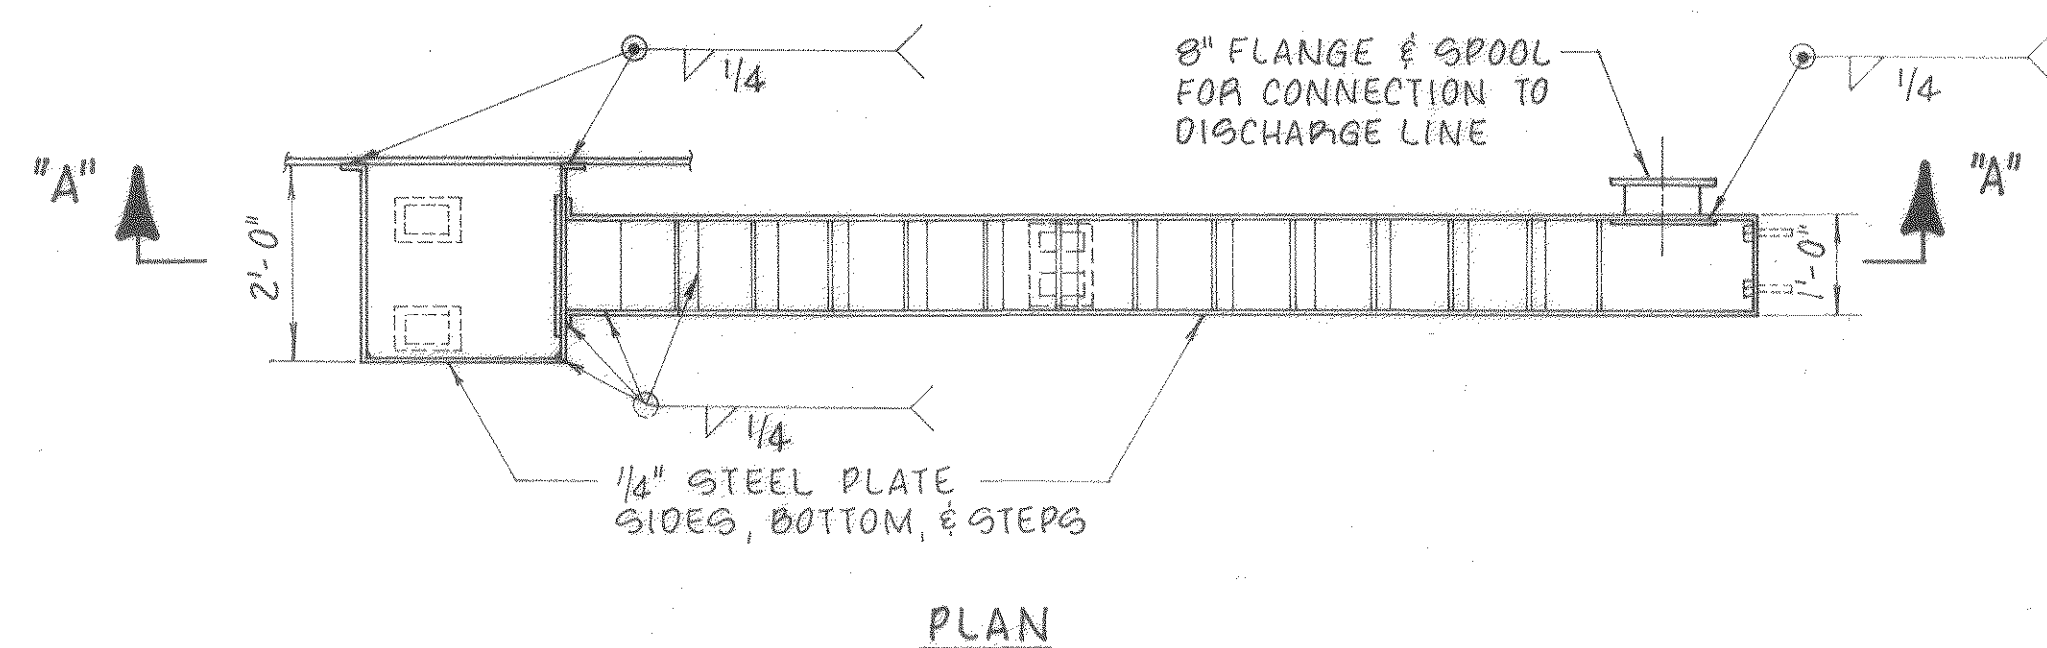


PLAN

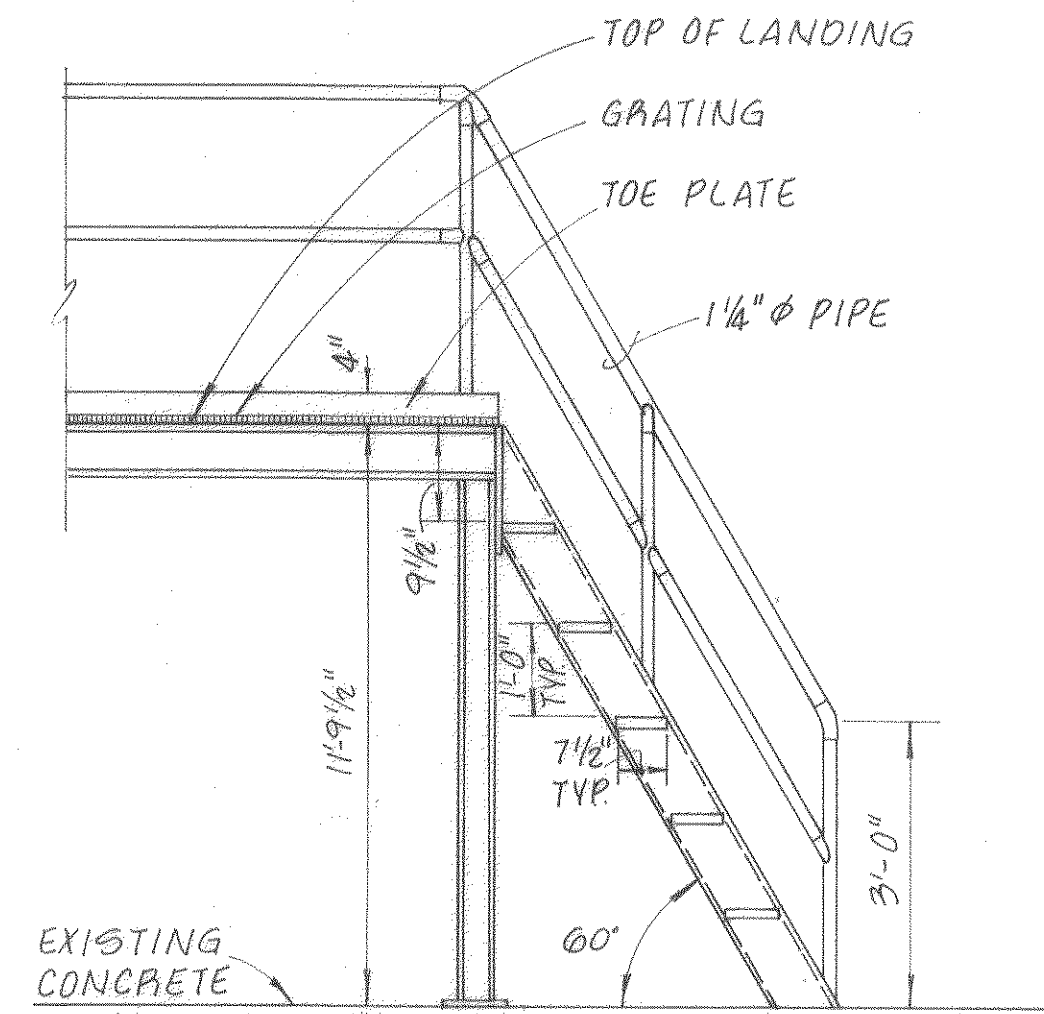

SHIP'S LADDER DETAIL
NOT TO SCALE

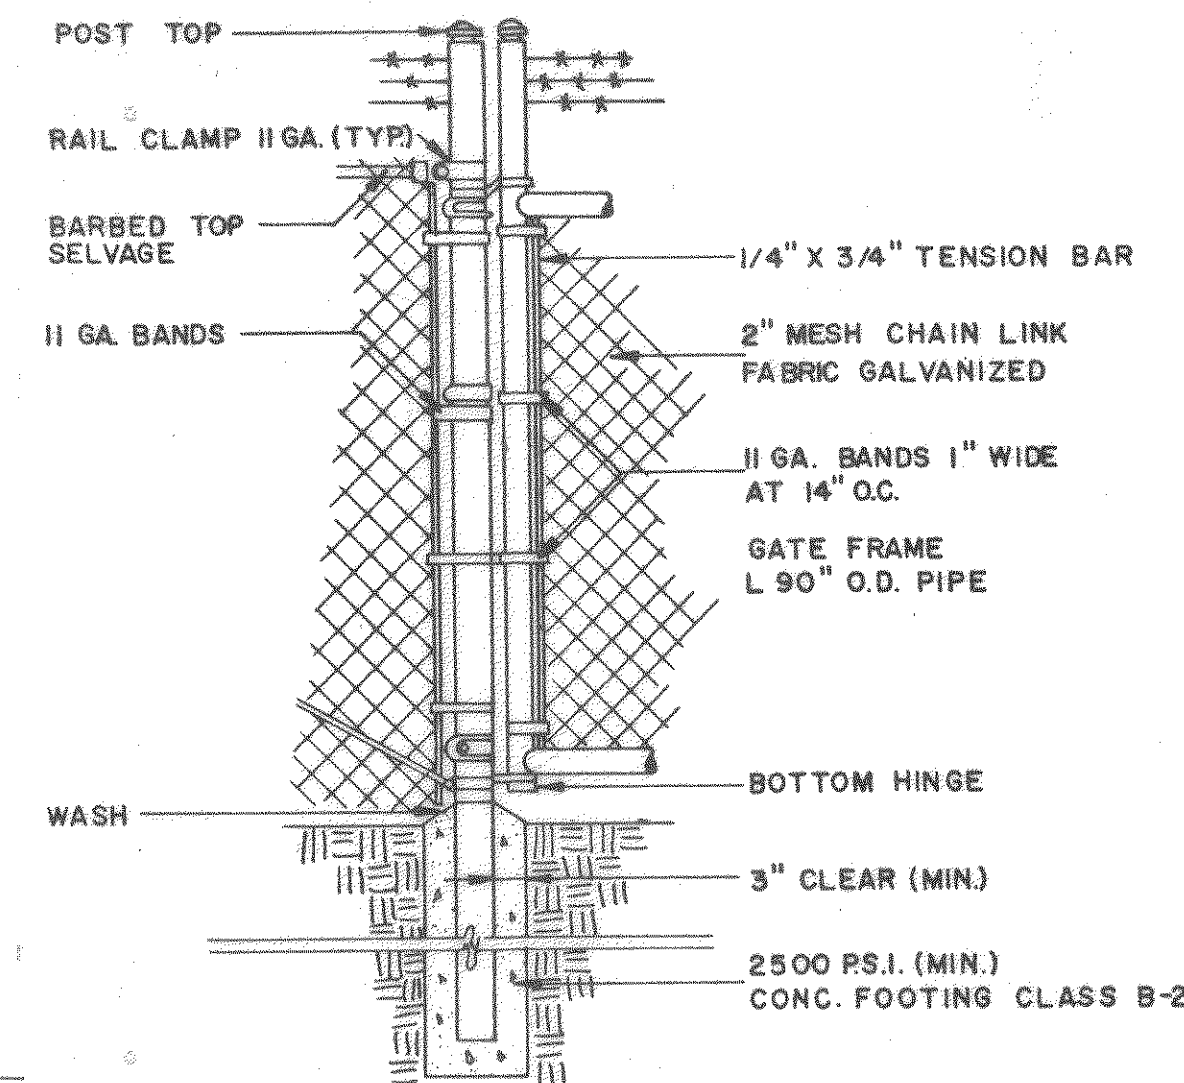

GATE DETAIL
NOT TO SCALE

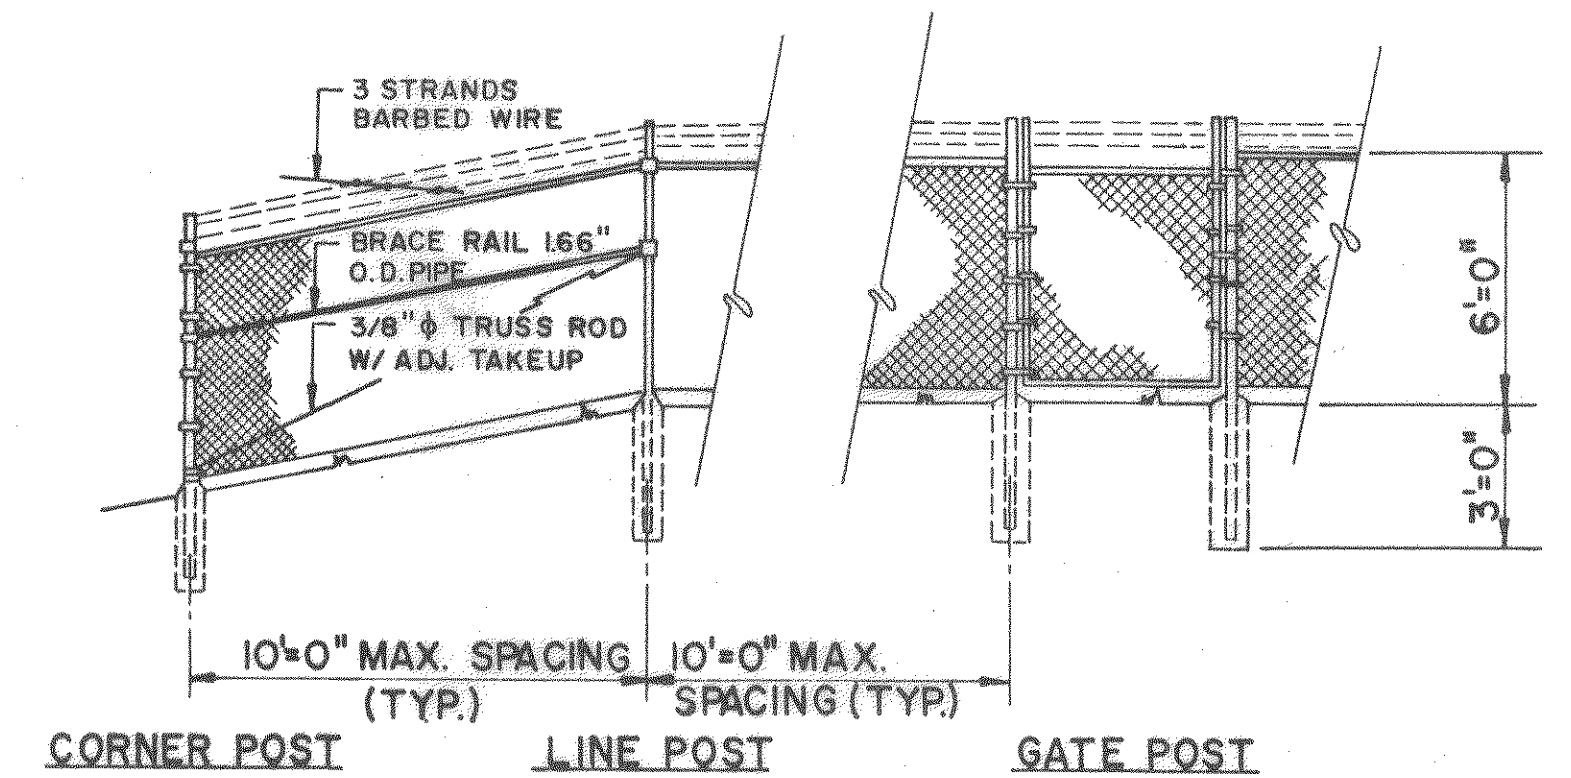

CHAIN LINK FENCE DETAIL
NOT TO SCALE

EQUIPMENT SCHEDULE			
ITEM	QUANTITY	MANUFACTURER	MODEL NO.
Water Heater	1	Chronomite	S23,11/220V, 10 21 Amp, 2300 Watt
Laboratory	1	American Std.	Ledgemere, P5300-40 w/NZ2109 Trim & Towel Racks on Slides
Toilet	1	American Std.	Instanto, F2510-8 Toilet Combination
Exterior Door	1	Penestra	Presidential 3068-G3
Unit Heater	1	Chronalox	MUH-05-8 W/MWB-5 Wall Bracket
Exhaust Fan	1	Broan	676
Backflow Preventer	1	Watts	Regulator, 1" Model 909
Windows	1	Pella	Std. Clad Awning 9'3-1/2"x2'5-3/4" Model No. 3224CA31
	1	Pella	Std. Clad Casement 3'6-1/2" x 2'9-3/4", Model No. 1628CC2
Yard Lights	2	Sylvania	MTH-150-HPS-5P-230-A-259-1 A363 w/Built-in Photo-cell and 22" aluminum mast arm
Lighting	4	Lithonia	LB440, Surface Mtd
	1	Sylvania	AK3-P-70HPS Wall surface mtd 120-H-PC
Lighting	2	Markstone	HPS W4953, Surface mounted in overhang w/freshner lens
	1	Prescolite	9316, Surface mounted in attic space
Cabinets	40 sq. ft.	Merrillat	
Hypochlorite System	1	B/F	As Shown
Stool	1	Hamilton	950M478
Dry Chemical Fire Extinguisher	1	Lab Safety Supply	B1123
First Aid Kit	1	Johnson & Johnson	B3244

LAB EQUIPMENT			
ITEM	QUANTITY	MANUFACTURER	MODEL NO.
Centrifuge	1	Raven	F10300
Centrifuge Tubes	12	Raven	B10101
DPD-Chlorine Test Kit	1	HACH	CN-70
Dissolved Oxygen Meter	1	YSI	51B
Dissolved Oxygen Probe	1	YSI	5739
Dissolved Oxygen Probe Cable	1	YSI	5740
Sludge Blanket Detector (Core Tacker)	1	Raven	B10104
Settlimeter	1	Raven	C10102
Refrigerator 6.0 cu. ft.	1	Sears	46 MR 9660BN
pH Meter	1	Analytical Measurements	Model 707
4.0 Buffer Solution	1	Fisher	SB101-500
7.0 Buffer Solution	1	Fisher	SB107-500
10.0 Buffer Solution	1	Fisher	SB115-500
Laboratory Containers:			
ITEM	QUANTITY	MANUFACTURER	* MODEL NO.
Wash Bottles	6 (1 case)	Fisher	03-409-22A
2 liter Sample Containers	6 (1 case)	Nalgene	11-815-11A
250 ml Sample Containers	72 (1 case)	Nalgene	02-893B
1000 ml Beakers	6	Fisher	02-540P
600 ml Beakers	6	Fisher	02-540M
100 ml Beakers	12	Fisher	02-540H
50 ml Beakers	12	Fisher	02-540G


*All Model Nos. are Fisher Catalog Nos.

Designed: WGP
Drafted: TAM
Checked: CCB
Approved: JMD




Clean Water Engineers, Inc.
Fincastle, Virginia

COMMUNITY OF EAGLE ROCK
WASTEWATER COLLECTION AND TREATMENT SYSTEM
BOTETOURT COUNTY, VIRGINIA



CONTRACT I
"AS BUILT"

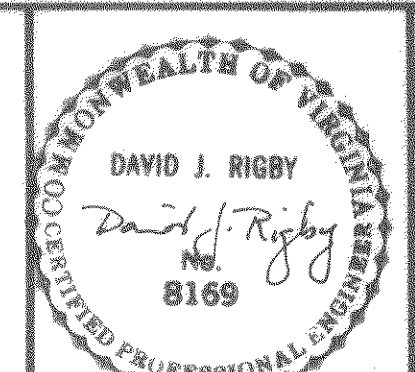


Sheet: 15 of 19
Scale: AS SHOWN
Date: DEC. 1987
Project: 86019

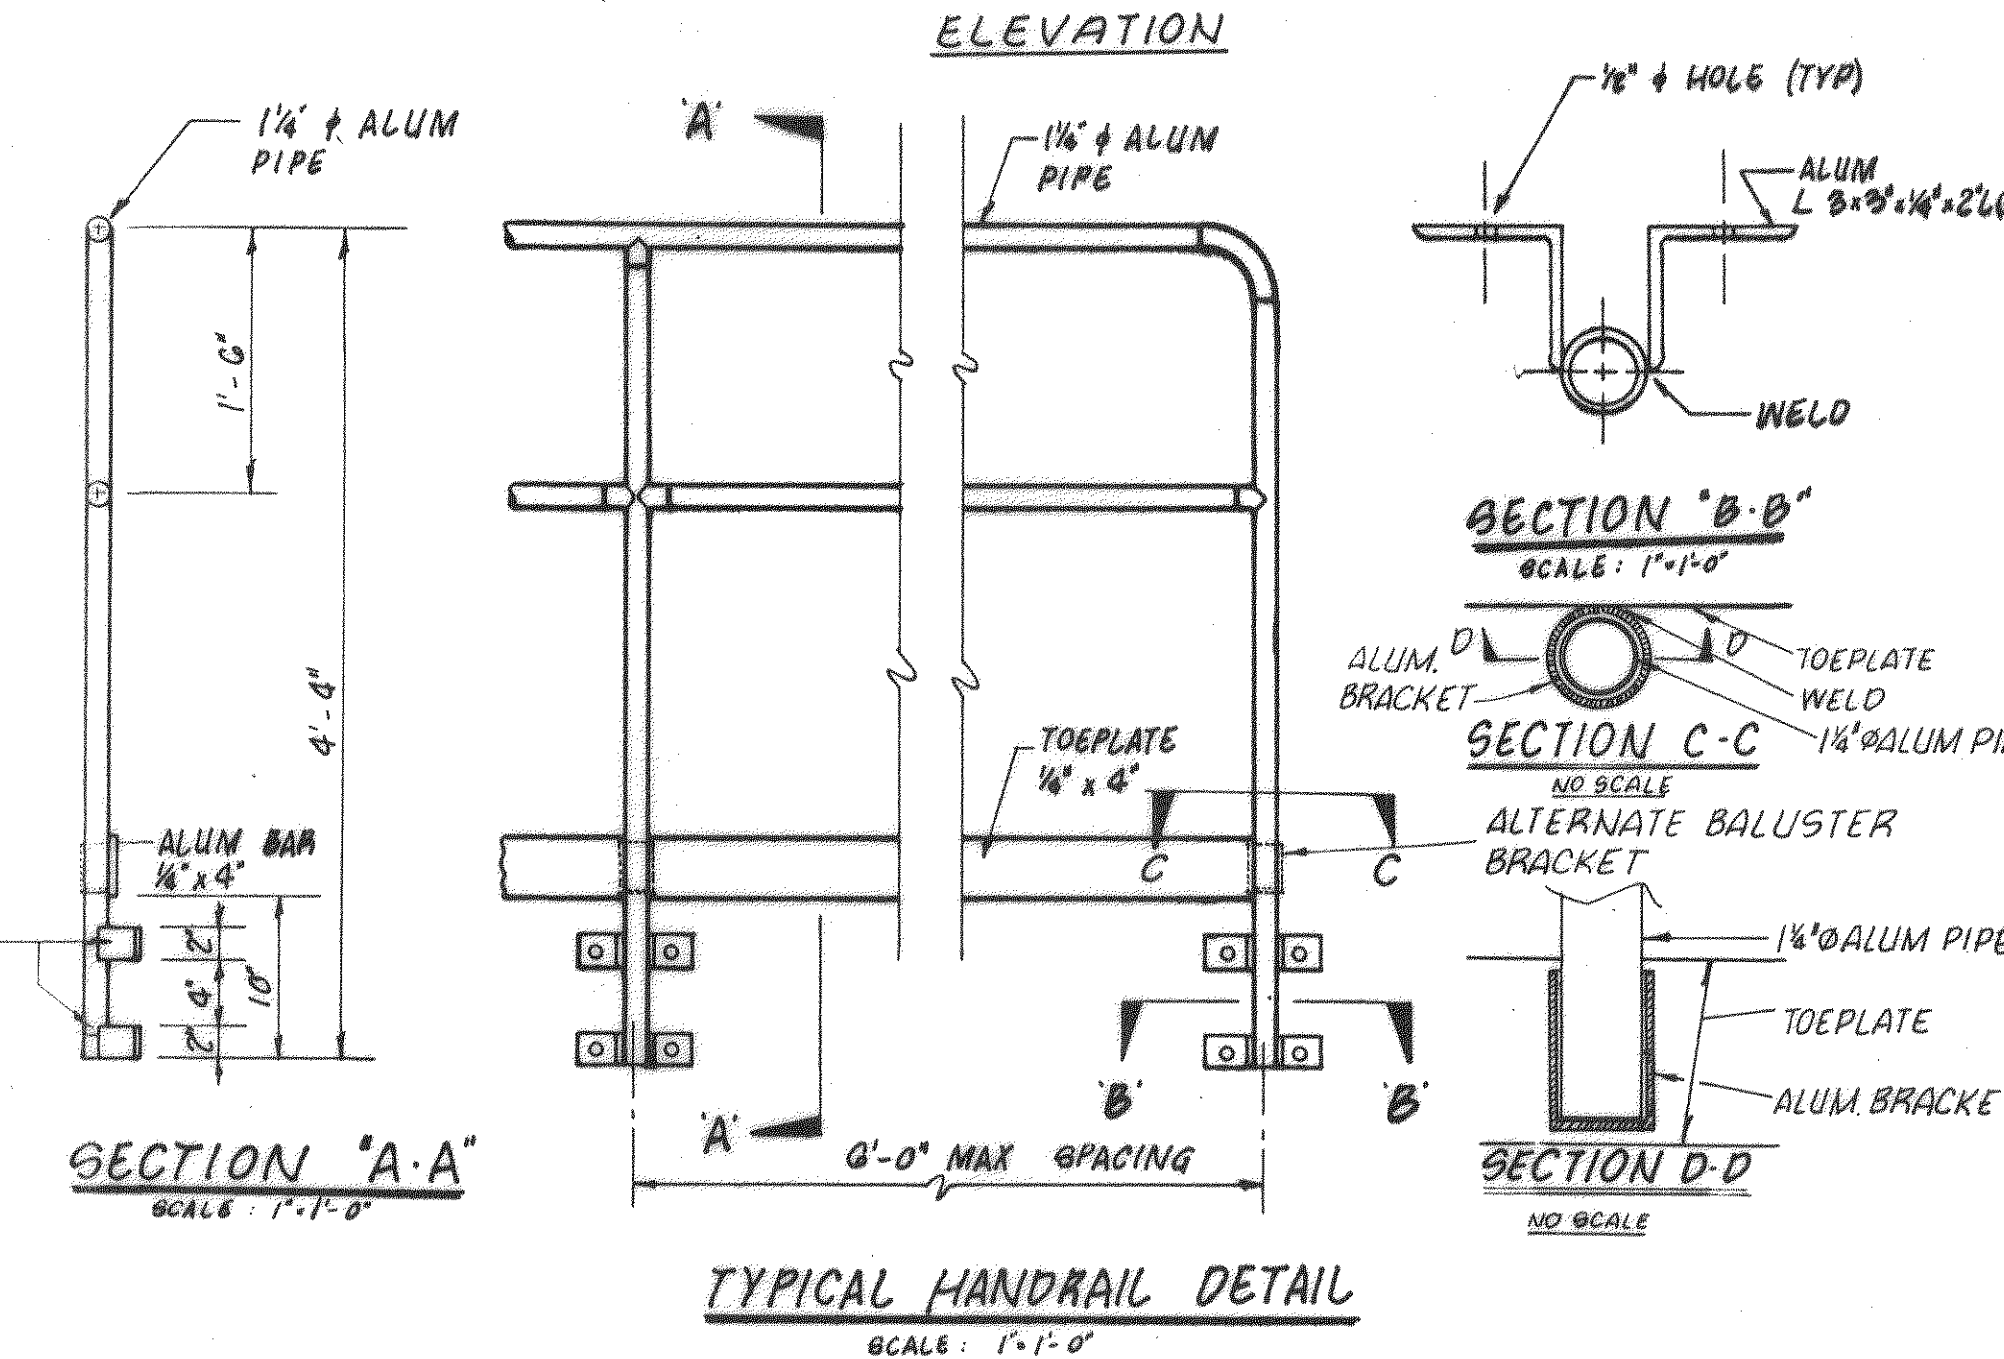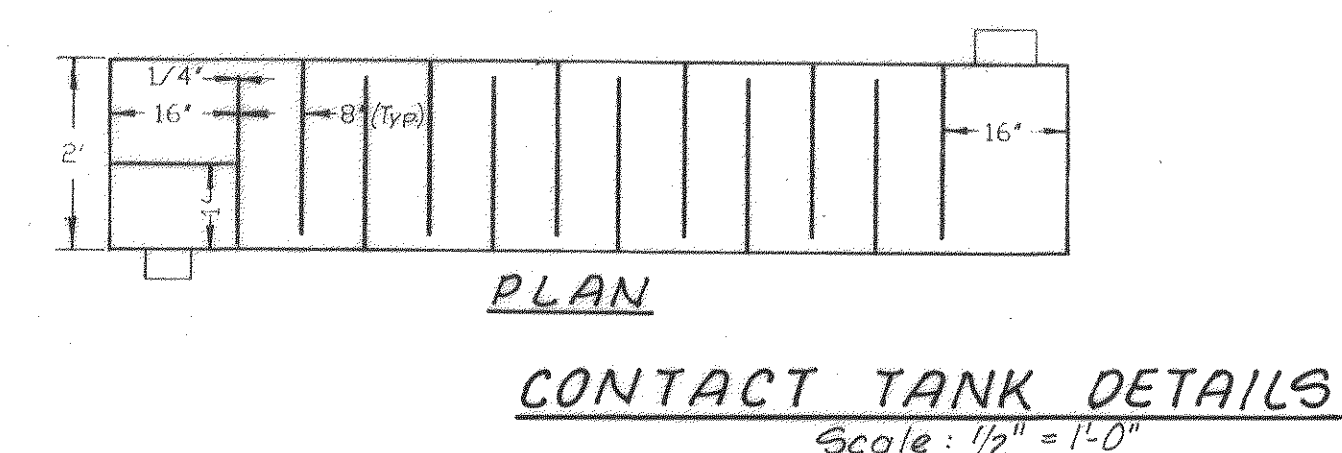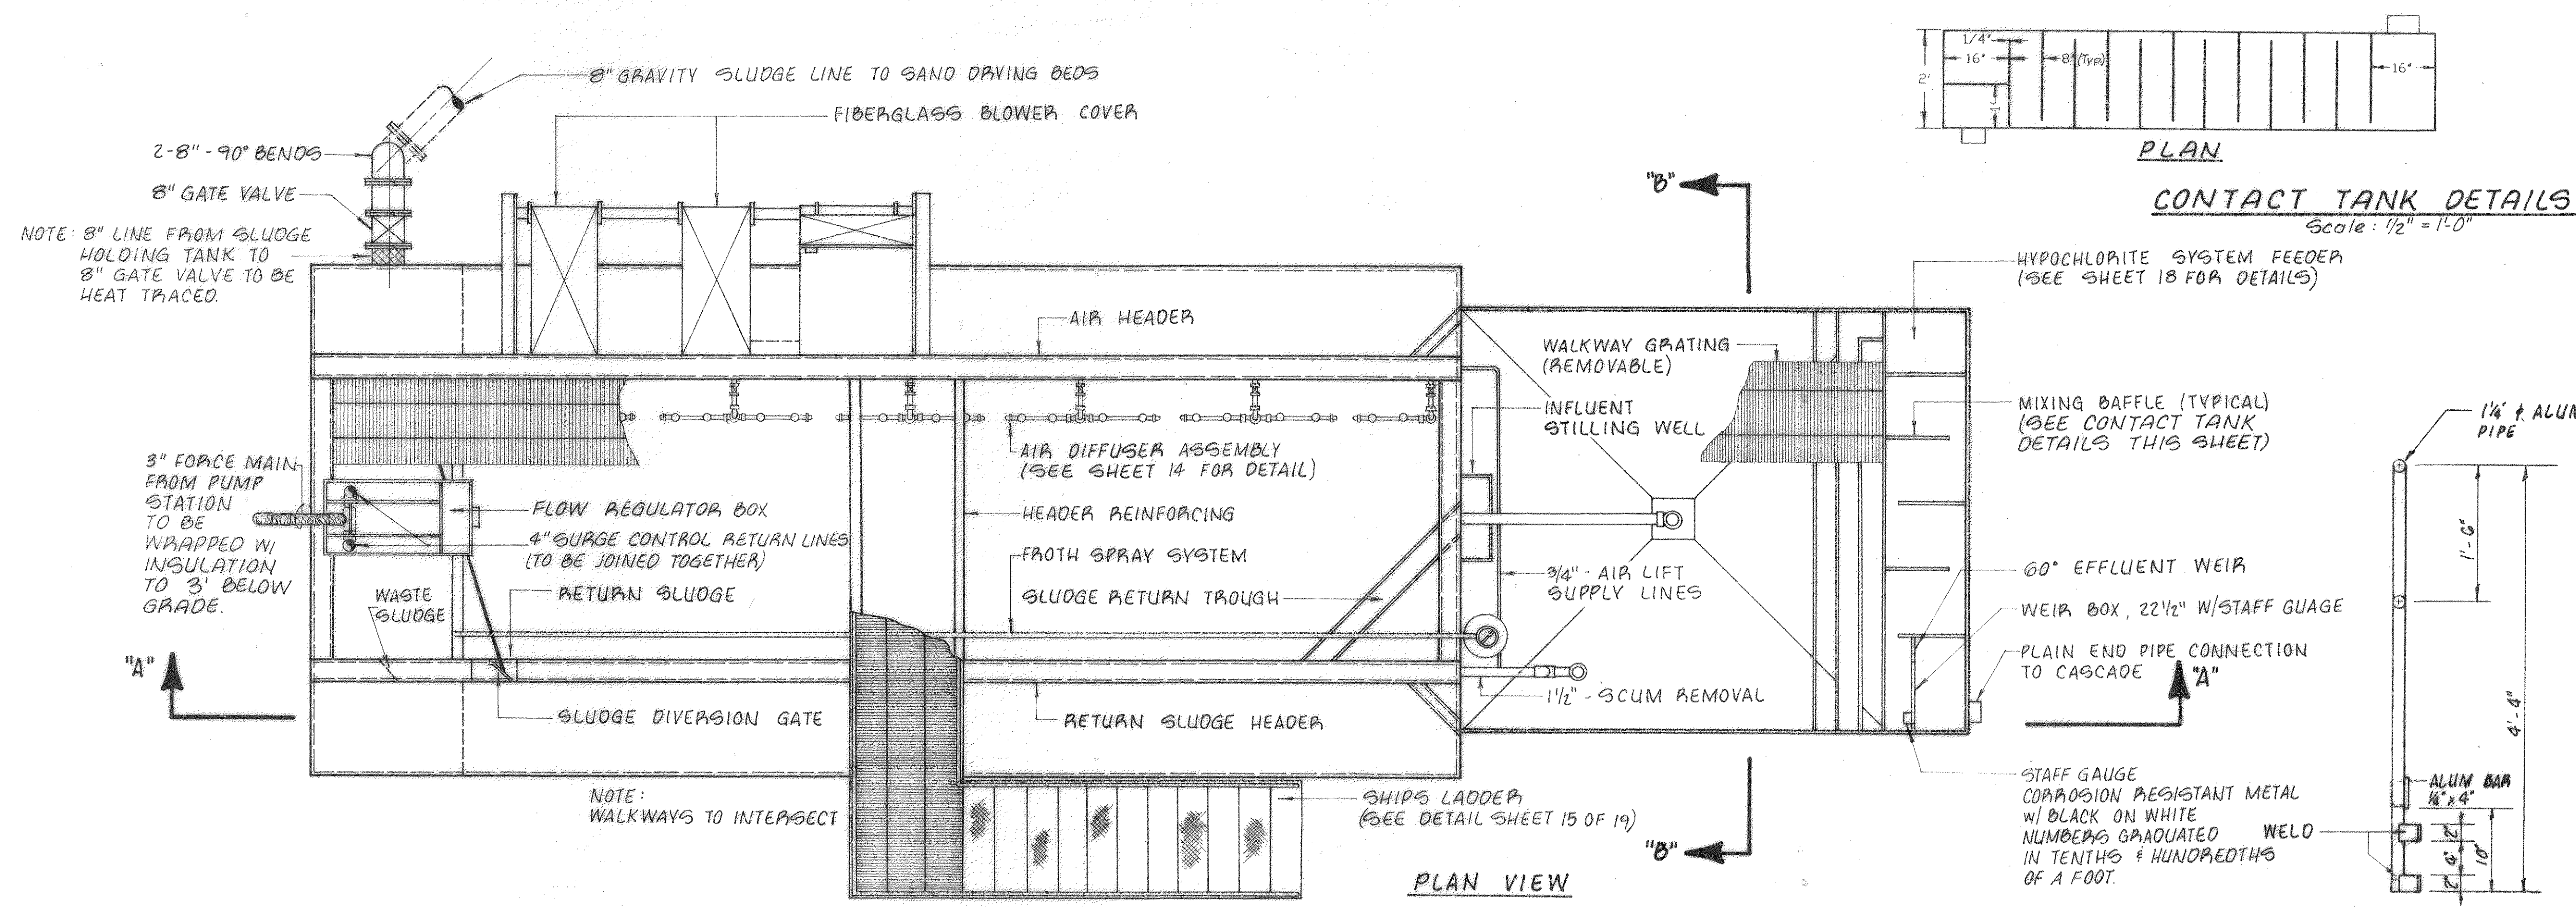


20,000 G.P.D. EXTENDED AERATION PACKAGE WASTEWATER TREATMENT PLANT
NOT TO SCALE

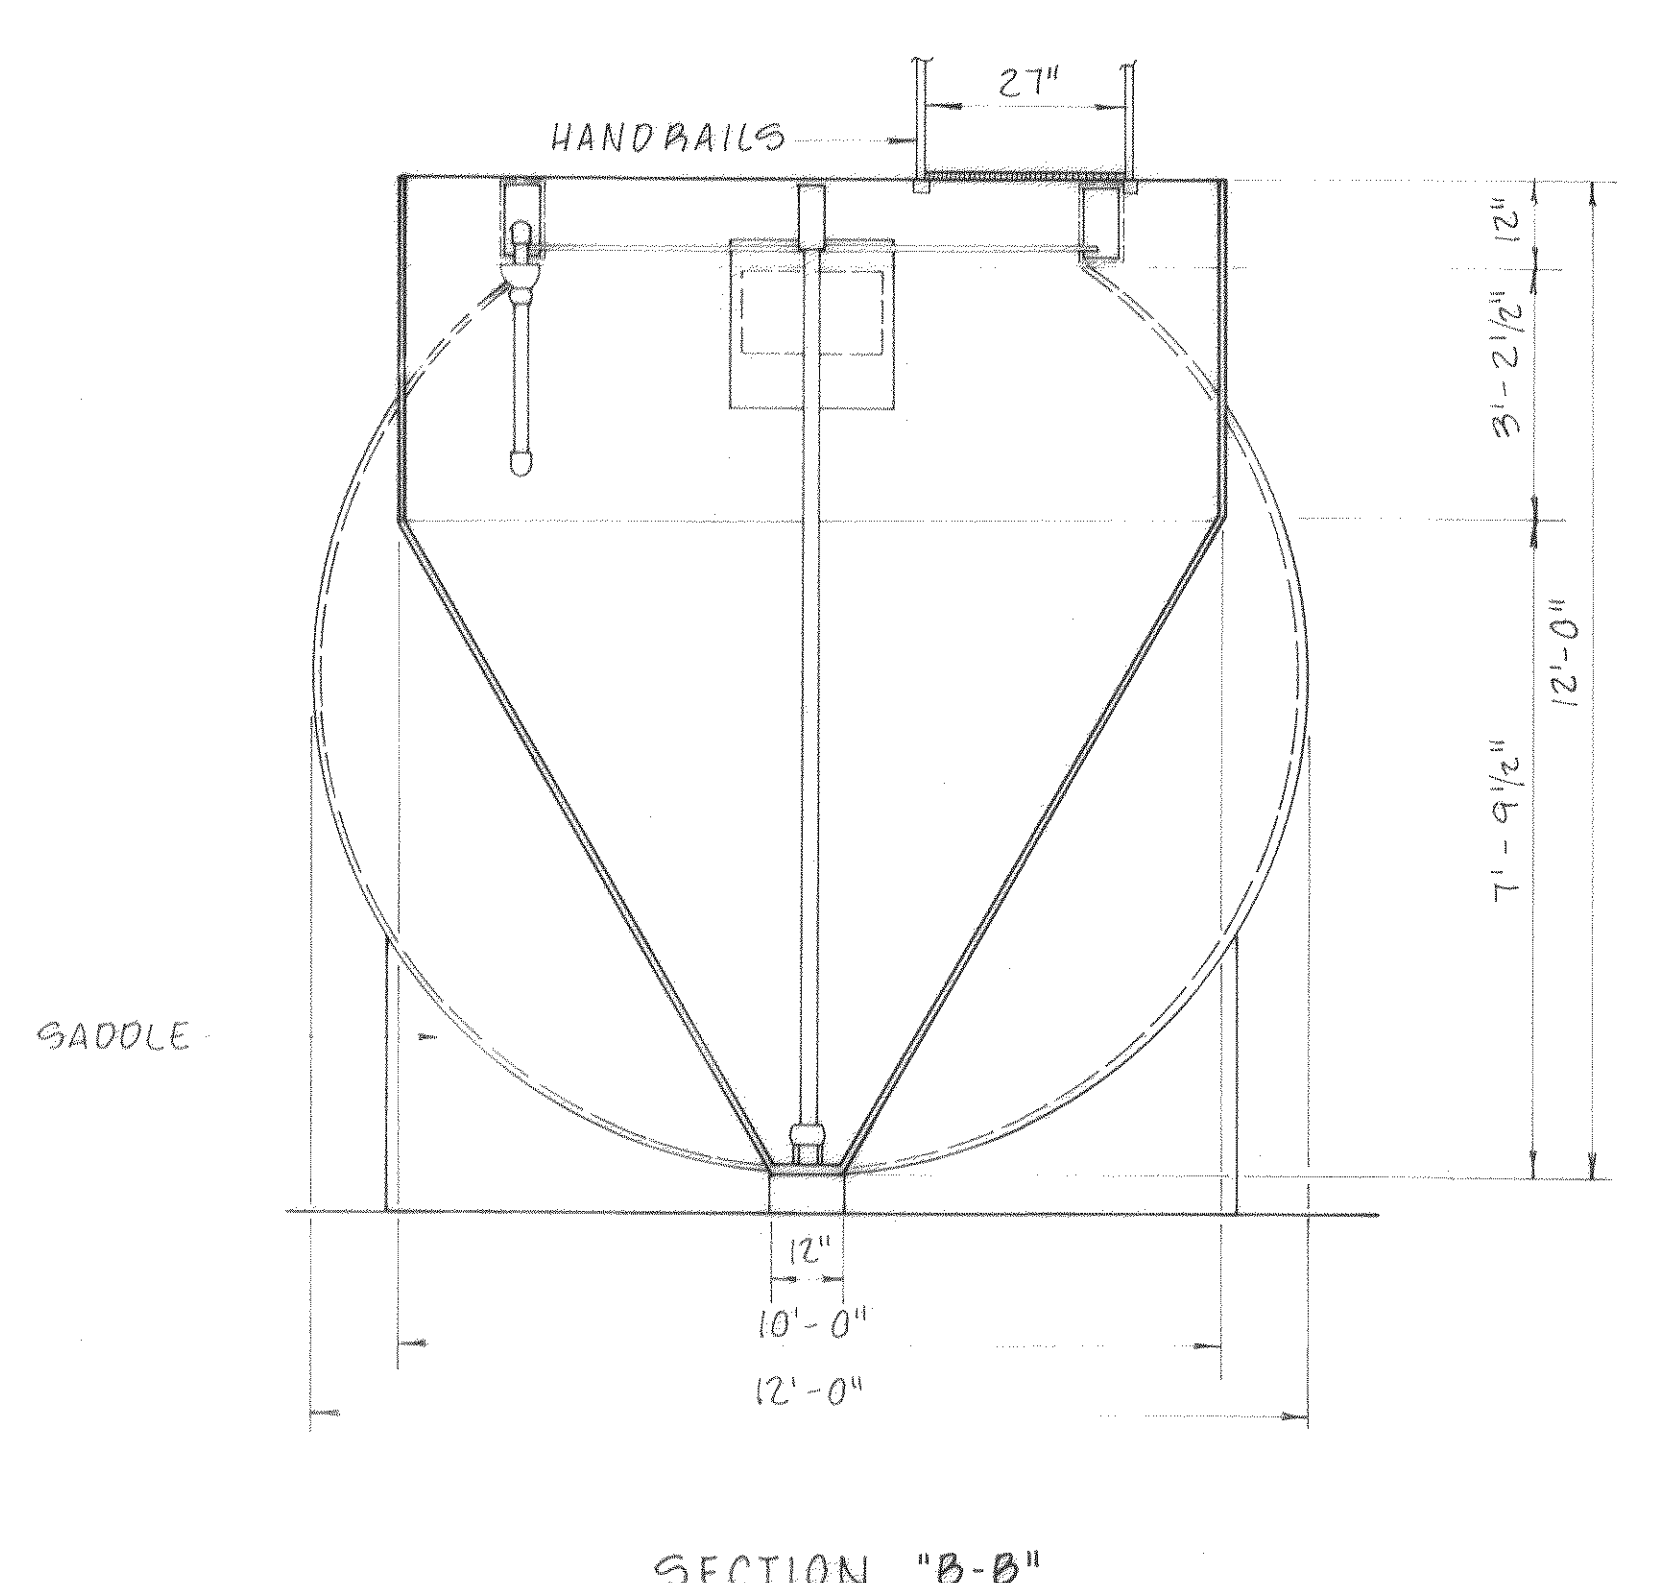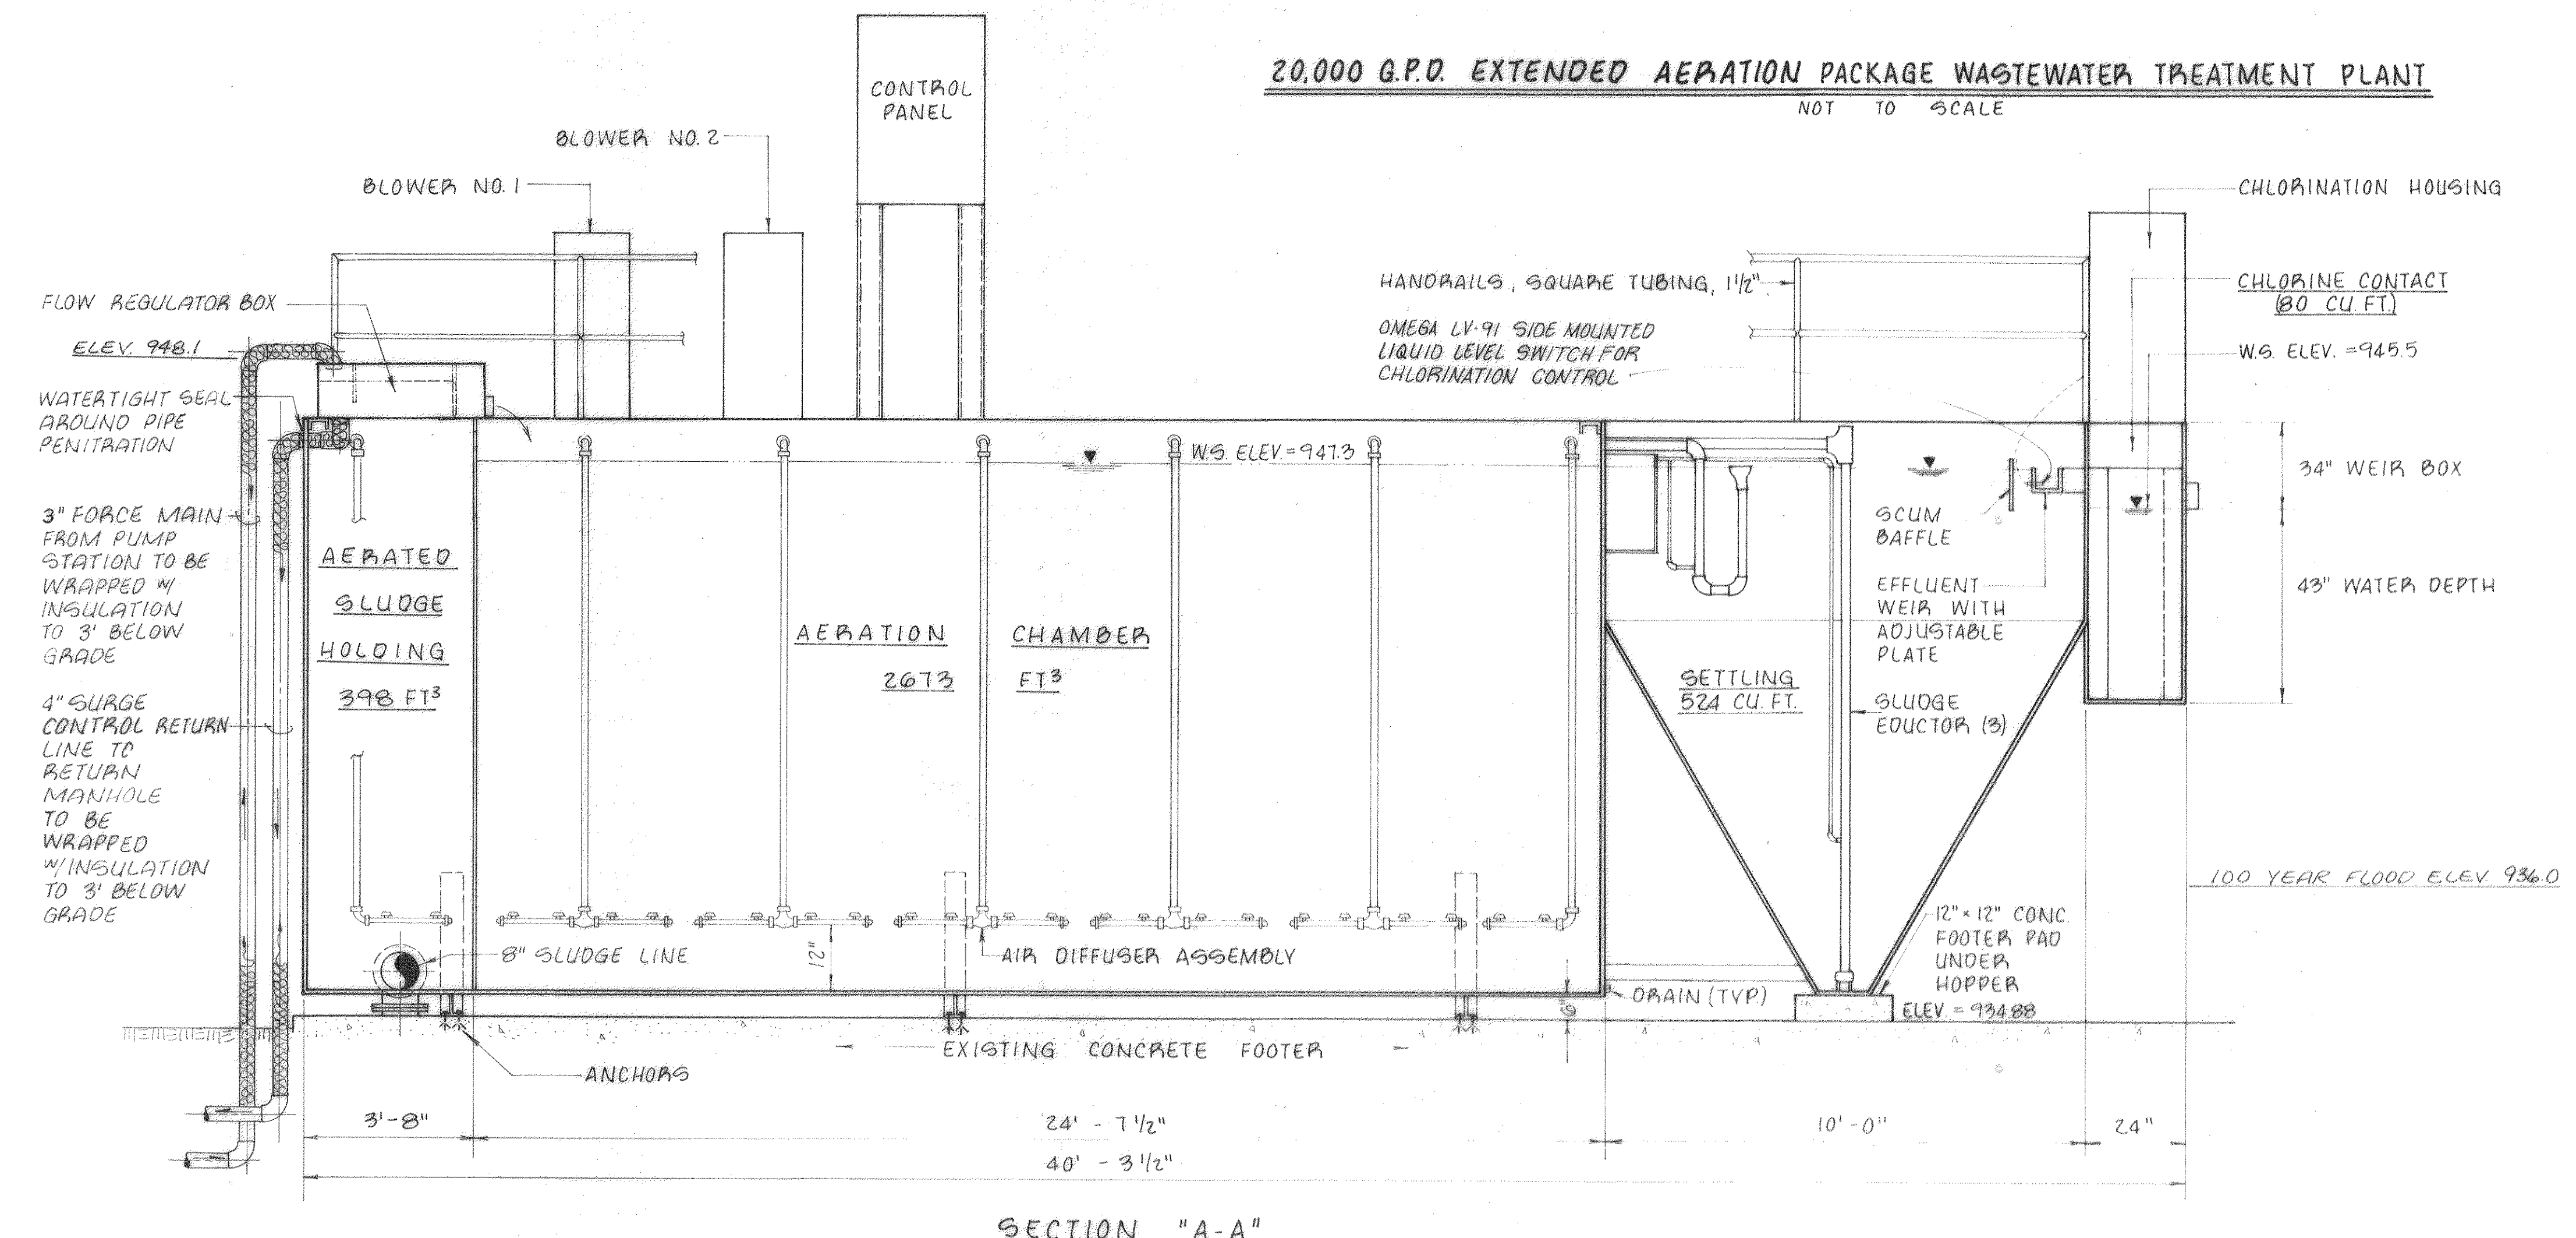

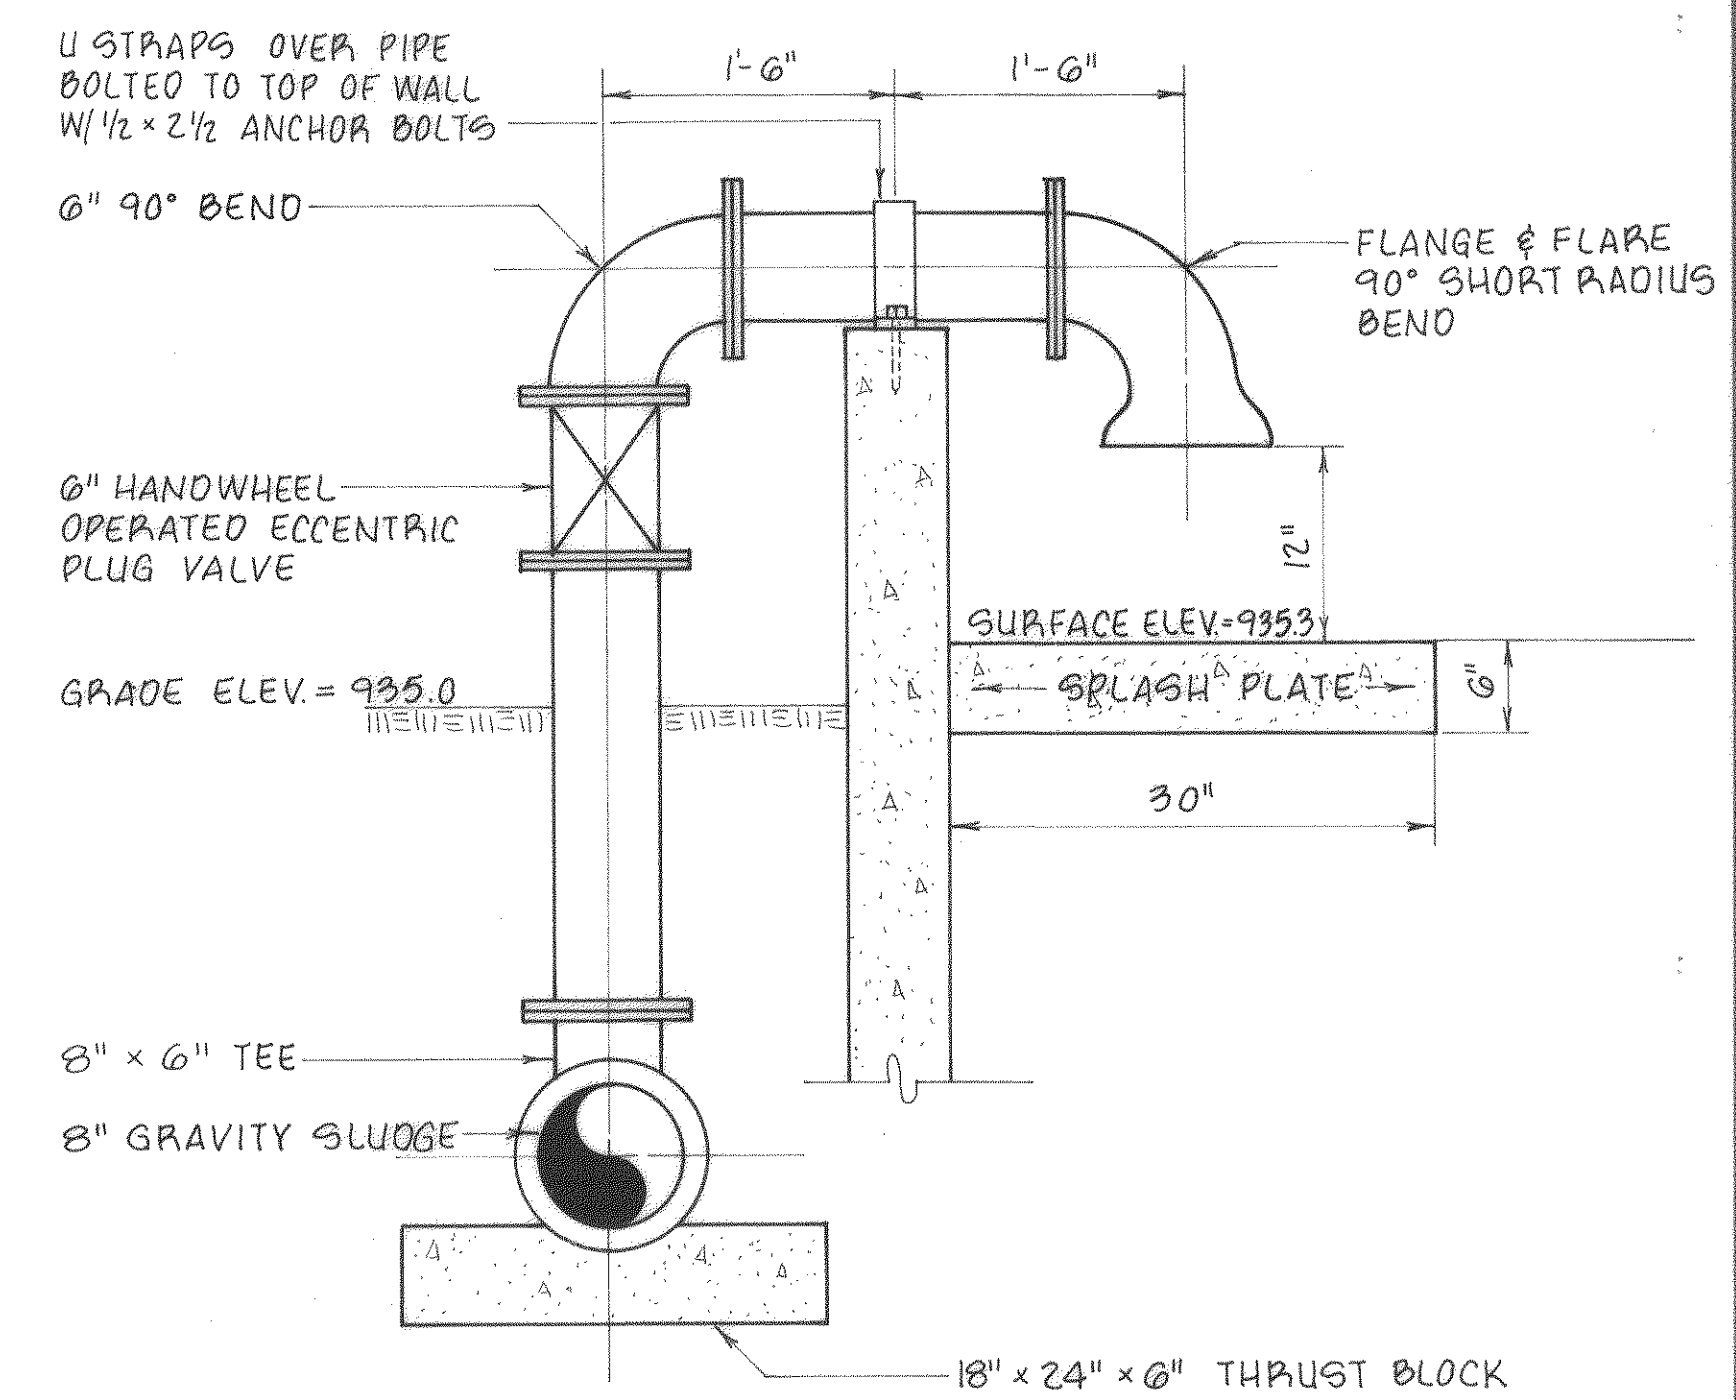


SLUDGE PIPING DETAIL
SCALE: 1"=1'-0"

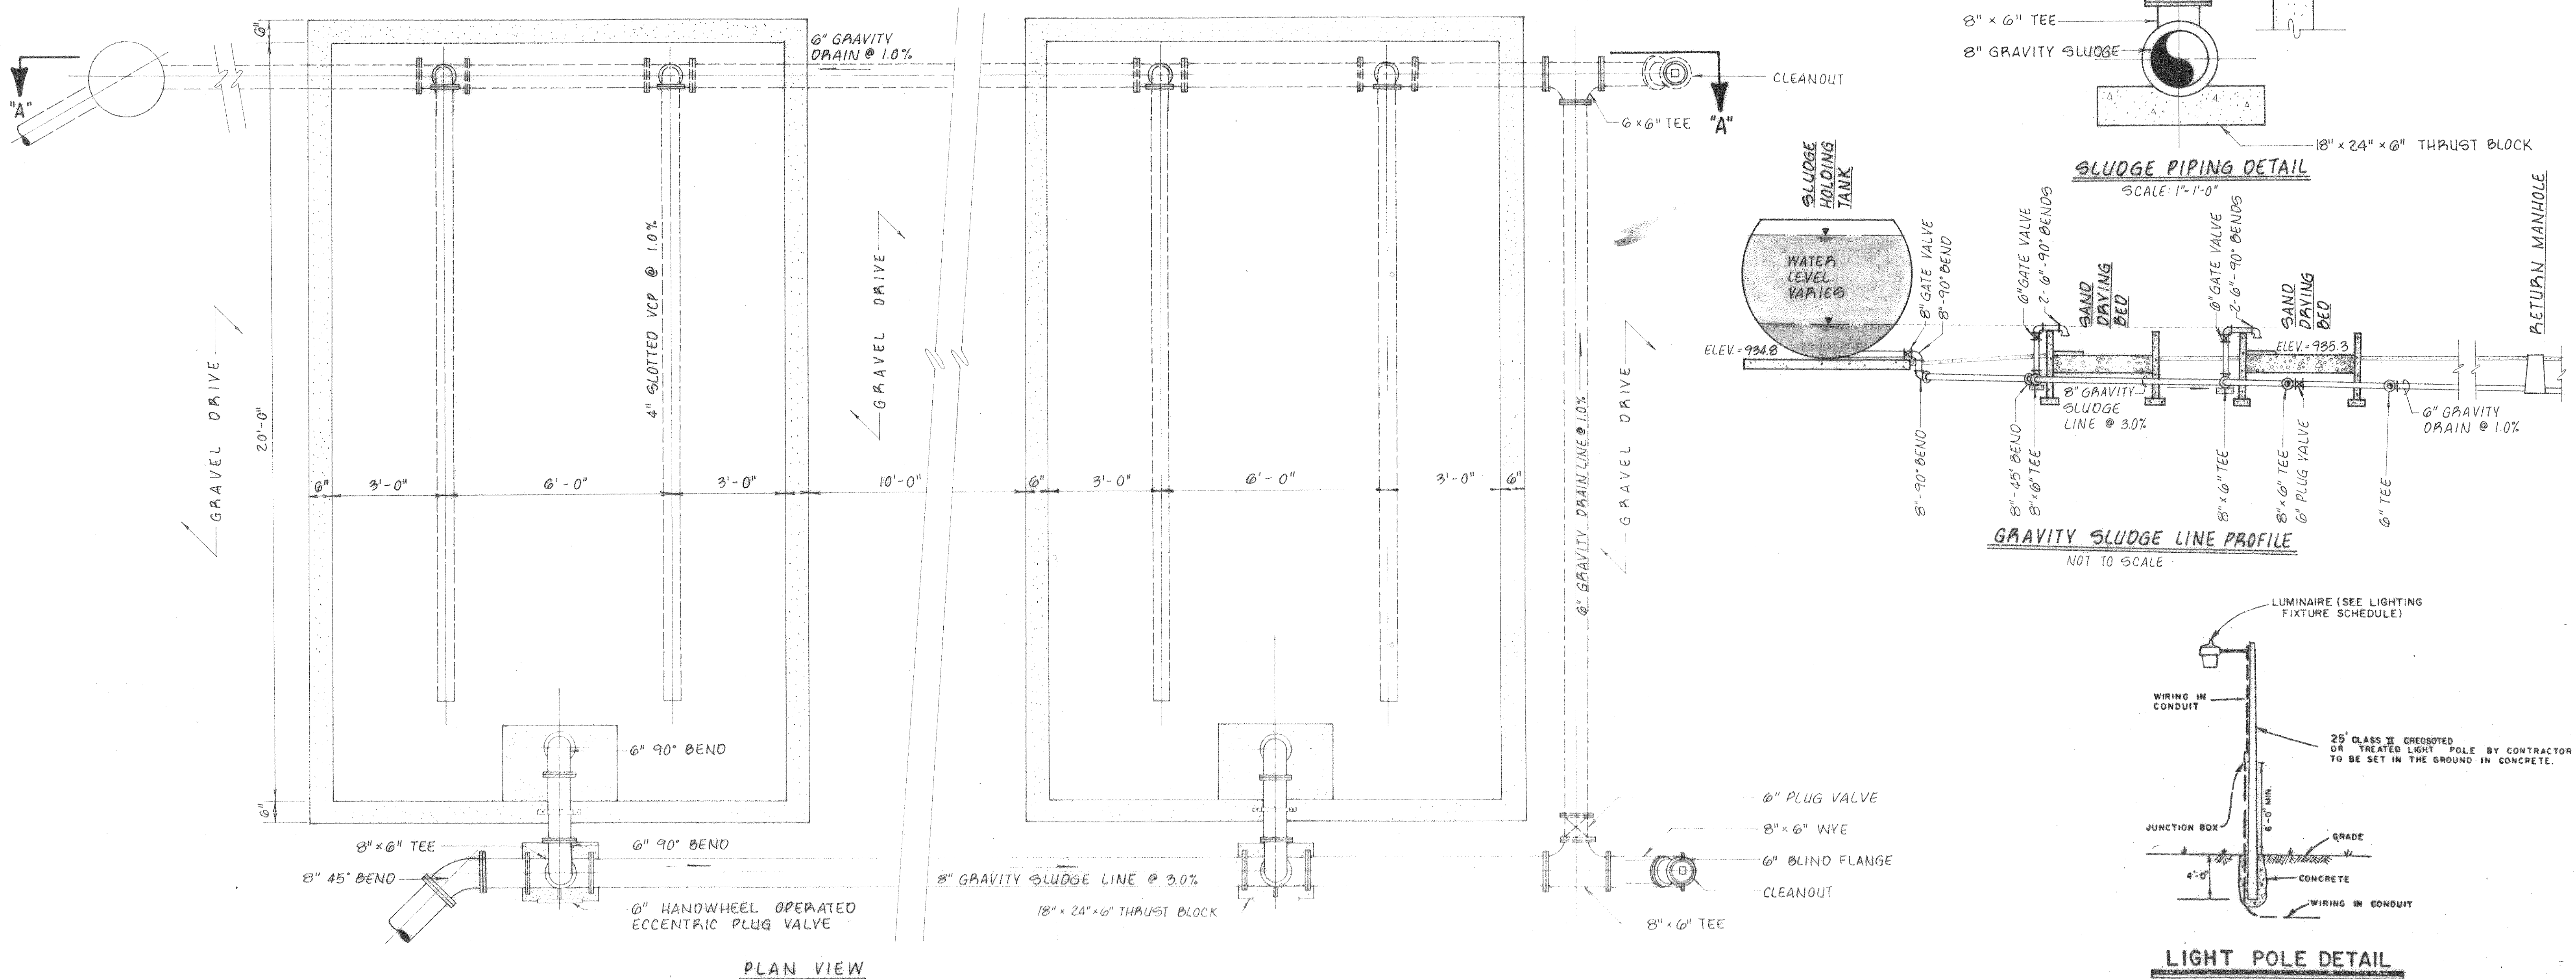


LIGHT POLE DETAIL

Sheet: 17 of 19
Scale: AS SHOWN
Date: DEC. 1987
Project: 86019

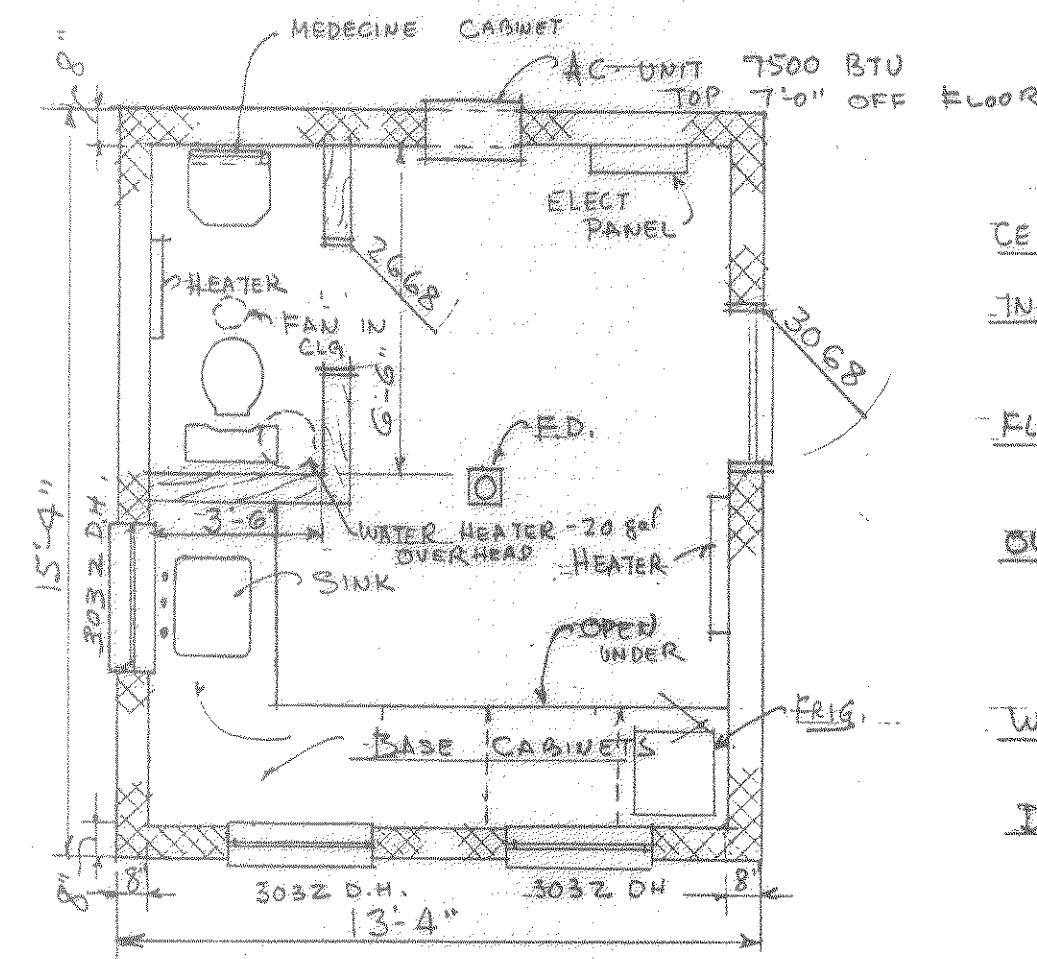


NOTES
 CEILING - 1/2" AC PLYWOOD
 6" FOIL BACKED INTOL.
 INSIDE TOILET WALLS
 2x4 STUBS @ 16" O.C.
 1/2" AC PLYWOOD BOTH SIDES
 FLOOR
 4" CONC. Gx6 Wx4 Hx1/4
 MESH ON 4 MILL POLY
 OF 4" STOVE FILL
 OUTSIDE WALLS
 8" LW. MASONRY UNITS
 SPLIT FACED FINISH
 COEF. AS NOTED
 FILL VOIDS WITH ZONOLITE
 WINDOWS ANDERSON D.H.
 BROWN CLAD
 INSULATED GLASS
 DOORS 2x6x8-1 1/8 MASONITE
 HOLLOW CORE WOOD FR.
 3x6x8-1 1/4 HM WITH
 HM FRAME

PLAN
1/4" = 1'-0"

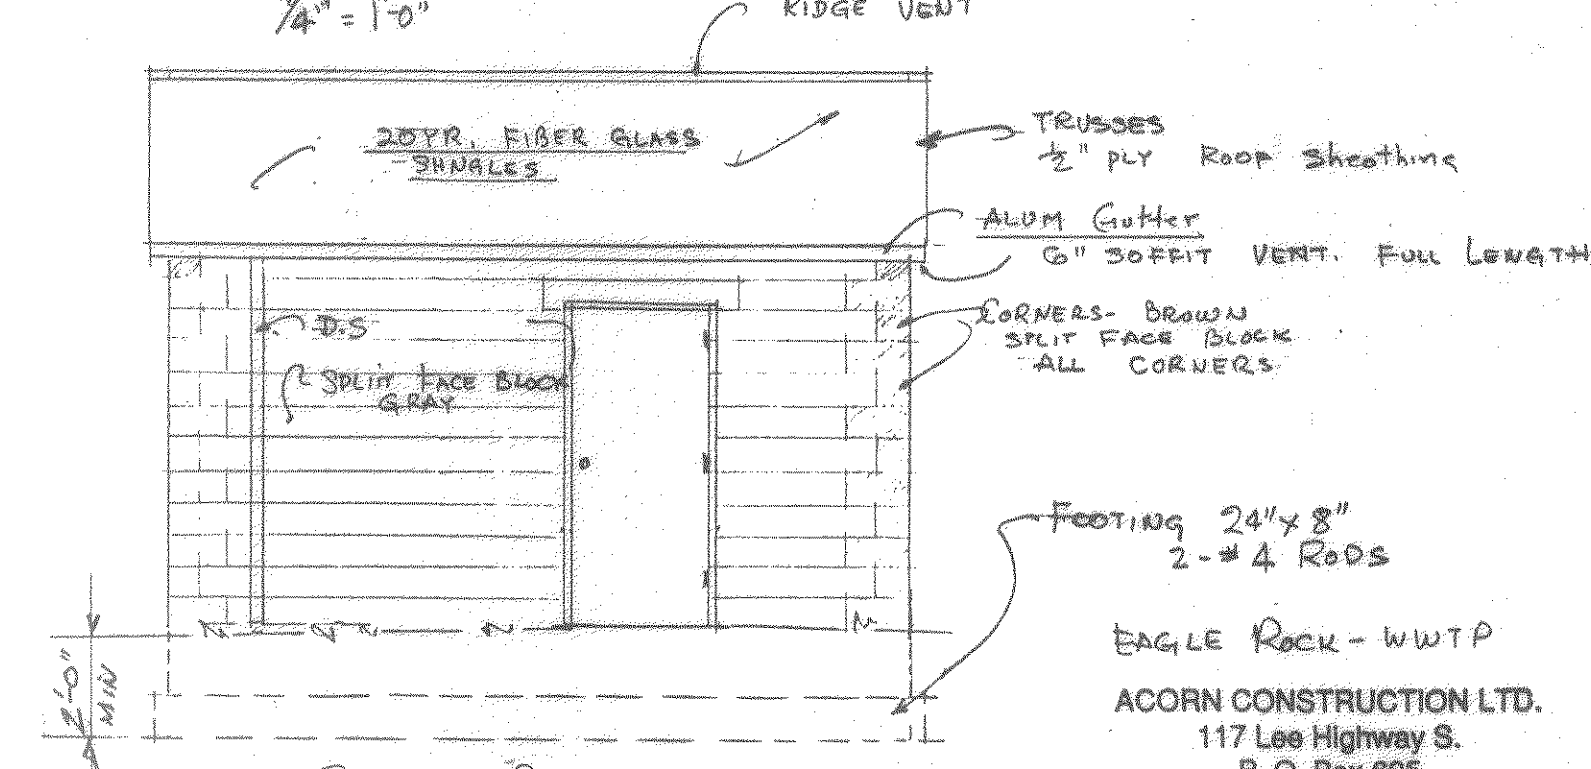


RIGHT SIDE
1/4" = 1'-0"

EAGLE ROCK - WWT P
 ACORN CONSTRUCTION LTD.
 117 Lee Highway S.
 P. O. Box 625
 Troutville, VA 24175
 8-20-91

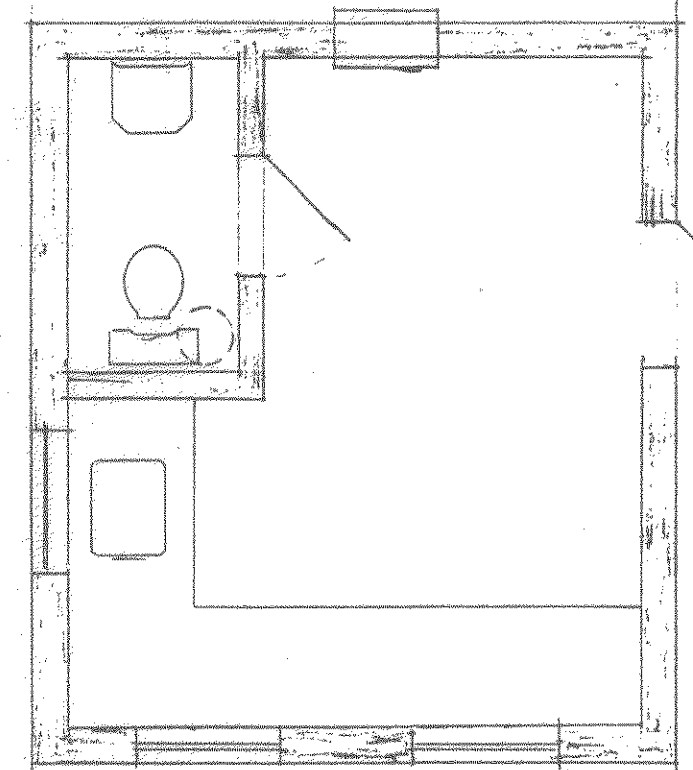

ELECTRICAL
1/4" = 1'-0"

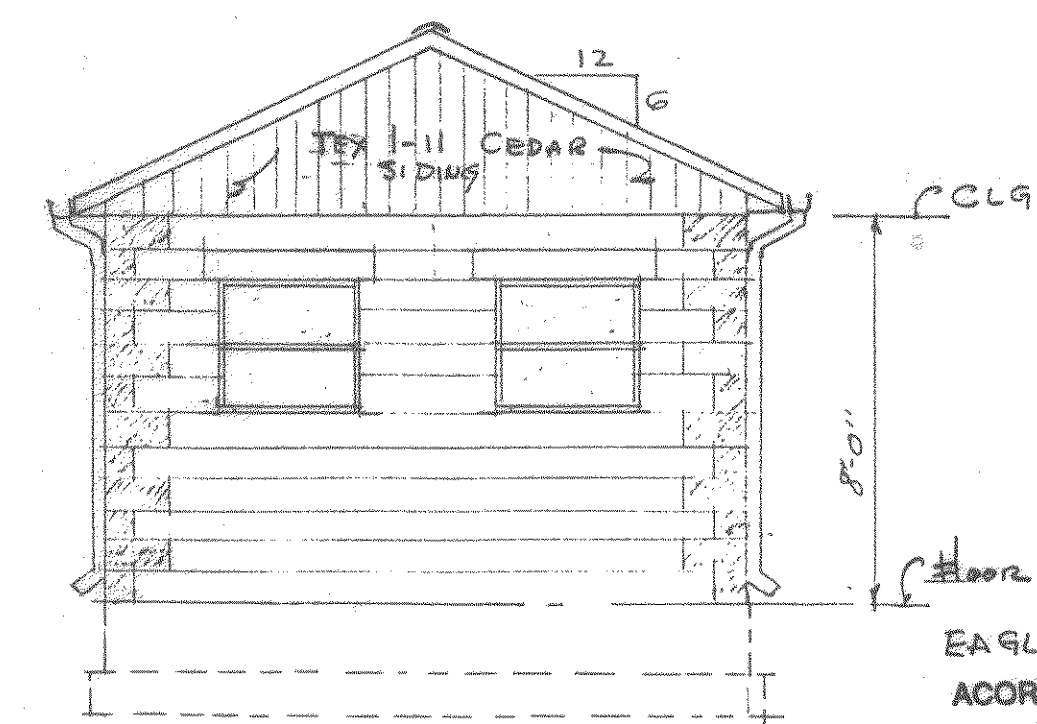

FRONT
1/4" = 1'-0"

EAGLE ROCK WWT P
 ACORN CONSTRUCTION LTD.
 117 Lee Highway S.
 P. O. Box 625
 Troutville, VA 24175
 8-20-91

CIRCUIT NO.	DESCRIPTION OF LOAD SERVED	SPACE NO.	BRKGR. NO.	WIRE SIZE	PHASE	AMPS	WIRE SIZE	BRKGR. NO.	SPACE NO.	DESCRIPTION OF LOAD SERVED	CIRCUIT NO.
1	3 HP (2) INFLUENT PUMPS	1	10	21	4A	40	21	10	2	3 HP (2) BLOWER MOTORS	2
3	LIGHTS ON POLES	7	10	12	2.5		21	10	6		
5	RECPTS. (Weatherstripped)	9	10	12	4.5		21	10	4	SPACE FOR FUTURE BLOWER MOTORS	4
7	UNIT HEATER 5 KW	11	10	14	14		21	10	12		
9	RECPTS. (Plug Strip)	17	10	12	1.5		21	10	16	IN-LINE WTA (2500 W)	6
11	RECPTS. (Plug Strip)	19	10	12	1.5		21	10	18	LTGS & EX FAN IN CTRL BLD	8
13	RECPTS. (Plug Strip)	21	10	12	1.5		21	10	20	EXTERIOR BLD LTGS	10
		23							22		
		25							24		
		27							26		
		29							28		
									30		

PANELBOARD (PBO) "MPB"

225 AMPS, 200A MN BRK, 120/208 VOLT, 3φ, 30 SPACES, NEMA 1, SURF MTO

ELECTRICAL NOTES AND SPECIFICATIONS


- INSTALLATION SHALL BE IN STRICT COMPLIANCE WITH THE NATIONAL ELECTRICAL CODE, AND MANIPULATES OF THE LOCAL BUILDING OFFICIALS.
- THE GENERAL ARRANGEMENT AND LOCATIONS OF LIGHT FIXTURES, EQUIPMENT, ETC. ARE INDICATED BY THE DRAWINGS AND SHALL BE INSTALLED IN ACCORDANCE THEREWITH, WITH THE EXCEPTION OF SUCH CHANGES WHICH MAY BE NECESSARY ON ACCOUNT OF OTHER TRADES. CONTRACTOR SHALL COORDINATE WORK WITH INSTALLATION OF OTHER SUBCONTRACTORS AND OWNER SUPPLIED EQUIPMENT AND FURNISHINGS.
- ELECTRICAL WORK SHALL BE COORDINATED WITH THE GENERAL CONTRACTOR AS TO SCHEDULING, DIMENSIONING AND LOCATION OF EQUIPMENT.
- MAJOR ITEMS ARE SHOWN ON THE PROJECT PLANS. SUBCONTRACTOR SHALL BE RESPONSIBLE FOR ALL INCIDENTAL ITEMS REQUIRED TO PROVIDE A COMPLETE AND FUNCTIONAL SYSTEM.
- WIRE SHALL BE COPPER OF MINIMUM OF 12 GAUGE SIZE AND SHALL BE TYPE THW, THWN, THHN, RH OR RHW AND STRANDED IF NUMBER 8 AWG OR LARGER.
- ALL WIRING SHALL BE IN CONDUIT. RIGID METAL WHERE EXPOSED BELOW SWITCH HEIGHT, EMT ABOVE SWITCH HEIGHT OR IN CONCEALED LOCATIONS, FLEXIBLE CONDUIT FOR MOTOR CONNECTIONS AND PVC SCHEDULE 40 FOR UNDERGROUND APPLICATIONS.
- ALL CONDUIT SYSTEMS, EQUIPMENT CASES, MOTOR FRAMES AND SYSTEM NEUTRAL CONDUCTORS SHALL BE PERMANENTLY AND EFFECTIVELY GROUNDED IN ACCORDANCE WITH NATIONAL ELECTRICAL CODE, ARTICLE 250.
- INSTALLATION OF LIGHT FIXTURES SHALL BE COORDINATED WITH CEILING LAYOUT, STRUCTURAL MEMBERS AND ADJACENT FINISHES.
- INSTALL CONDUITS WITH NO MORE THAN THREE CURRENT CARRYING CONDUCTORS PLUS A NEUTRAL CONDUCTOR, PLUS A GROUND CONDUCTOR WHERE REQUIRED.
- WHERE MORE THAN THREE CURRENT CARRYING CONDUCTORS ARE CONTAINED IN A SINGLE CONDUIT, ADJUST CONDUCTOR SIZES AS NECESSARY TO ACCOUNT FOR DE-RATING THEIR AMPACITY IN ACCORDANCE WITH THE NATIONAL ELECTRICAL CODE.
- ELECTRICAL SUBCONTRACTOR SHALL BE RESPONSIBLE FOR INSTALLATION OF POWER WIRING TO ALL EQUIPMENT.
- ELECTRICAL SUBCONTRACTOR RESPONSIBLE FOR COORDINATING AND OBTAINING 3 PHASE SERVICE FROM ELECTRIC POWER COMPANY FOR 120/208 VOLT, 3 PHASE 4W Wye.
- CONDUIT TO BE RUN CONCEALED WITHIN CONTROL BUILDING WITH THE EXCEPTION OF WIRING AT THE MAIN SURFACE MOUNTED SWITCHGEAR.
- TELEPHONE OUTLETS SHALL BE EQUIPPED WITH 2-1/8" X 4" X 2-1/8" DP. WALL BOX AND COVERED WITH EMPTY 3/4" CONDUIT EXTENDED CONCEALED IN WALL TO AN ACCESSIBLE LOCATION ABOVE THE CEILING.
- WIRING DEVICES TO BE AS SCHEDULED BELOW:

DEVICE	MARK	DESCRIPTION
DUPLEX RECEPTACLE	⊕	20 A SPECIFICATION GRADE, BROWN WITH #302 S.S. PLATES IN CONTROL BUILDING AND GALV. PLATES OTHERWISE
SWITCHES	⊕	20 A, SIDEWIRE, SPECIFICATION GRADE, BROWN WITH #302 S.S. PLATES IN CONTROL BUILDING AND GALV. PLATES OTHERWISE.
TELEPHONE OUTLET	▽	#302 S.S. COVER WITH SINGLE CENTER HOLE, 2-1/8" X 4" X 2-1/8" BACK BOX & EMPTY 3/4" CONDUIT TO ACCESSIBLE LOCATION.
TWO POLE	⊕	AS REQUIRED TO SUIT EQUIPMENT REQUIREMENTS.
WEATHERPROOF RECEPTACLE	⊕ WP	RUBBER 5206ND CAST ALUMINUM WITH TYPE F.S. BOX
ALL SAFETY SWITCHES TO BE SIMILAR OR EQUAL TO SQUARE D, HEAVY DUTY H SERIES		
ALL PANELBOARDS TO BE SIMILAR OR EQUAL TO SQUARE D SERIES NQOD WITH BOLT ON TYPE CIRCUIT BREAKERS.		
ENGRAVED PLASTIC LAMINATE IDENTIFICATION PLATES SHALL BE PROVIDED FOR ALL DISCONNECT SWITCHES, PANELBOARDS, USING ENGRAVERS STOCK MELAMINE PLASTIC, BLACK WITH 1/3" HIGH WHITE CORE LETTERING. CONTRACTOR TO SUBMIT SCHEDULE OF INTENDED LABELING PRIOR TO ORDERING NAME PLATES.		

EQUIPMENT SCHEDULE

ITEM	MANUFACTURER	MODEL NO.	ITEM	MANUFACTURER	MODEL NO.
Laboratory	Fisher Scientific		Water Heater	Sears, Roebuck & Co.	35 gallon
Bench (1)		97-750-Q	Ceiling Tile	Owens/Corning	Pin Perforated 5/8" x 12" x 12"
Bench (1)		97-69A-B	Lavatory	American Standard	F350-40 With N2141-8 Trim and Towel Racks on Slides
Bench (2)		97-325-Q	Lighting	1. Lithonia	L240, #2, 40 watts, type F40, 120 Volts, surface mounting, std. industrial with reflector
Bench (1)		97-250-Q		2. Sylvania	AK3-P-70HPS, 120-W-PC, #1 70 watts, Type HPS, 120 volts, wall mounting, built in photocell on blower bldg. on vert. wall mount
Counter Top		Proxyn-Stycos-Lipped		3. Lithonia	LR440, #4, 40 Watts, Type F40, 120 volts, surface mounting, low profile, wraparound, 15-3/8" wide
File Cabinet (1)		91-241		4. Brown	Model 657, #1, 100 Watts, Incandescent, 120 Volts, Recessed, 70 CFM fan, 4" diameter duct discharge
Desk Chair (2)		91-225		5. Prescolite	Model CPX-4, #1, 75 watts, Incandescent, 120 volts, surface mounting, cast aluminum, Lexan lens, Gasketed
Refrigerator		13-988-105	Yard Light	Sylvania	MTN-150 HPS, SP-230-A259-A363, #1, 150 Watts, Type HPS, 230 volts, pole mounting, built in photocell, 22" aluminum mast arm
Toilet Shower	American Standard	"Cadet" F-2122-11			
	Cutler Metal Products	A32T-32"x32"x8" with Curtain			
Front Door	Fenestra	Presidential* 3068-GJ			
Interior Door	Georgia Pacific	"Vinyl Shield" Maple Left Hand Swing 1-3/8"x2'-4"x6'-8" and Jamb			
Heater-Thru Wall Unit	Carrier	52ARAS143RC, 14 HPS CLG, 520 Elec. Heat, 240V, remote control thermostat, wall sleeve, architectural wall grille, Type "C" receptacle, wall thermostat			
Back Flow Preventer	Watts Regulator	1" Model 909			
Windows	Andersen	Aswing 4'x4', Type A-42			

NOTE: CONTROL BUILDING WAS DESIGNED AND CONSTRUCTED BY ACORN CONSTRUCTION LTD. IN AGREEMENT WITH BOTETOUR CO. PUBLIC WORKS DIRECTOR BONNIE NEWLON.

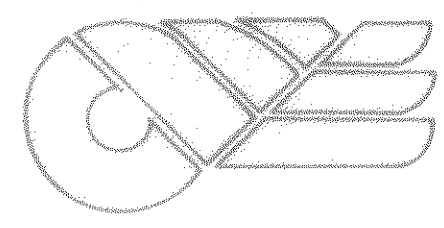

CLEAN WATER ENGINEERS, INC.
















P.O. BOX 218
 FINCASTLE, VIRGINIA 24090

COMMUNITY OF EAGLE ROCK
 WASTEWATER COLLECTION AND TREATMENT SYSTEM
 BOTETOURT COUNTY, VIRGINIA

CONTRACT I
 "AS BUILT"

REVISIONS		
NO.	DATE	BY

DESIGNED: JAF	SHEET: 18 OF 19
DRAWN: TAP	SCALE: AS SHOWN
CHECKED: JAF	DATE: JUNE, 1991
APPROVED: DJR	PROJECT: 86019

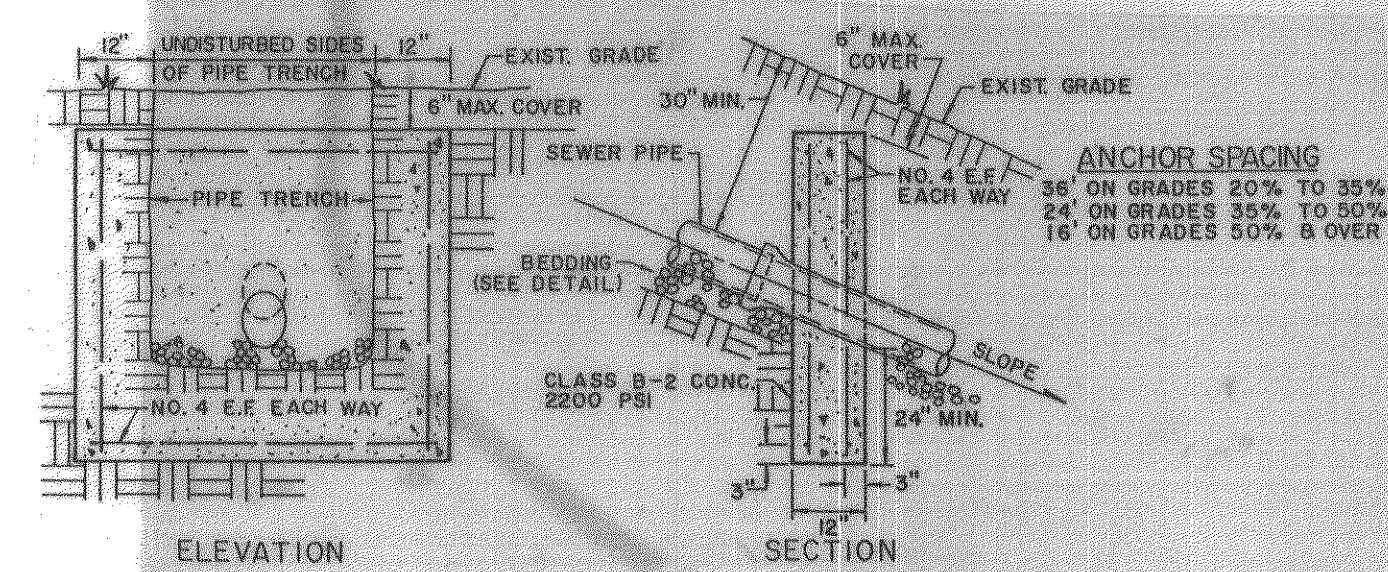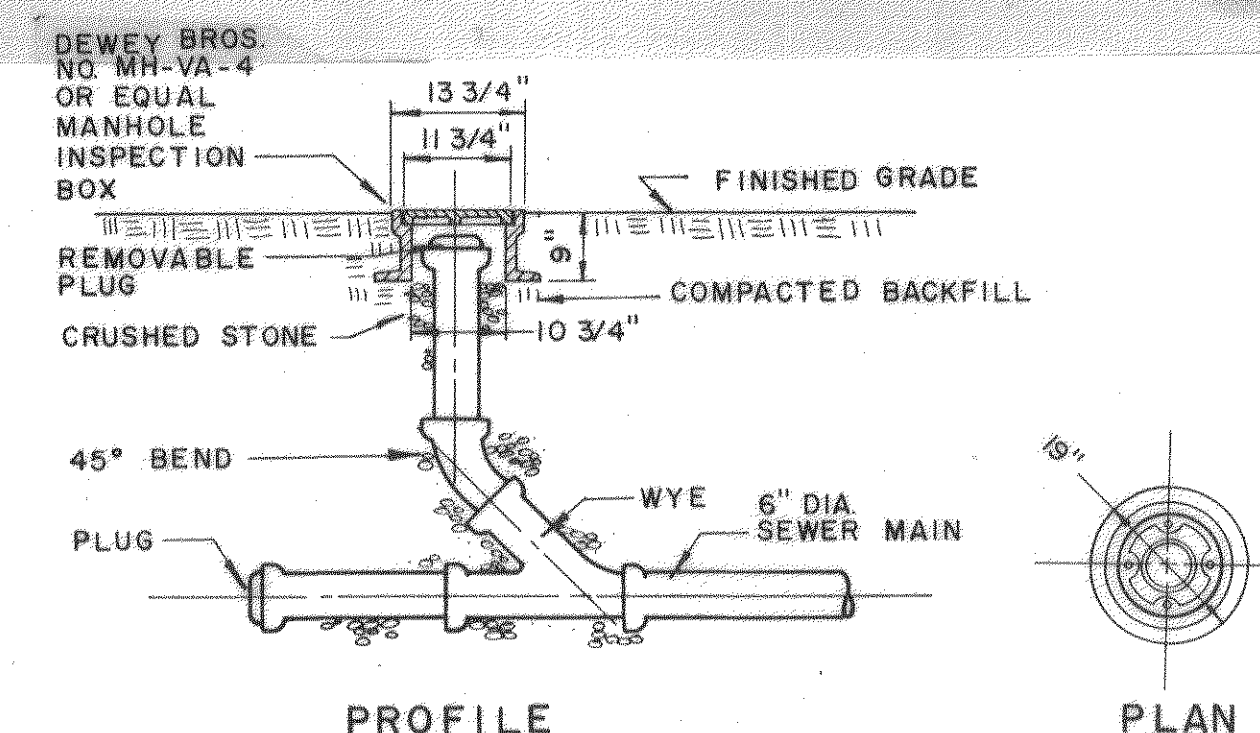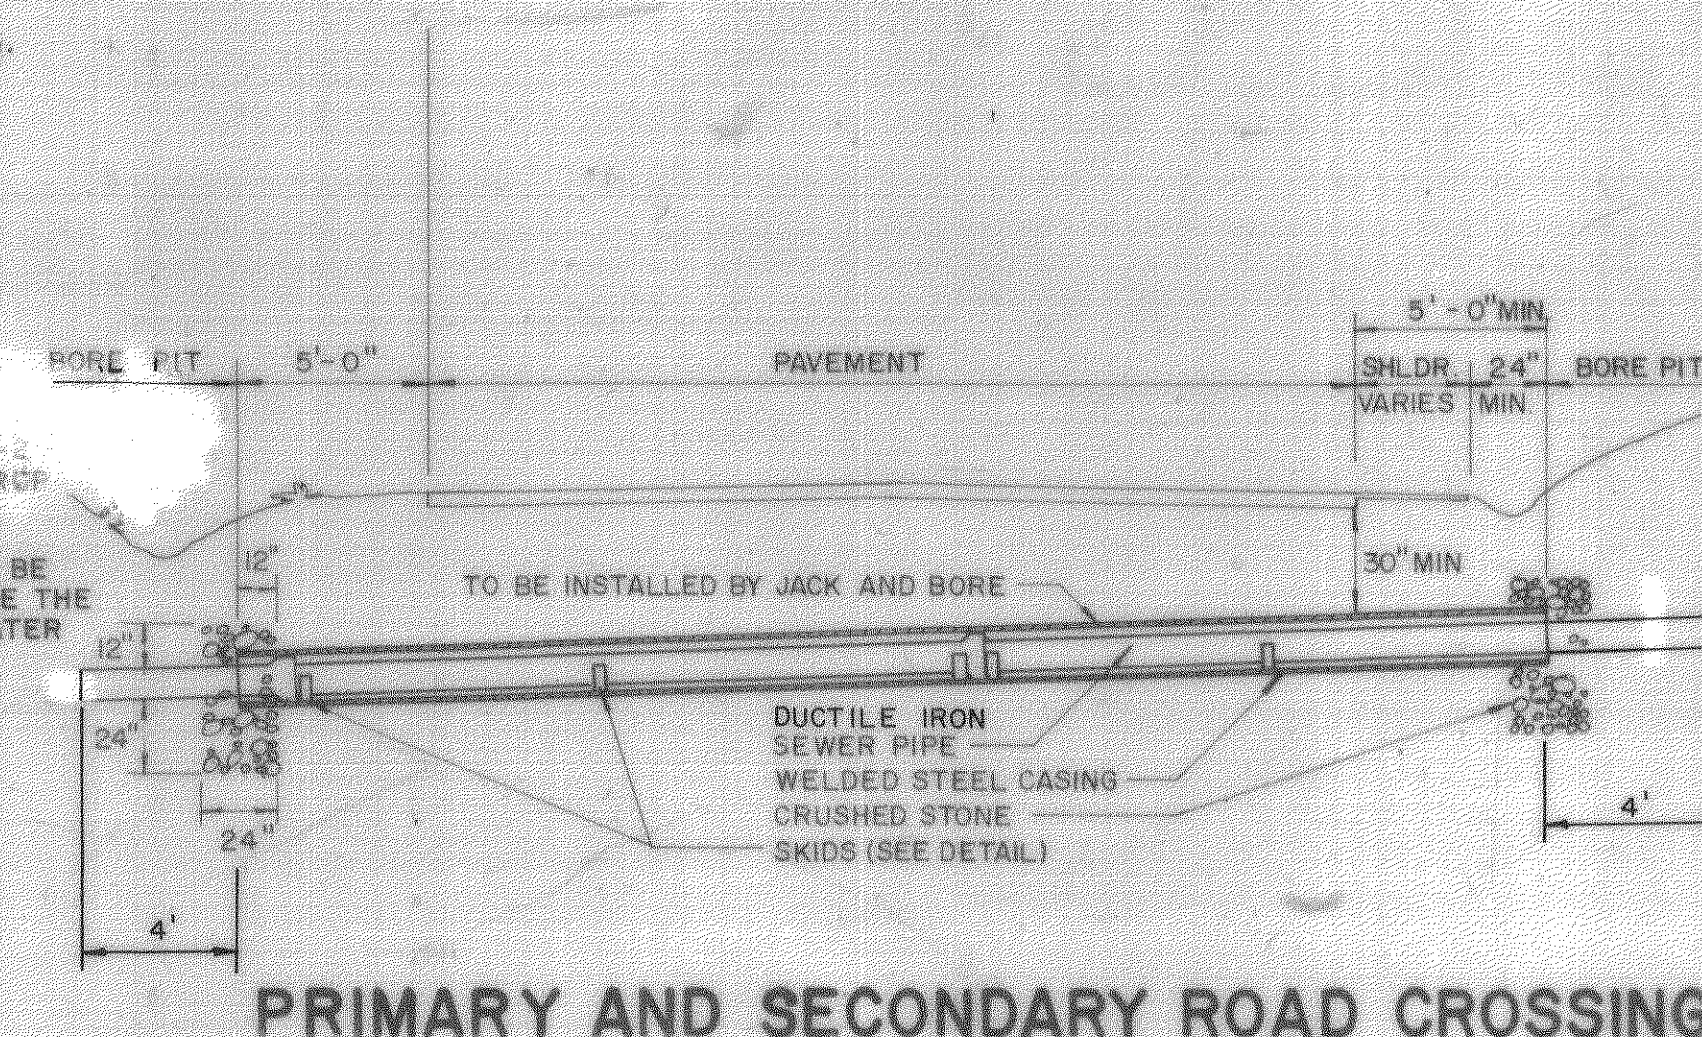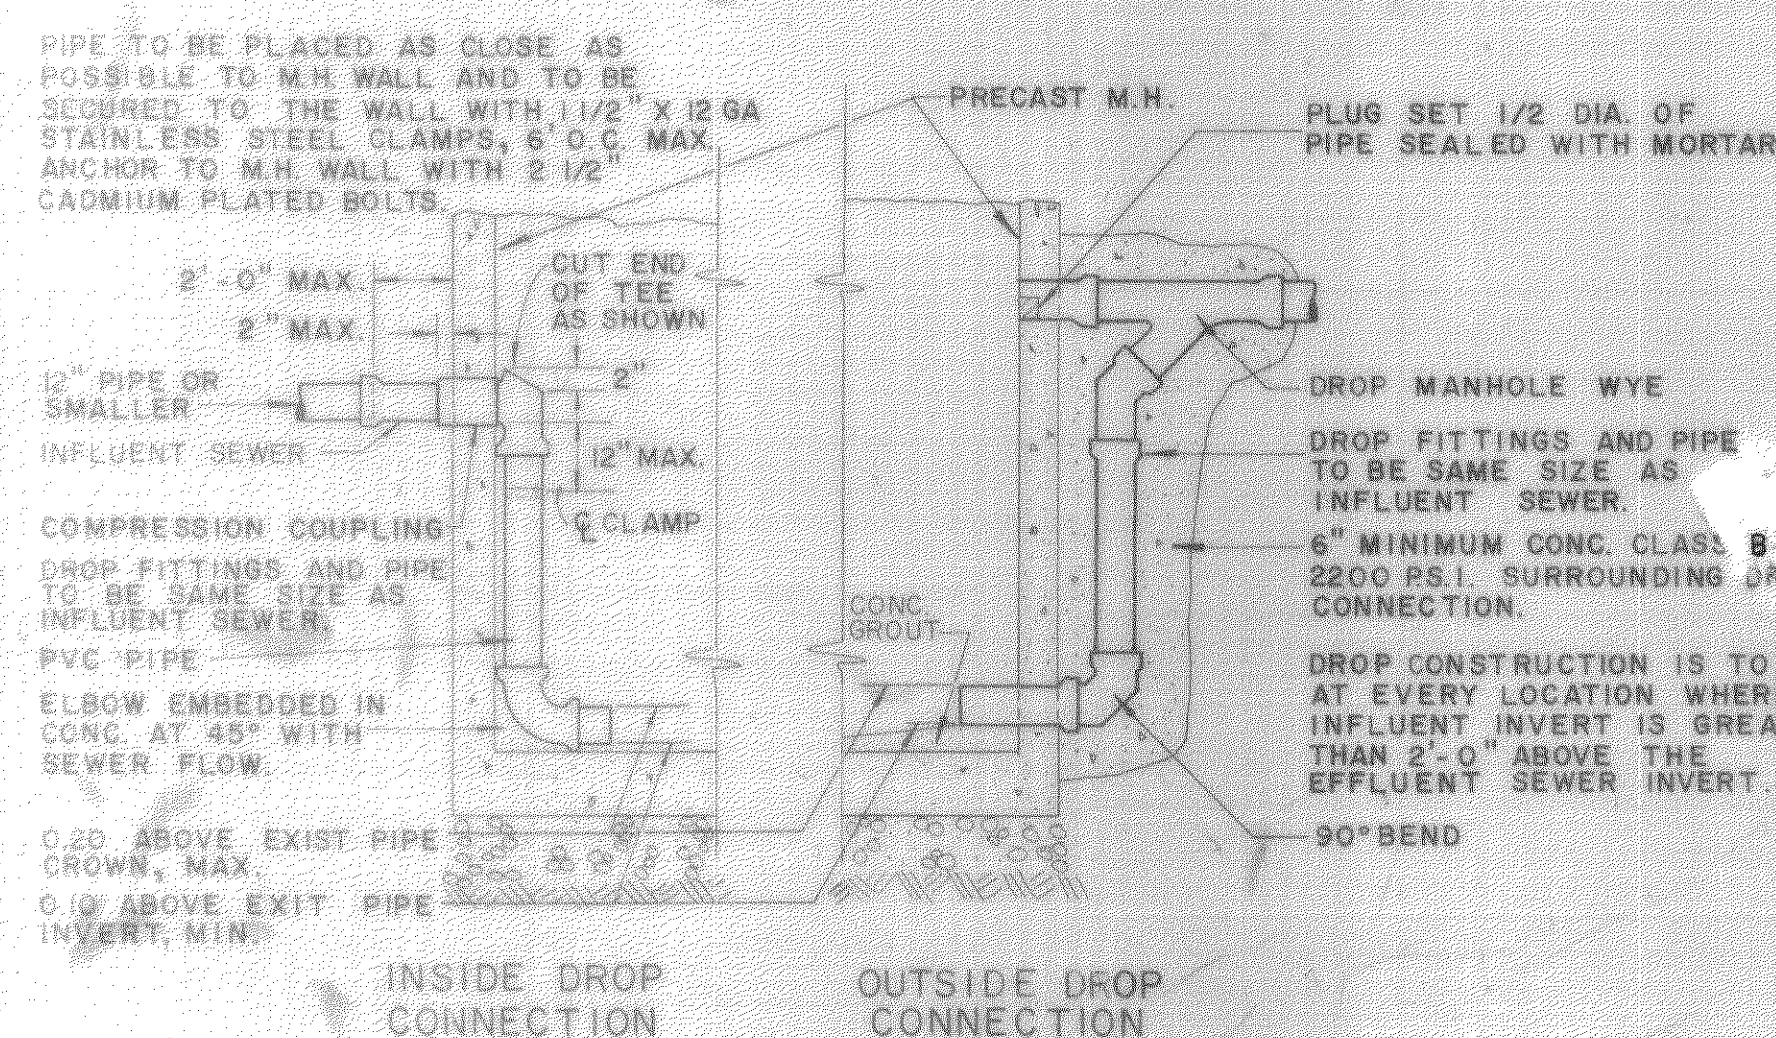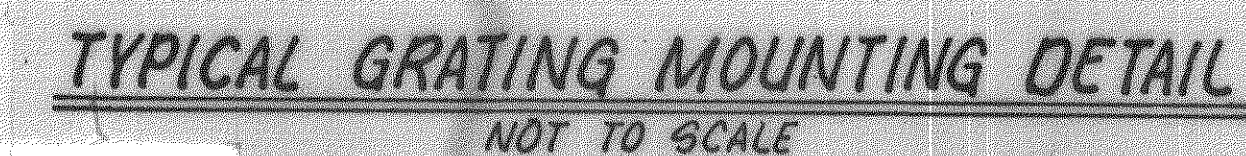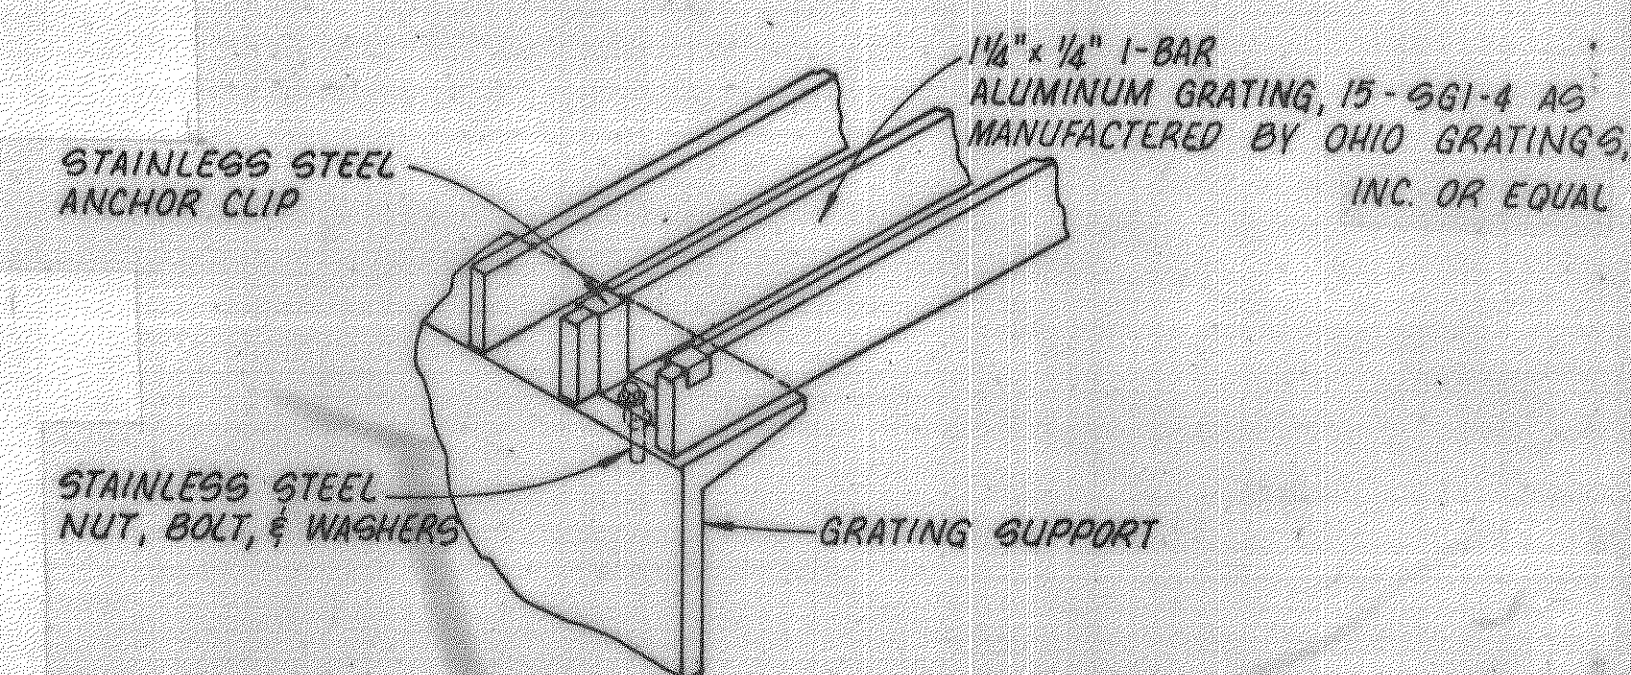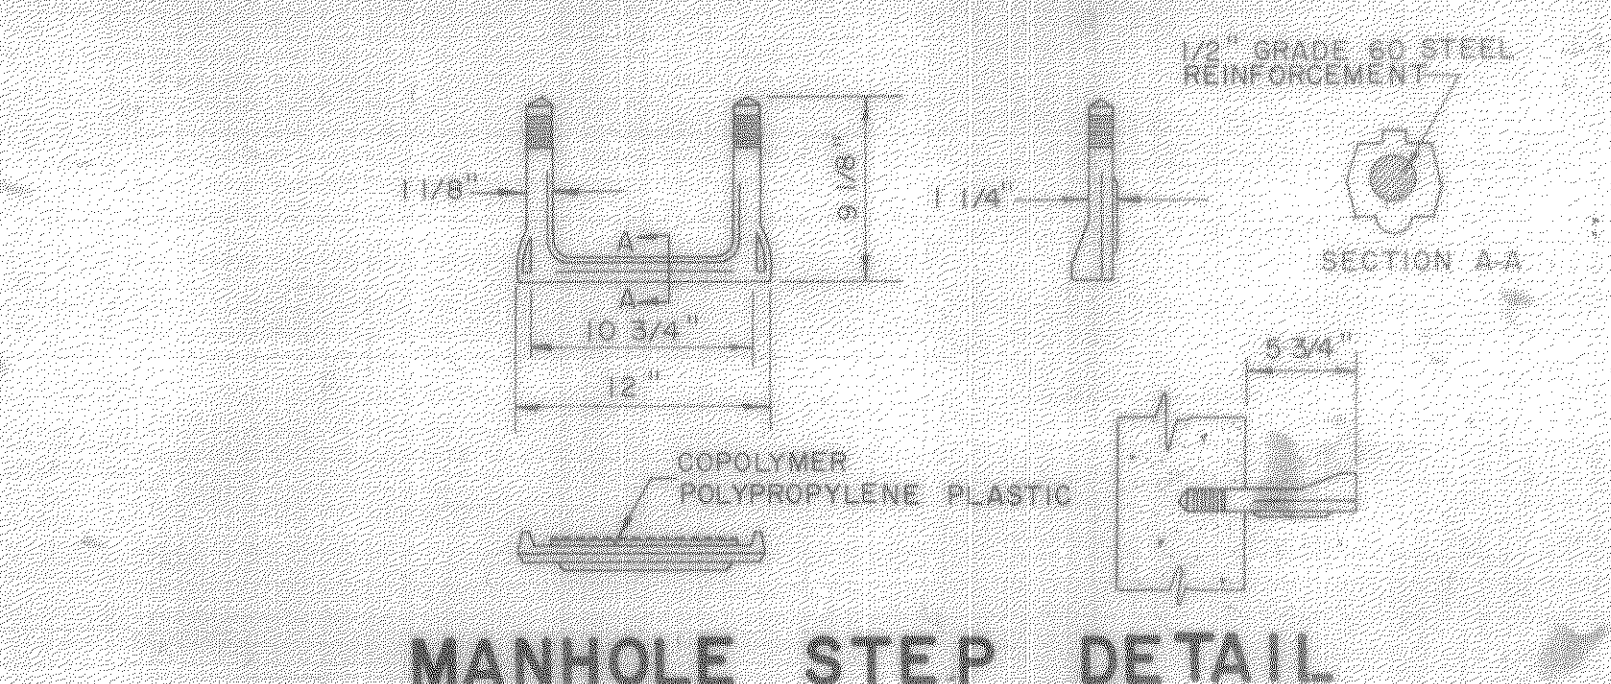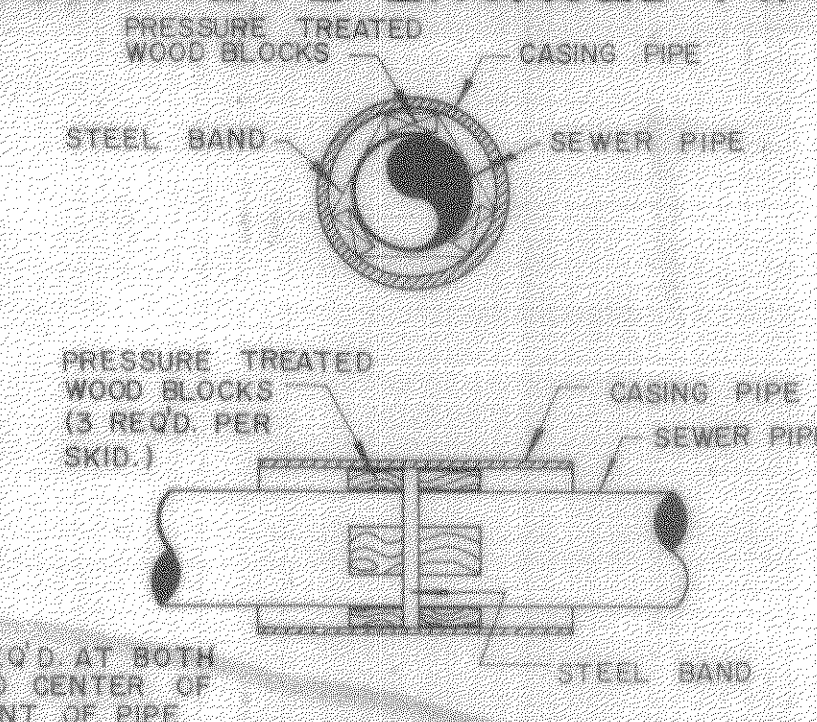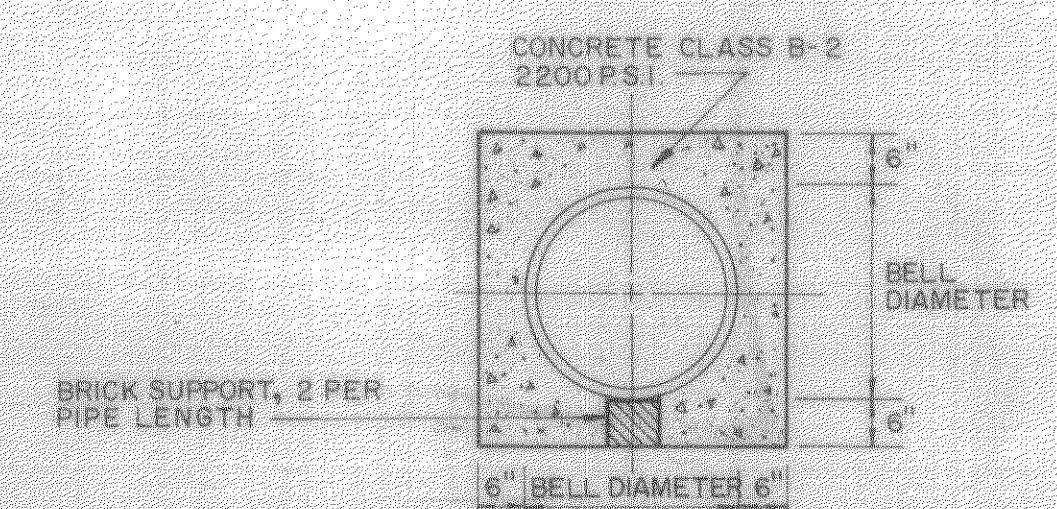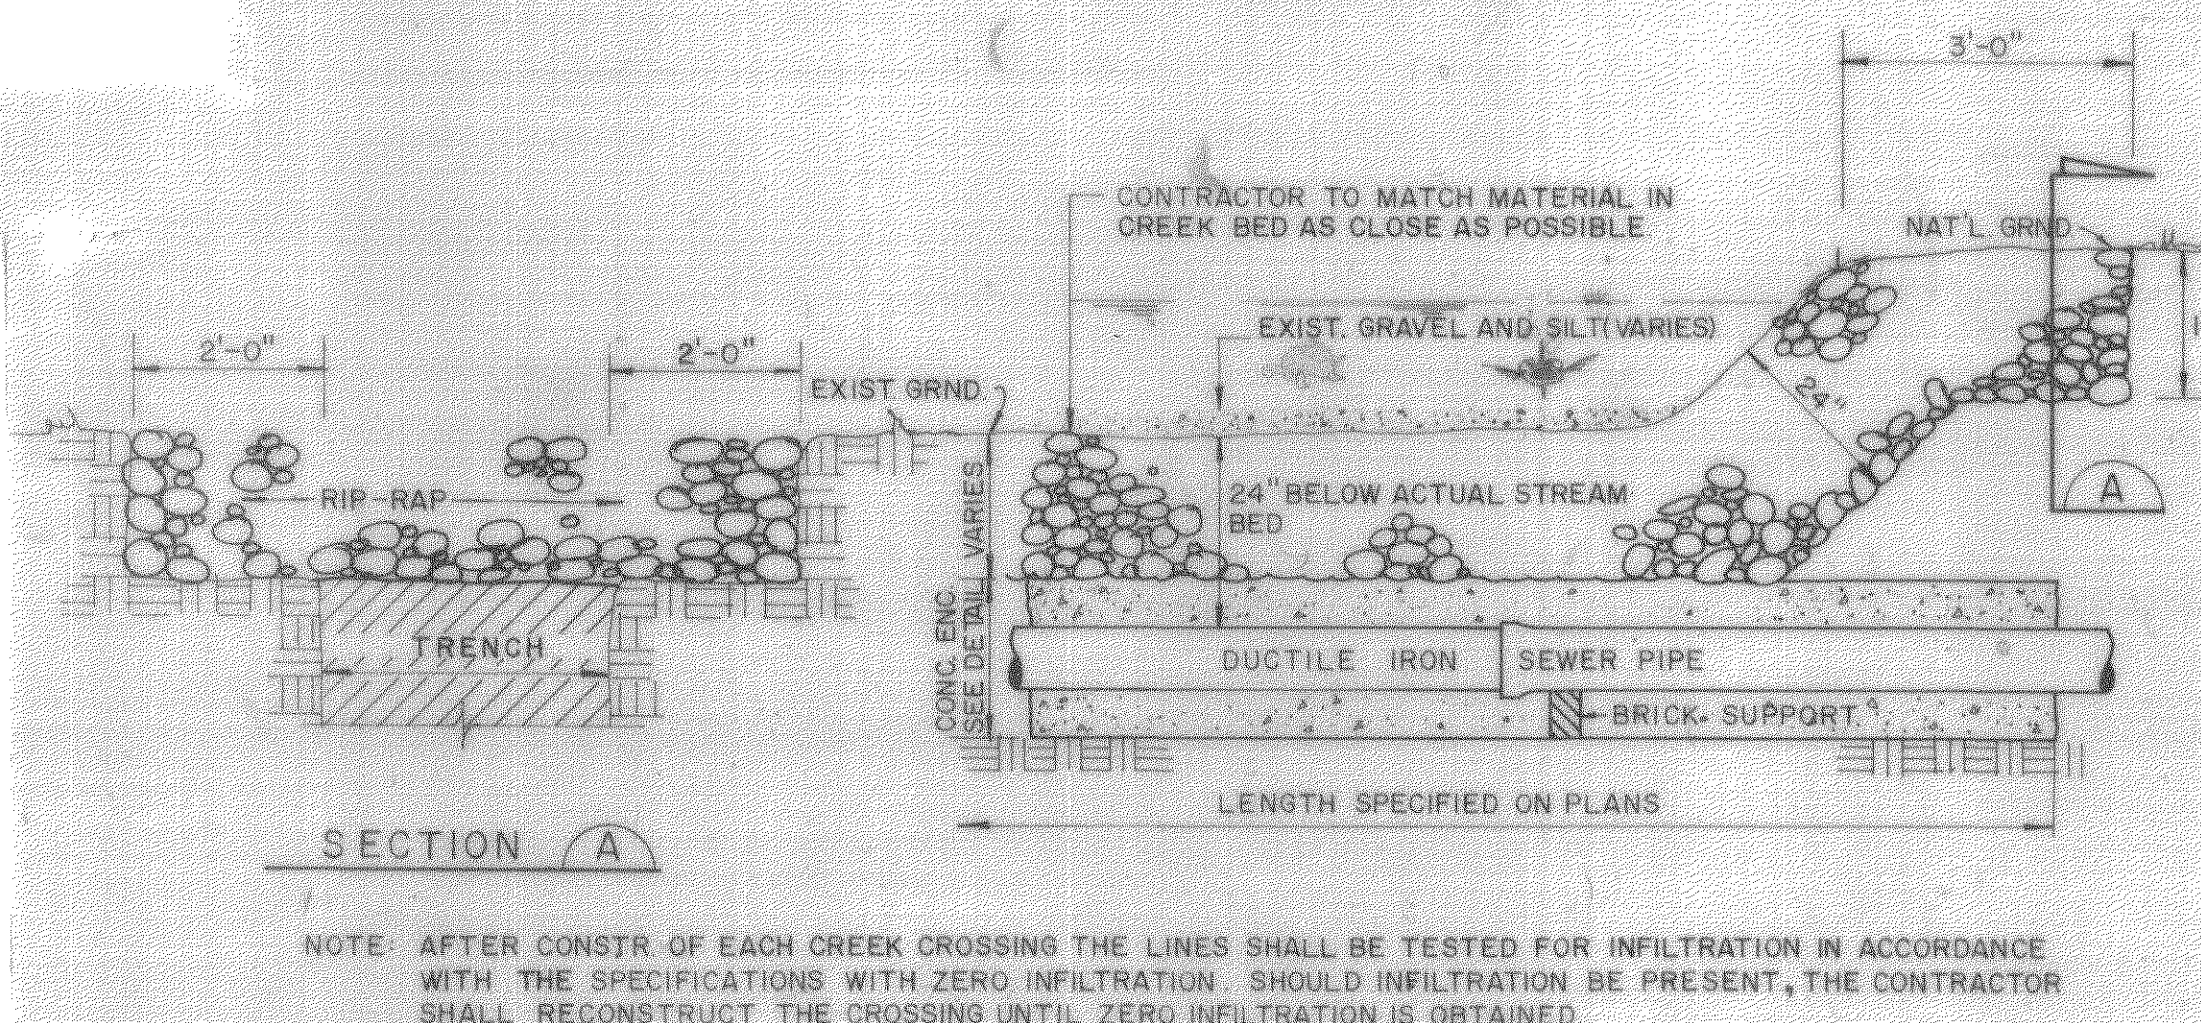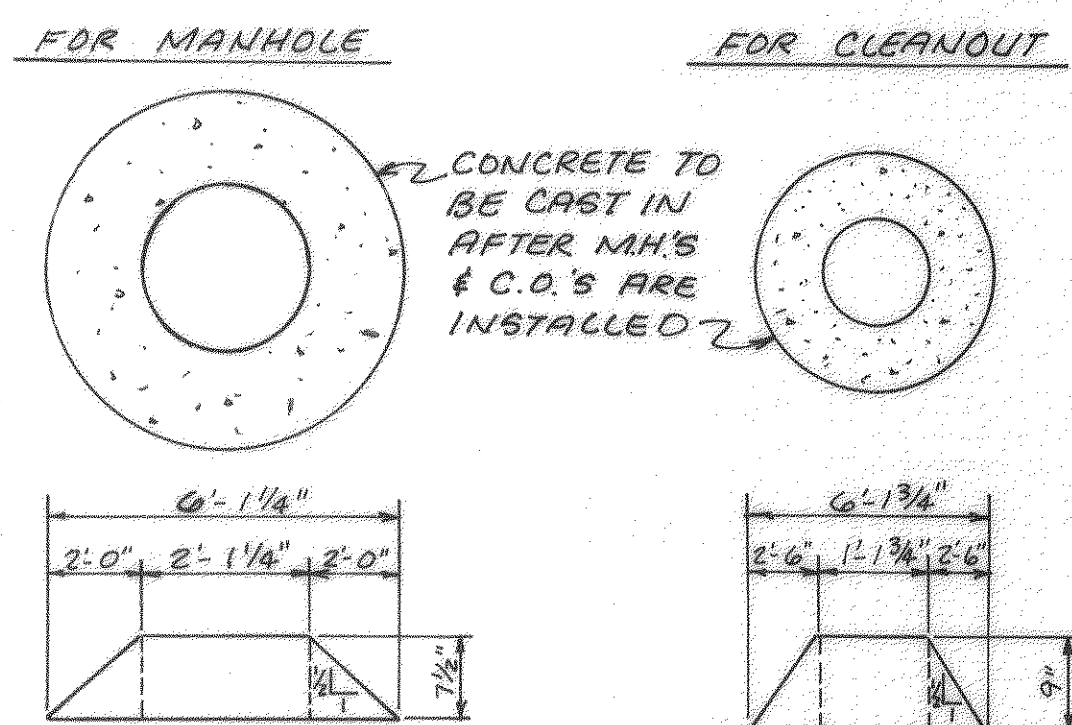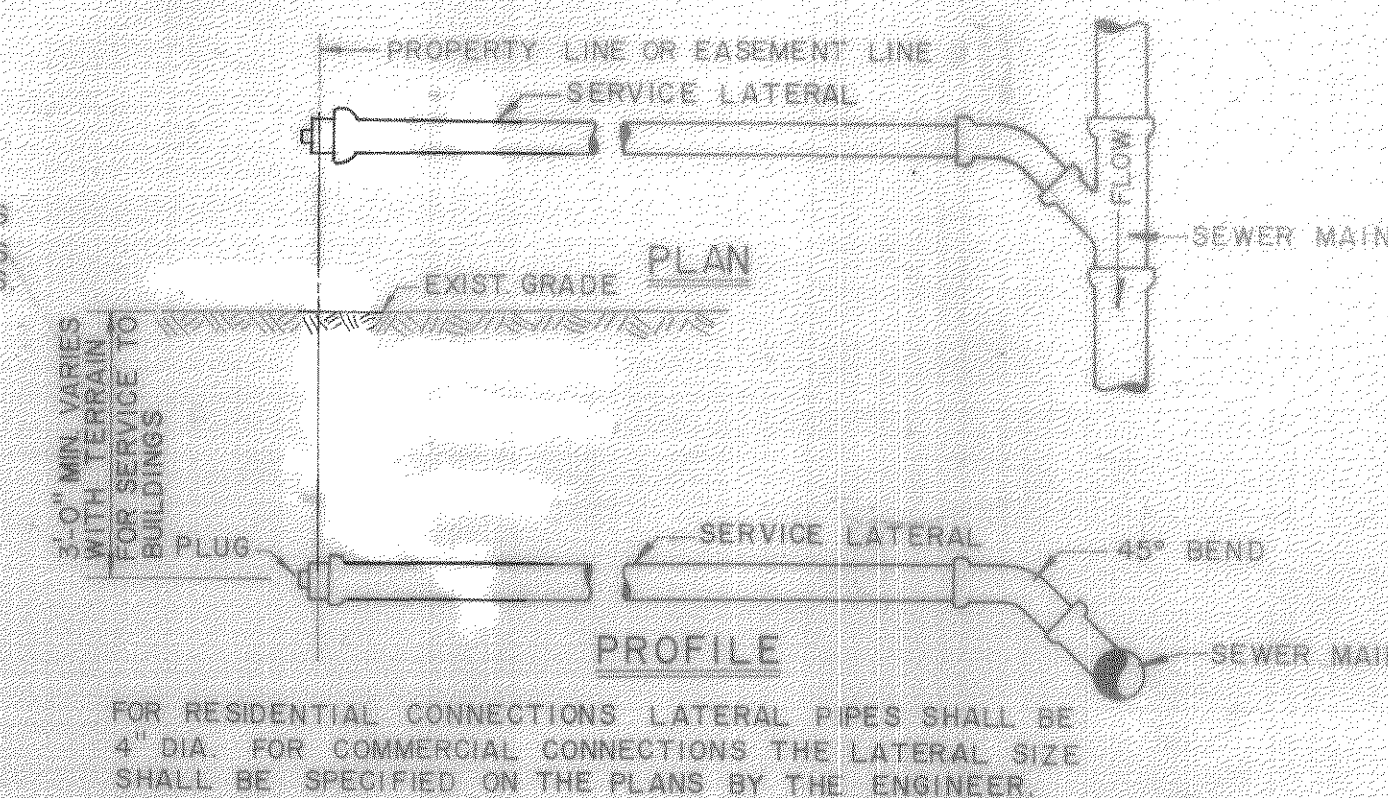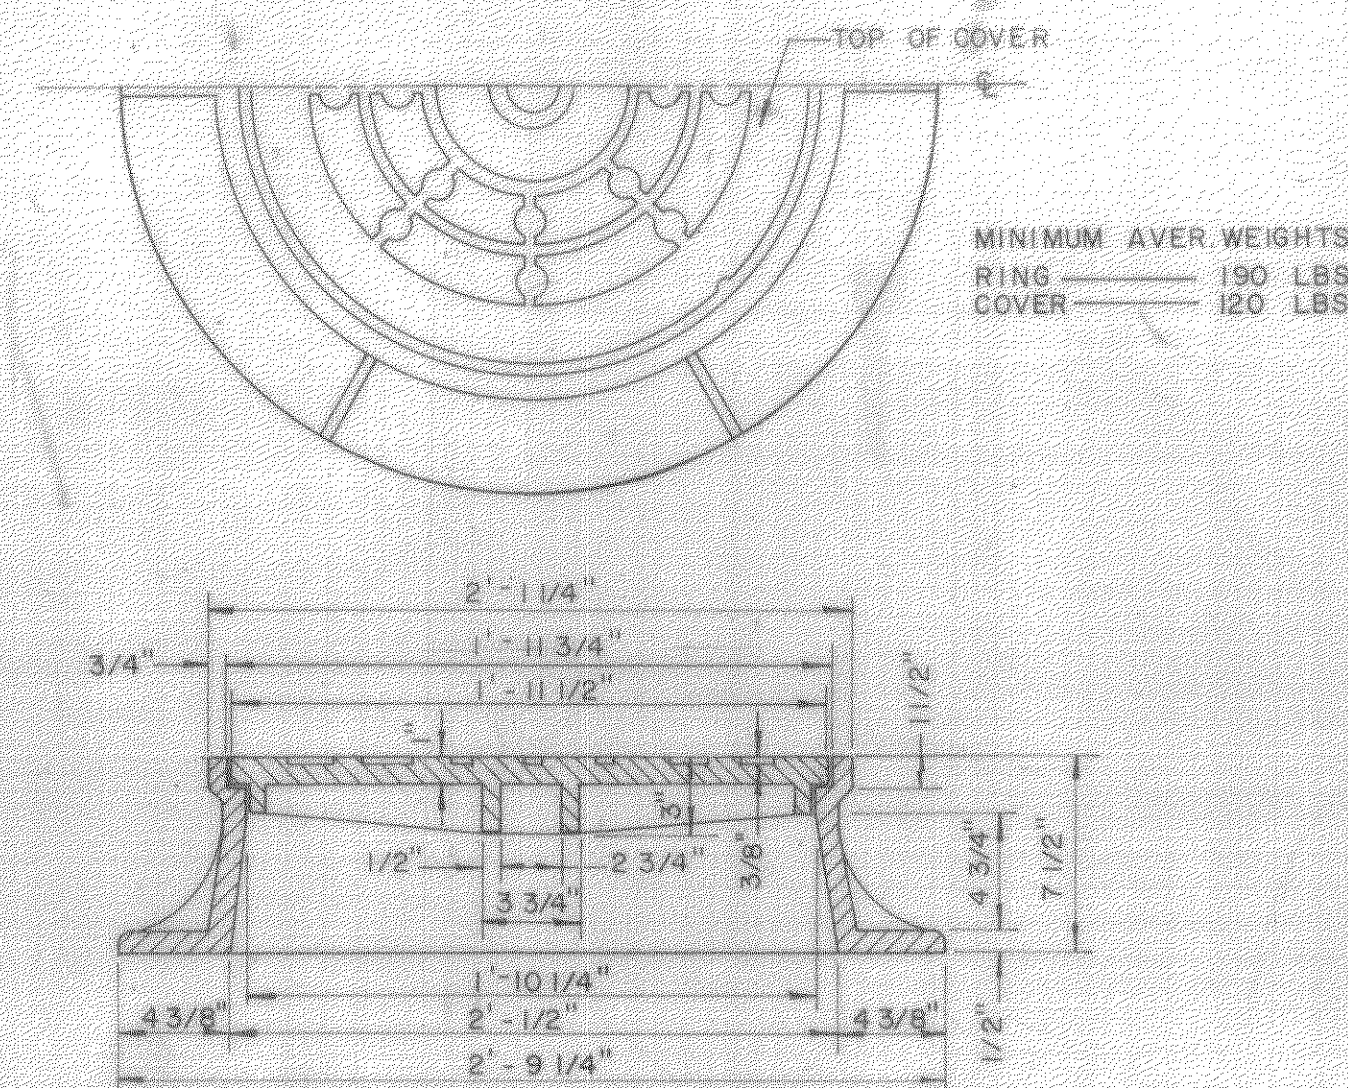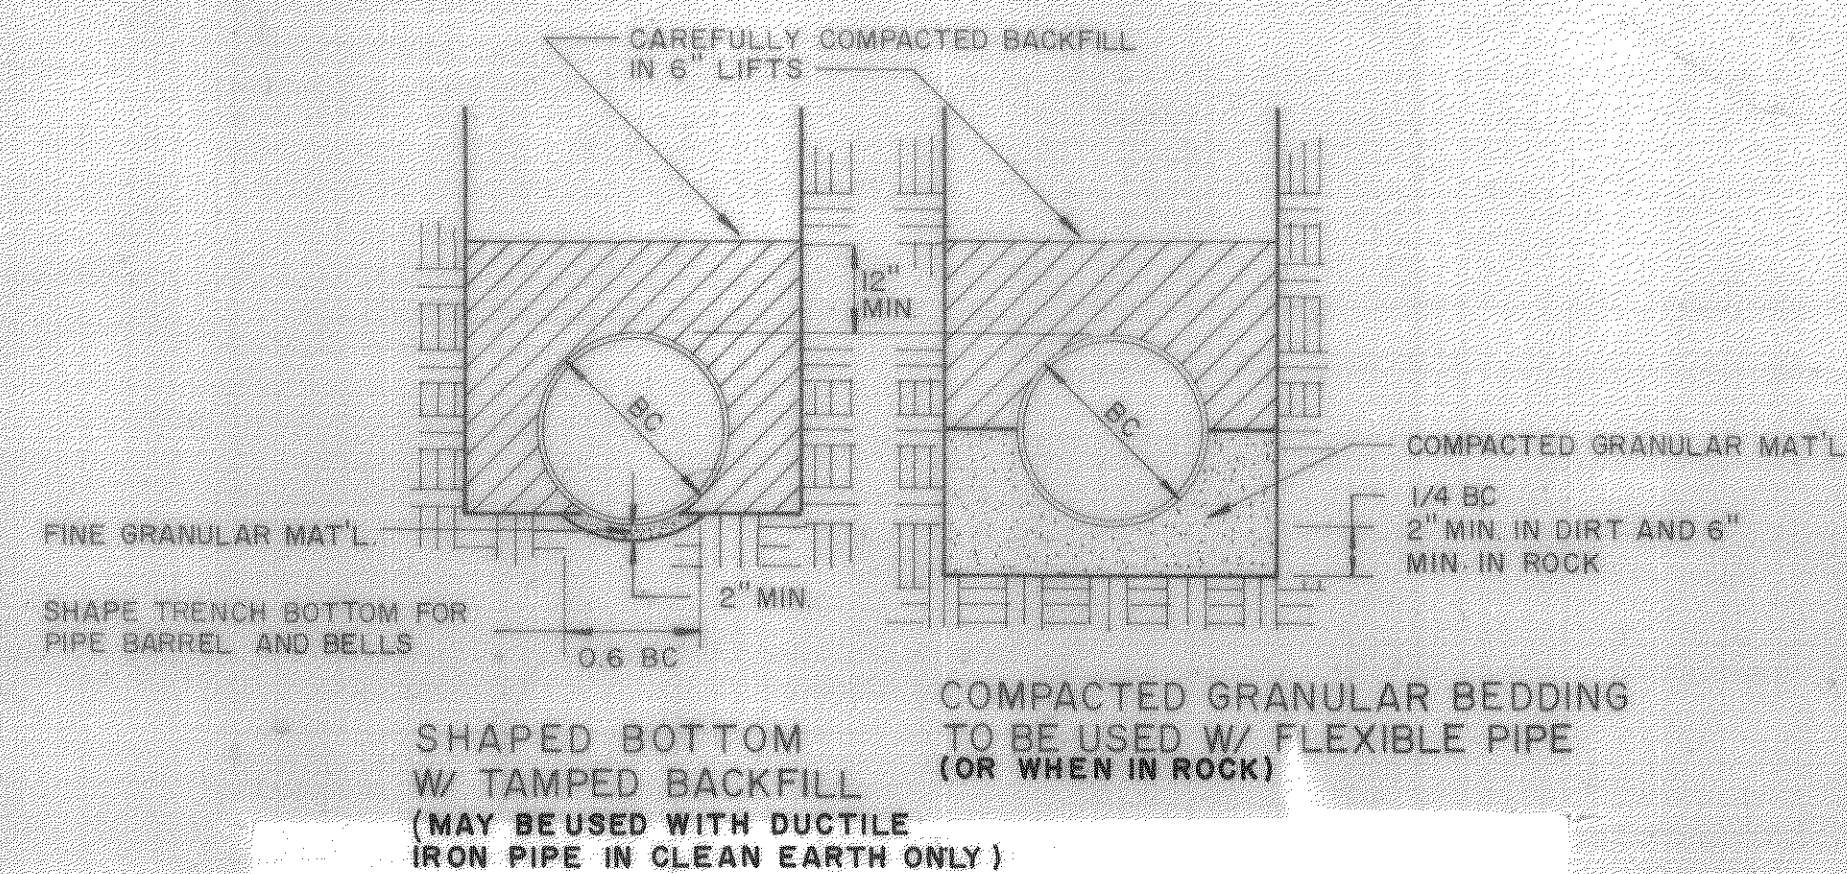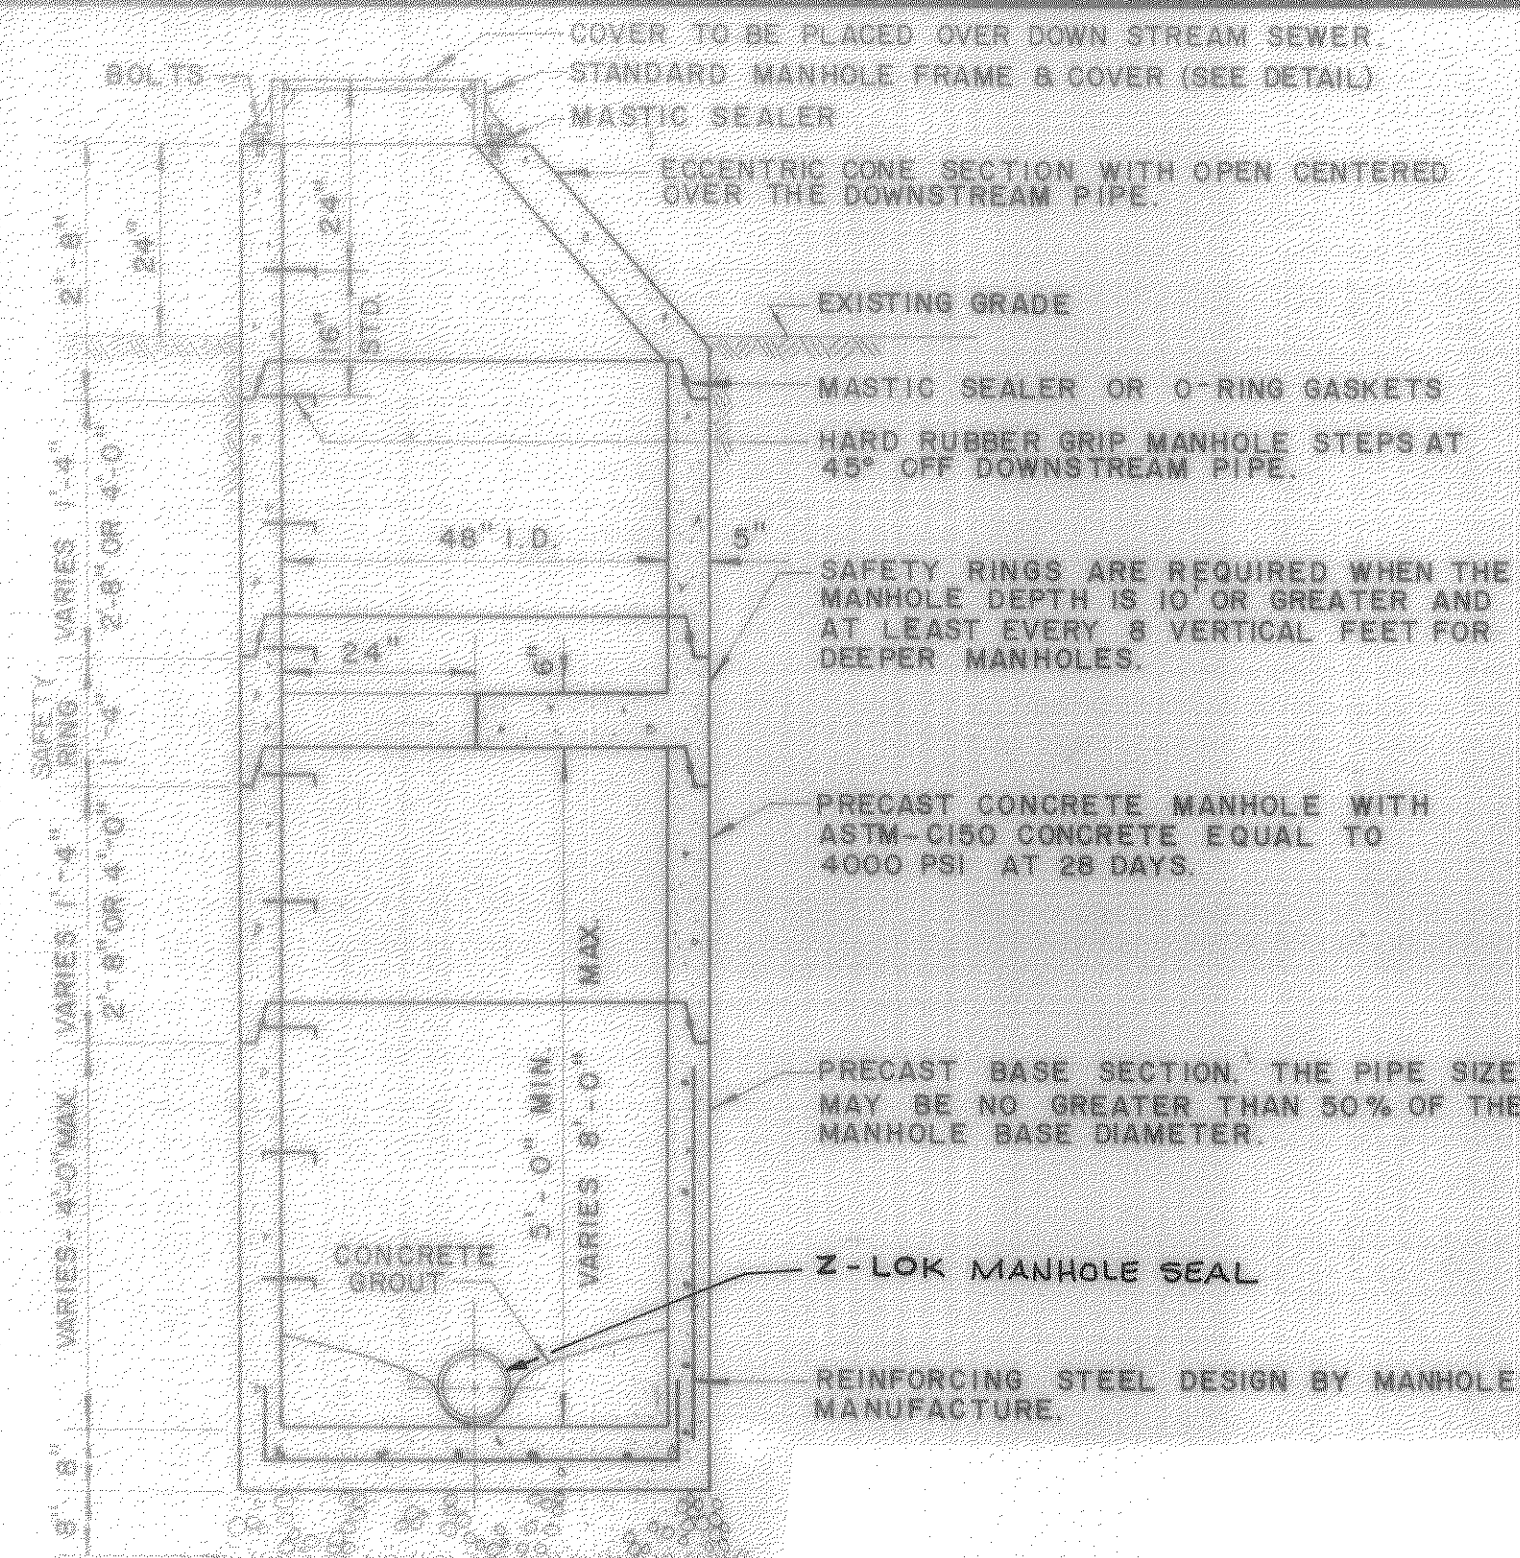

CONCRETE ANCHOR DETAIL

Designed:	DJR
Drafted:	CFA
Checked:	JMD
Approved:	DJR

Drafted: CFA

Checked: JMD

Approved: DJR




Clean Water Engineers, Inc.
Fincastle, Virginia

COMMUNITY OF EAGLE ROCK C
WASTEWATER COLLECTION AND TREATMENT SYSTEM
BOTETOURT COUNTY, VIRGINIA



CONTRACT I
... "AS BUILT"

DAVID J. RIGBY
David J. Rigby
 No. 8169

Sheet: 19 of 19
Scale: NONE
Date: DEC. 1987
Project: 86019

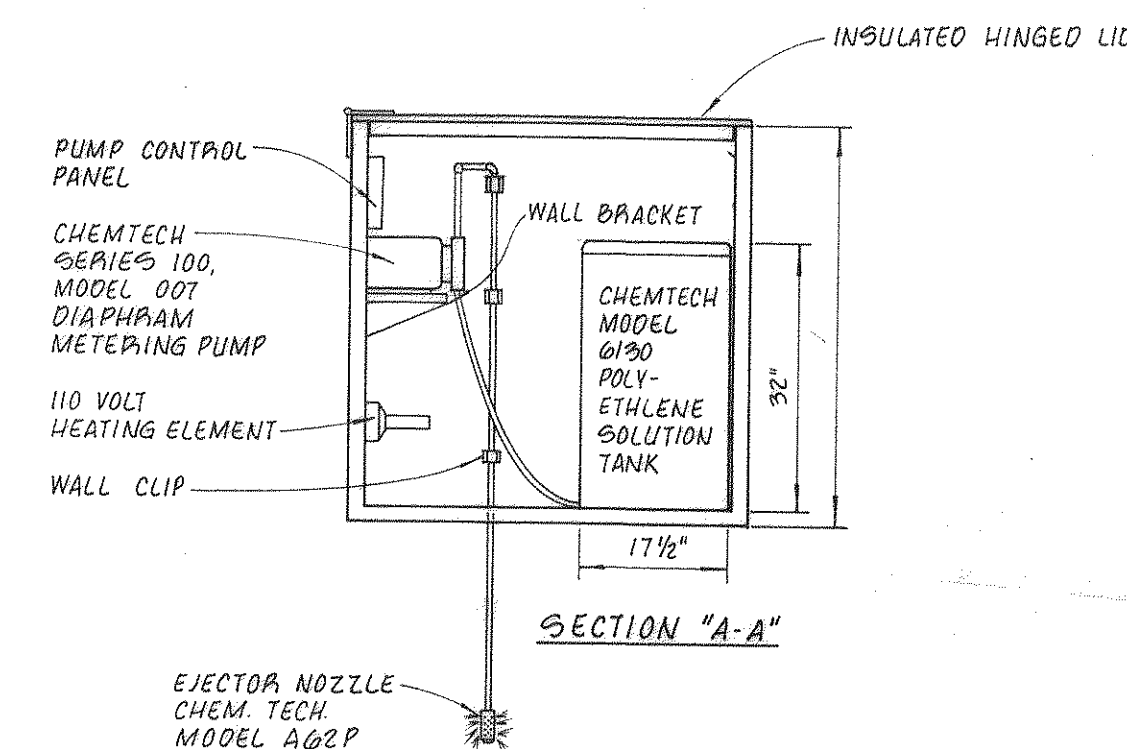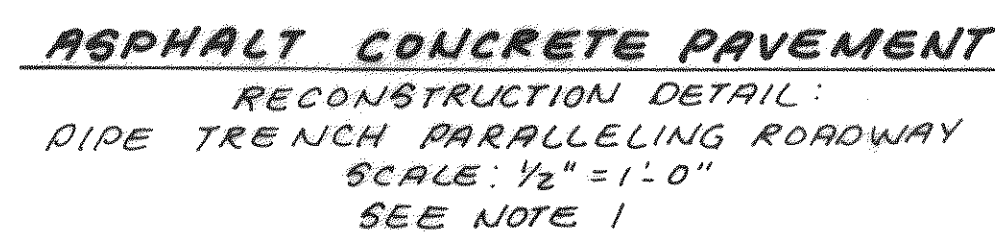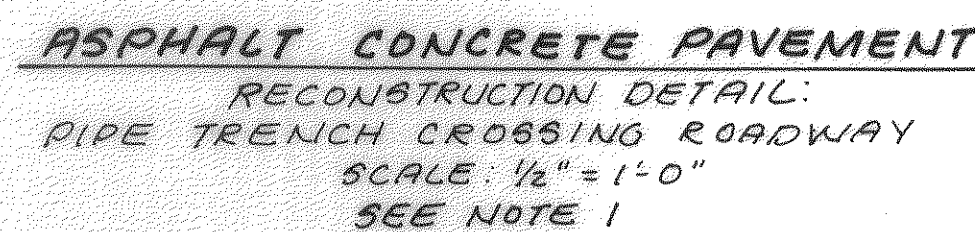

HYPOCHLORITE SYSTEM FEEDER DETAILS
NOT TO SCALE

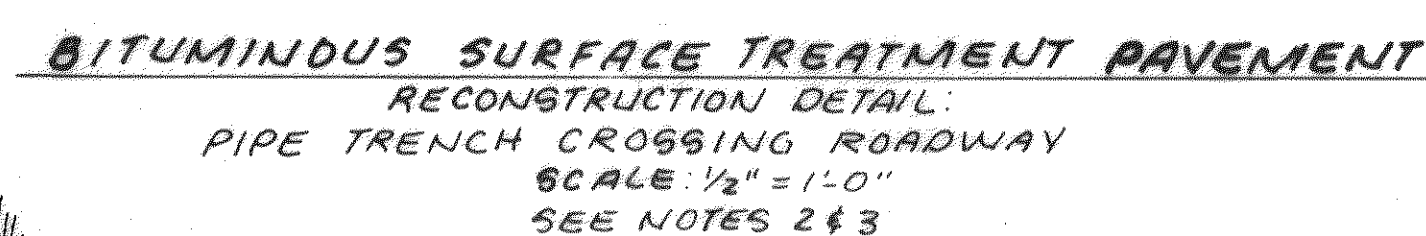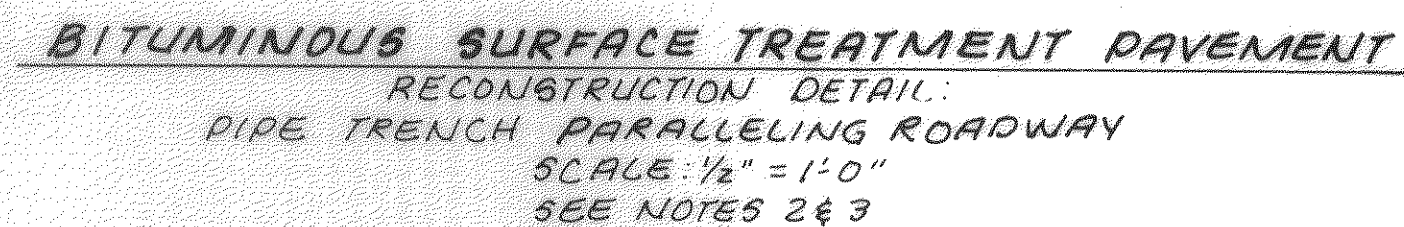


1) THE ABOVE DETAILS ARE INTENDED AS GENERAL GUIDELINES FOR MEETING VDOT REQUIREMENTS AND DOES NOT RELIEVE THE CONTRACTOR OF THE RESPONSIBILITY OF MEETING MORE STRINGENT REQUIREMENTS.

2) ADDITIONAL DAMAGE TO PAVEMENT BEYOND PAYMENT LIMITS SHALL BE RESTORED AT THE CONTRACTOR'S EXPENSE


3) THE CONTRACTOR SHALL BE RESPONSIBLE TO VERIFY WITH THE VDOT INSPECTOR THE ADDITIONAL DETAILS TO BE EMPLOYED FOR EACH STREET OR HIGHWAY TO BE RECONSTRUCTED. INCLUDING BUT NOT LIMITED TO BORING PIT LOCATIONS, TRAFFIC CONTROL, STREET ACCESS, PAVEMENT TYPE, COMPACTION TESTING REQUIREMENTS, SAFETY PRECAUTIONS AND OTHER SPECIAL REQUIREMENTS NOT SPECIFIED OR SHOWN ON THIS SHEET.

4) THE CONTRACTOR SHALL BE RESPONSIBLE FOR INSPECTION COSTS OF THE VDOT INSPECTOR UP TO \$5,000. ANY COSTS ABOVE THIS AMOUNT WILL BE PAID BY THE OWNER.

THE LANDSCAPE CONTRACTOR SHALL BE RESPONSIBLE FOR PROVIDING REPLACEMENT TREES @ APPLICABLE LOCATIONS (SEE 0281 OF SPEC'S). ALL REPLACED TREES SHALL BE G' NURSERY STOCK OF SAME SPECIES OR APPROVED SUBSTITUTE TO THAT WHICH WAS REMOVED OR DESTROYED TREES TO HAVE BURLAP ROOT PROTECTION AND WELL PRUNED, WITH NECESSARY INSECT PROTECTION AND FERTILIZER APPLIED AS RECOMMENDED BY THE NURSERY. THE CONTRACTOR SHALL GUARANTEE THE TREES TO BE HEALTHY FOR ONE YEAR FROM THE DATE OF INSTALLATION. NO ADDITIONAL PAYMENT SHALL BE MADE FOR REPLACING TREES OR SERVICING THE TREES AS REQUIRED IN THE FIRST YEAR.

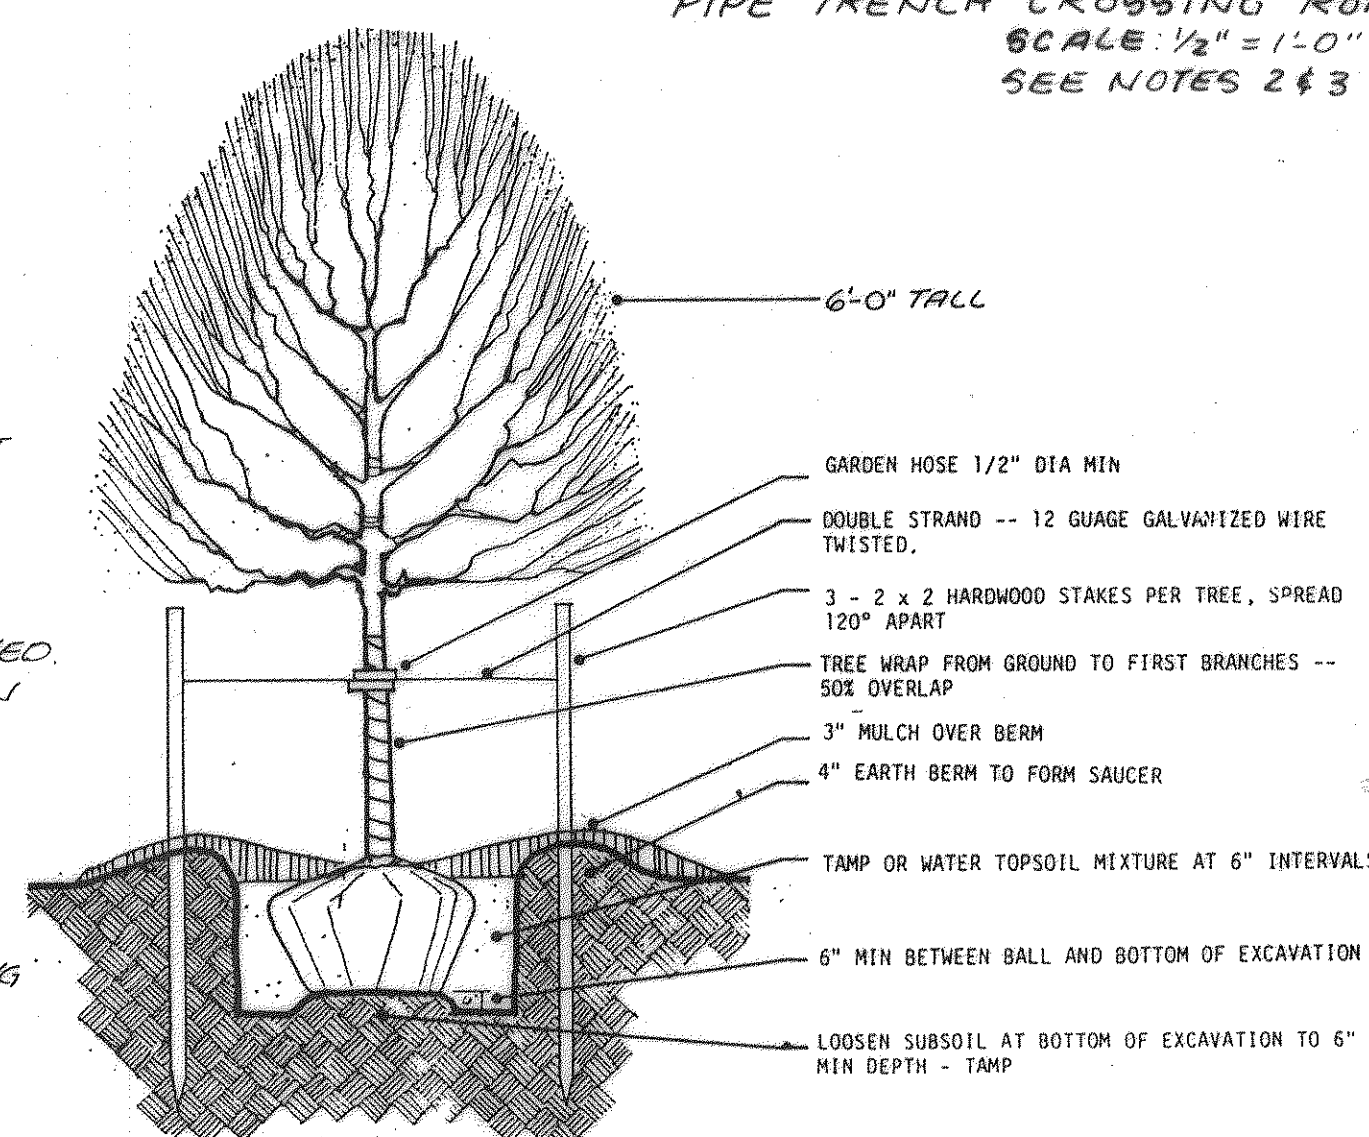

1. Planting & Staking / Trees up to 10' Ht.

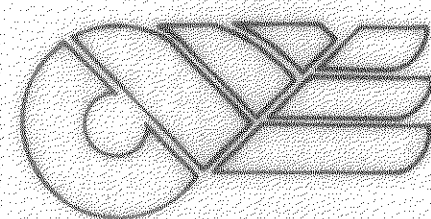


CLEAN WATER ENGINEERS, INC.

P. O. BOX 218
FINCASTLE, VIRGINIA 24090

COMMUNITY OF EAGLE ROCK
WASTEWATER COLLECTION AND TREATMENT SYSTEM
BOTETOURT COUNTY, VIRGINIA

CONTRACT II

"AS BUILT"

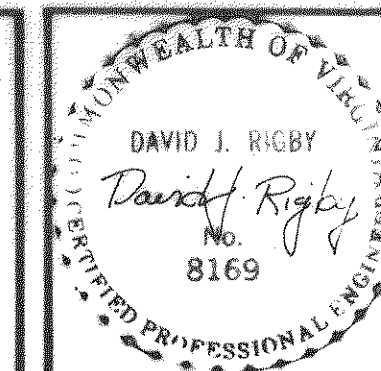

REVISIONS		
NO.	DATE	BY

DESIGNED:	SHEET:
JAF	19A OF 19
DRAWN:	SCALE:
TAP	1/2" = 1'-0"
CHECKED:	DATE:
JAF	MAY, 1991
APPROVED:	PROJECT:
DJR	86019