
WESTERN VIRGINIA WATER AUTHORITY **SCIP - 337**

CRAWFORD ROAD AND JANNEY LANE Main Line and laterals - Sanderson Pipe-Main line- PS 115-18"(same as SDR26) SANITARY SEWER REPLACEMENT **ROANOKE COUNTY - VIRGINIA**

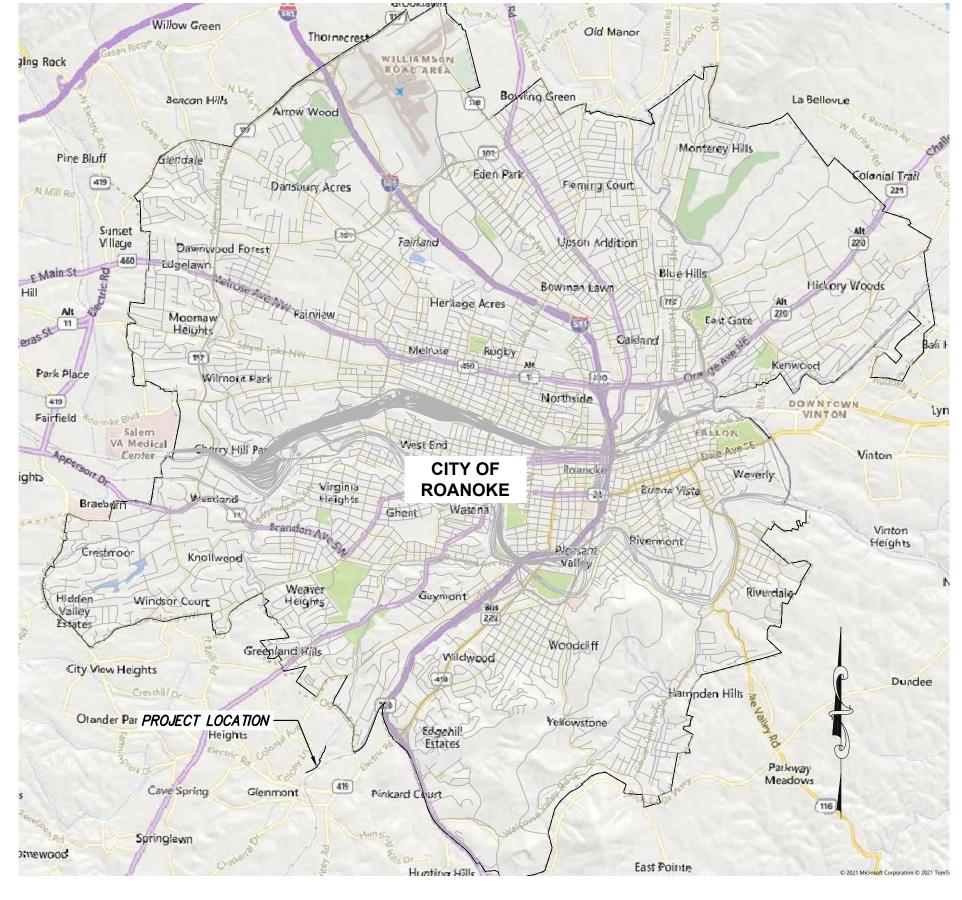

VICINITY MAP 1" = 5000'

PREPARED FOR: WESTERN VIRGINIA WATER AUTHORITY 601 S. JEFFERSON ST ROANOKE, VA 24011 TELEPHONE: 540-853-5700 FAX: 540-283-8217

Asbuilts-8.11.23 Inspector: Brian Whitenack Contractor: EC PACE_ Byron Craddock

Materials: Sewer: SDR 26_8", 6" and 4" lines Manholes- CT Jamison Frame/Lid- Capital Foundry cam lock lids with WVWA Logo



LOCATION MAP 1" = 200'

PREPARED BY: CHA CONSULTING 1341 RESEARCH CENTER DRIVE BLACKSBURG, VIRGINIA 24060 **TELEPHONE: 540-552-5548** FAX: 540-552-5577

SHEET INDEX TABLE	
SHEET NUMBER	SHEET TITLE
G-001	TITLE SHEET
G-002	LEGEND AND GENERAL NOTES
C-101	PLAN AND PROFILE STA 00+00 to STA 4+80
C-102	PLAN AND PROFILE STA 4+80 to STA 10+38
C-103	PLAN AND PROFILE STA 10+38 to STA 15+69
C-104	PLAN AND PROFILE STA 15+69 to STA 19+50
C-401	EROSION & SEDIMENT CONTROL NARRATIVE AND NOTES
C-402	EROSION & SEDIMENT CONTROL DETAILS
C-403	EROSION & SEDIMENT CONTROL DETAILS
C-404	EROSION & SEDIMENT CONTROL DETAILS
C-405	PROPOSED DISTURBED AREA
C-406	PROPOSED DISTURBED AREA
C-501	TRAFFIC CONTROL DETAILS I
C-601	GENERAL DETAILS
C-602	SEWER DETAILS I
C-603	SEWER DETAILS II

VESCP Approval



