


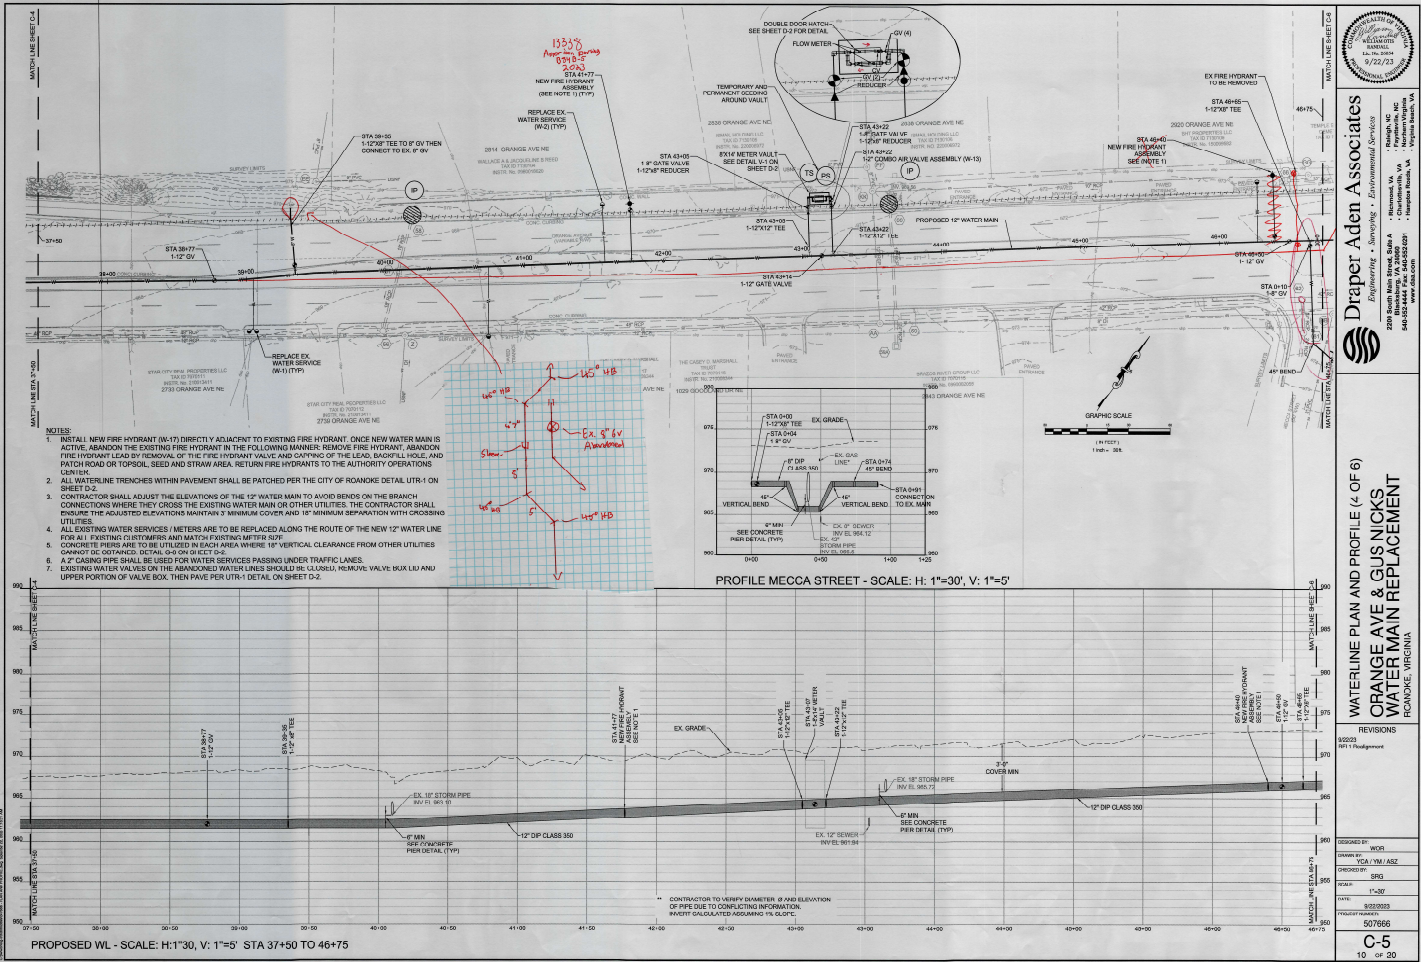

Draper Aden Associates
 Engineering • Surveying • Environmental Services
 2300 South Main Street, Suite A
 Roanoke, VA 24004
 540-954-4444 Fax: 540-952-0287
 www.drapeeraden.com

**WATERLINE PLAN AND PROFILE (4 OF 6)
 ORANGE AVE & GUS NICKS
 WATER MAIN REPLACEMENT
 ROANOKE, VIRGINIA**

REVISIONS	
02/03	W-17 Replacement

DESIGNED BY:	WCS
DRAWN BY:	TCU/TM/ASE
CHECKED BY:	WCS
SCALE:	1"=50'
DATE:	02/02/2023
PROJECT NUMBER:	507666

C-5
 10 of 20