CONTACT SUMMARY

OWNER: ADDRESS: WESTERN VIRGINIA WATER AUTHORITY

601 S. JEFFERSON ST.

ROANOKE, VA 24011

CONTACT:


TELEPHONE NO:

EARL SMITH P.E. 540-853-5700 540-853-1017

FAX NO:

ENGINEER:

2206 SOUTH MAIN STREET BLACKSBURG, VIRGINIA 24060

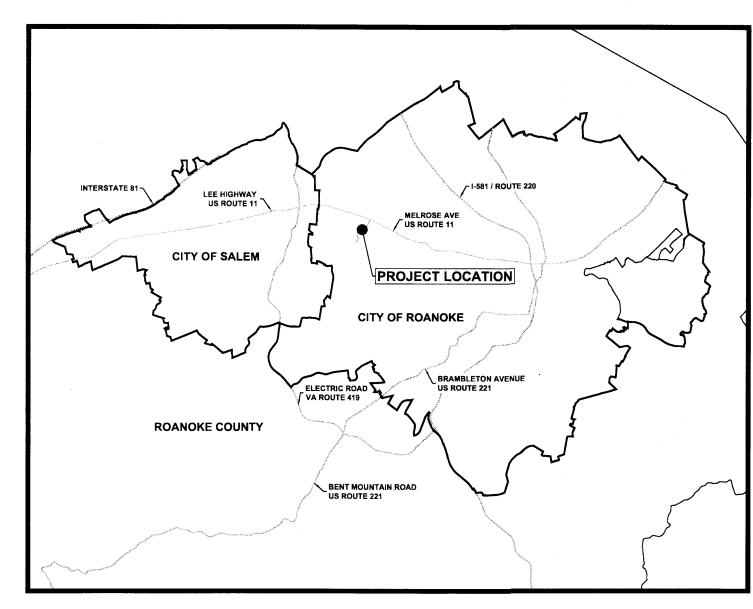

LOCATION MAP SCALE: 1" = 500'

CONSTRUCTION PROCEDURE REQUIREMENTS

1. RIGHT-OF-WAY EXCAVATION PERMIT - PRIOR TO THE COMMENCEMENT OF ANY DIGGING, ALTERATION OR CONSTRUCTION WITHIN THE PUBLIC RIGHT-OF-WAY (STREETS, ALLEYS, PUBLIC EASEMENTS), A RIGHT-OF-WAY EXCAVATION PERMIT SHALL BE APPLIED FOR AND OBTAINED BY THE CONTRACTOR FROM THE CITY OF ROANOKE.

2. PLANS AND PERMITS - A COPY OF THE PLANS AS APPROVED BY THE AUTHORITY (SIGNED BY THE PROPER OFFICIALS) AND ALL PERMITS ISSUED BY THE CITY SHALL BE AVAILABLE AT THE CONSTRUCTION SITE AT ALL TIMES OF ONGOING CONSTRUCTION.

3. LOCATION OF UTILITIES - THE CONTRACTOR SHALL VERIFY THE LOCATION OF ALL EXISTING UTILITIES PRIOR TO THE COMMENCEMENT OF ANY CONSTRUCTION.


4. STREETS TO REMAIN CLEAN - IT SHALL BE THE RESPONSIBILITY OF THE CONTRACTOR TO INSURE THAT PUBLIC STREETS ADJACENT TO CONSTRUCTION REMAIN FREE OF MUD, DIRT, DUST, AND/OR ANY TYPE OF CONSTRUCTION MATERIALS OR LITTER AT ALL TIMES.

5. BARRICADES/DITCHES - THE CONTRACTOR SHALL MAINTAIN THE INTEGRITY OF ALL EXCAVATED DITCHES AND SHALL FURNISH AND ENSURE THAT ALL BARRICADES PROPER AND NECESSARY FOR THE SAFETY OF THE PUBLIC ARE IN PLACE.

6. WATER MAINS AND PAVEMENT REPLACEMENT - CONSTRUCTION OF WATER MAINS AND THE REPLACEMENT OF PAVEMENT SHALL BE IN ACCORDANCE WITH APPROVED STANDARDS AND SPECIFICATIONS OF VDOT, THE CITY OR ROANOKE AND THE WESTERN VIRGINIA WATER AUTHORITY.

ROANOKE COUNTY, VIRGINIA

* * *

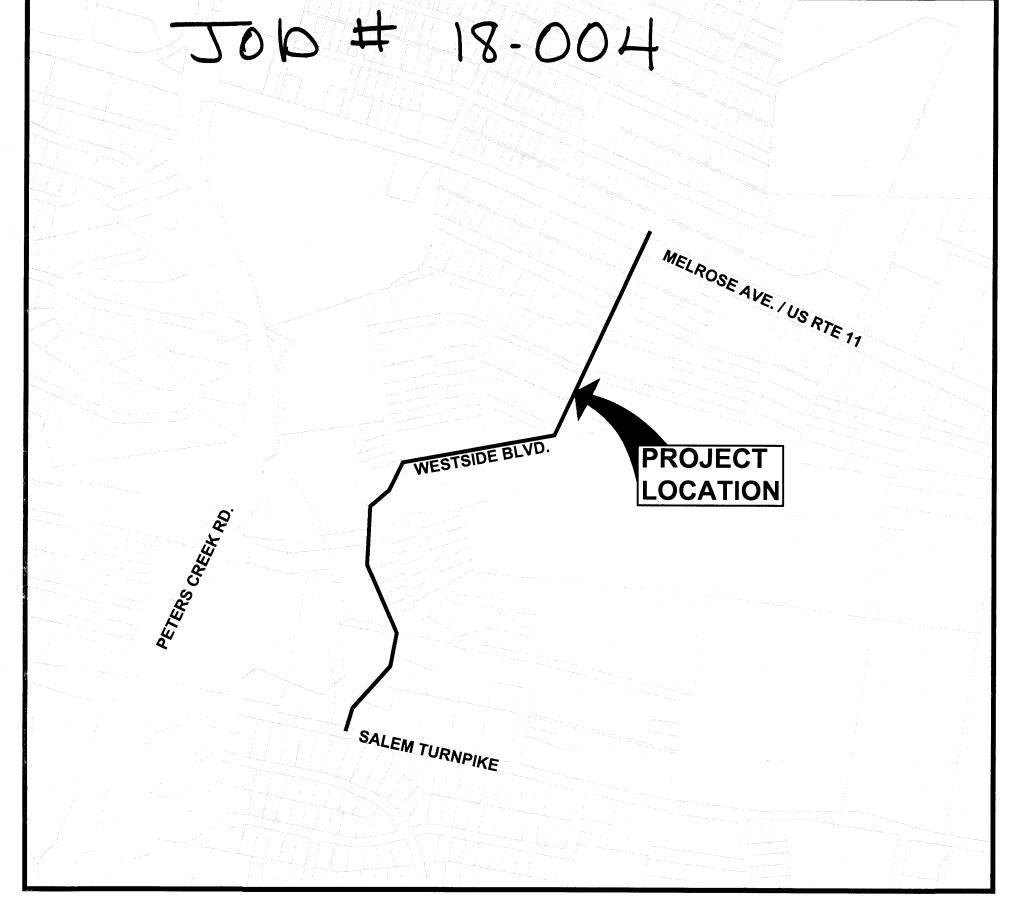

VICINITY MAP SCALE: 1" = 500'

PROJECT DESCRIPTION

THIS PROJECT CONSISTS OF THE INSTALLATION OF APPROXIMATELY 4,000 LF OF 12", 8" AND 6" WATER MAIN AND RELATED APPURTENANCES.

> SEPTEMBER 2017 * * * *

B11132B-11



These documents, including drawings and specifications, were prepared by Draper Aden Associates, Consulting Engineers, pursuant to a contract by and between Draper Aden Associates and Western Virginia Water Authority with respect to the project described in said contract. Any reuse or modification of said documents (whether hard copy or electronic) without written verification or adaptation by Draper Aden Associates for the specific purpose intended will be at the sole risk of the individual or entity utilizing said documents, drawings and specifications and such use is without the authorization of Draper Aden Associates. Draper Aden Associates, Consulting Engineers, shall have no legal liability resulting from any and all claims, damages, losses, and expenses, including attorney's fees arising out of the unauthorized use of these documents, drawings, specifications, reports, and studies prepared as a result of the aforesaid contract.

APPROVED FOR CONSTRUCTION

EARL SMITH PE. WVWA PROJECT MANAGER

DRAWING LIST

DRAWING NO.	DRAWING TITLE
T-1	COVER SHEET
T-2	GENERAL NOTES
T-3	KEY SHEET & LEGEND
C-1	WATER MAIN PLAN AND PROFILE
C-2	WATER MAIN PLAN AND PROFILE
C-3	WATER MAIN PLAN AND PROFILE
C-4	WATER MAIN PLAN AND PROFILE
C-5	WATER MAIN PLAN AND PROFILE
C-6	WATER MAIN PLAN AND PROFILE
C-7	WATER MAIN PLAN AND PROFILE
ES-1	EROSION AND SEDIMENT CONTROL
D-1	DETAILS
D-2	DETAILS
TC-1	TRANSPORTATION MANAGEMENT PLAN
TC-2	TRANSPORTATION MANAGEMENT PLAN
TC-3	TRANSPORTATION MANAGEMENT PLAN

DRAPER ADEN ASSOCIATES REVIEW

THESE PLANS HAVE BEEN SUBJECTED TO TECHNICAL AND QUALITY REVIEWS BY:

Benjamin Chester PE	Burning Chester	9/22/17	
NAME: PRINTED PROJECT DESIGNER	SIGNATURE	DATE	
Jay Lester PE	José Jesta	9/22/17	
NAME: PRINTED PROJECT MANAGER	SIGNATURE	DATE	
Michael Haggerty PE	ghol 14	9/18/17	
NAME: PRINTED QUALITY REVIEWER	SIGNATURE	DATE	

Material - V.S. Pipe 12", 8", 6" (1350 DIP)

Services - polyflex Endot 1"

Valves - Mueller, 12", 6", 8", 4"

All Pipe Restrained Lot Gasket (Feild Lok)

DESIGNED

DRAWN BY hydrants: Mueller K12 2018 ON All

Inspector: Brian Whitenack Contractor: E.C. PACE

CHECKED BY: NO SCALE

9/15/2017 B11132B-11