



ONE-LINE DIAGRAM LEGEND

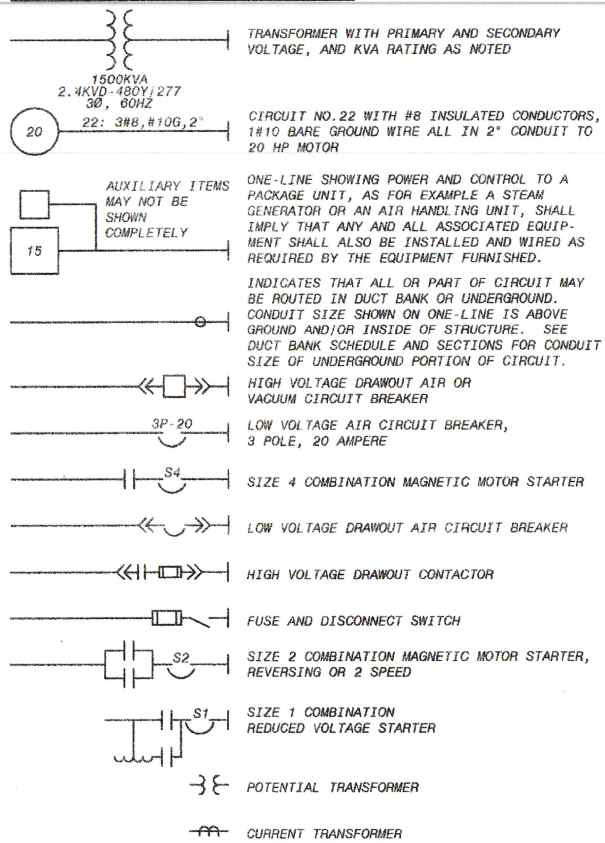


CONDUIT & WIRING INSTALLATION LEGEND

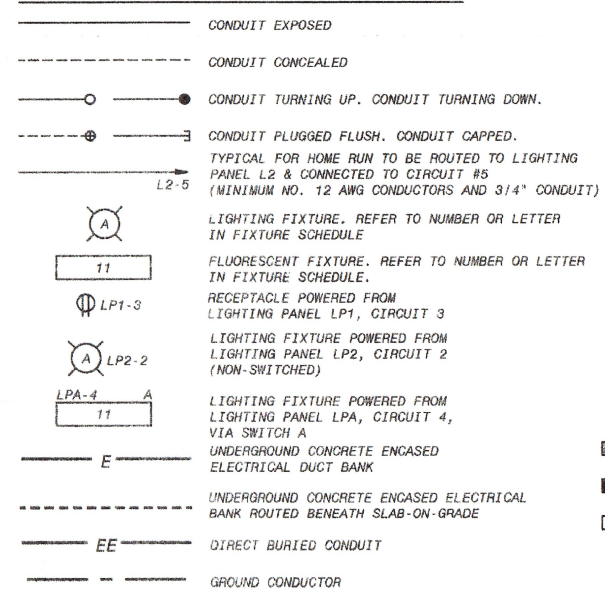


SWITCH & OUTLET SYMBOLS

S	SINGLE POLE SWITCH	SPL	SWITCH WITH PILOT LIGHT		DUPLEX RECEPTACLE 120 VOLT		120 VOLT DUPLEX RECEPTACLE (UPS)
S ₂	TWO POLE SWITCH	SKO	KEY OPERATED SWITCH		SIMPLEX RECEPTACLE		DUPLEX FLOOR OUTLET
S ₃	THREE-WAY SWITCH	XP	EXPLOSION PROOF SWITCH		RANGE RECEPTACLE		TELEPHONE OUTLET
S ₄	FOUR-WAY SWITCH	SDM	DIMMER SWITCH		TWISTLOCK RECEPTACLE		TELEPHONE FLOOR
S _M ¹	MOMENTARY SWITCH CONTROLLING CONTACTOR C1	S3A	THREE-WAY SWITCH CONTROLLING LIGHTS WITH "A" DESIGNATION		240V, 10 RECEPTACLE, TYPICAL AMPERE RATING NOTED		COAXIAL CABLE OUTLET
S _{WP}	WEATHERPROOF SWITCH				480V, 30 WELDING RECEPTACLE, TYPICAL AMPERE RATING NOTED		

SCHEMATIC SYMBOLS

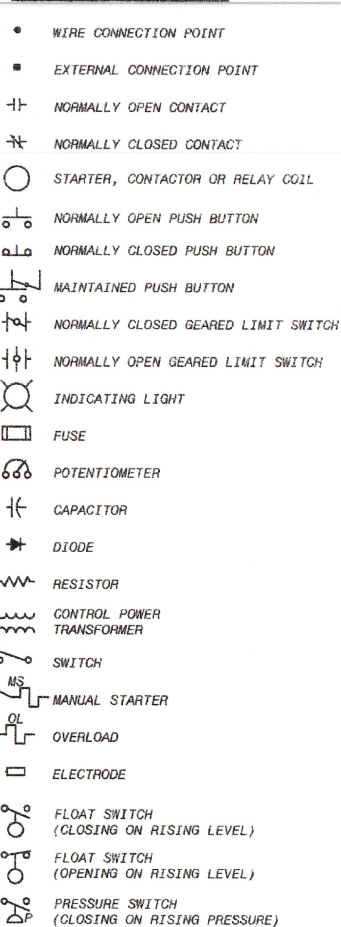

MISCELLANEOUS SYMBOLS

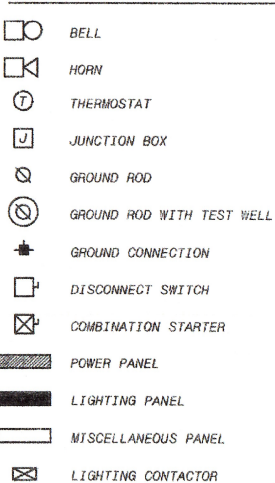

ABBREVIATIONS

A	AMBER, AMPERE, ALARM	M	MAGNETIC MOTOR STARTER
AC	ALTERNATING CURRENT	MA	MILLIAMPERE
ACB	AIR CIRCUIT BREAKER	MOB	MAIN CIRCUIT BREAKER
AF	AMPERE FRAME	MOC	MOTOR CONTROL CENTER
AFD	ADJUSTABLE FREQUENCY DRIVE	MCLU	MOTOR CONTROL LINEUP
AM	AMMETER	MD	MOISTURE DETECTOR
ANV	ANNUNCIATOR	MFM	MAGNETIC FLOW METER
AR	ALARM RELAY	MFR	MANUFACTURER
AS	AMMETER SWITCH	MH	MANHOLE OR MOUNTING HEIGHT
AT	AMPERE TRIP	MOV	MOTOR OPERATED VALVE
AWG	AMERICAN WIRE GAGE	MPR	MOTOR PROTECTION RELAY
		MS	MANUAL MOTOR STARTER
BC	BATTERY CHARGER	MSH	MOTOR SPACE HEATER
BR	BRAKE	MV	MILLIVOLT
BT	BEARING TEMPERATURE	MVA	MEGA VOLT AMPERE
C	CLOSE, COUNTER OR CONTACTOR	N	NEUTRAL
CAP	CAPACITOR	NC	NORMALLY CLOSED
CB	CIRCUIT BREAKER	NO	NORMALLY OPEN, NUMBER
CB*A	CIRCUIT BREAKER AUXILIARY CONTACT (OPEN WHEN BREAKER IS OPEN OR TRIPPED CLOSED WHEN BREAKER IS CLOSED)	O	OPEN
CB*B	CIRCUIT BREAKER AUXILIARY CONTACT (CLOSED WHEN BREAKER IS OPEN OR TRIPPED OPEN WHEN BREAKER IS CLOSED)	OCB	OIL CIRCUIT BREAKER
		OL	OVERLOAD
CD	CONTROL DAMPER	OOA	ON-OFF-AUTO
CI	CELL INTERLOCK	OOR	ON-OFF-REMOTE
CKT	CIRCUIT		
CL2	CHLORINE	P	PRIMARY
COS	CABLE OPERATED SWITCH	PCS	PLANT CONTROL SYSTEM
CP	CONTROL PANEL	PB	PUSH BUTTON OR PULL BOX
CPT	CONTROL POWER TRANSFORMER	PF	POWER FACTOR METER
CR	CURRENT OR CONTROL RELAY	PH	PHASE, CHEMICAL TERM
CS	CONTROL STATION	PLC	PROGRAMMABLE LOGIC CONTROLLER
CT	CYCLE TIMER OR CURRENT TRANSFORMER	PP	POWER PANEL
CTC	CYCLE TIMER CLUTCH	PRS	PROXIMITY SWITCH
CTM	CYCLE TIMER MOTOR	PS	PRESSURE SWITCH
2/C	2 CONDUCTOR	PT	POTENTIAL TRANSFORMER,
4/C	4" CONDUIT	2P	PROGRAM TIMER 2 POLE
DC	DIRECT CURRENT	R	RED, RAISE, RELAY OR REVERSE
DI	DOOR INTERLOCK	RECP	RECEPTACLE
DM	DAMPER MOTOR OR DEMAND METER	RES	RESISTOR
DPDT	DOUBLE POLE DOUBLE THROW	RT	REPEATING TIMER
DPST	DOUBLE POLE SINGLE THROW	RTD	RESISTANCE TYPE TEMP DETECTOR
OPR	DIFFERENTIAL PRESSURE REGULATOR	RTU	REMOTE TERMINAL UNIT
DPS	DIFFERENTIAL PRESSURE SWITCH	RVSS	REDUCED VOLTAGE SOLID STATE STARTER
DS	DISCONNECT SWITCH		
DVLS	DISCHARGE VALVE LIMIT SWITCH	S2	SIZE 2 STARTER
		SCADA	SUPERVISORY CONTROL AND DATA ACQUISITION
E	ELECTRIC OPERATOR FOR CONTROL DAMPER OR VALVE	SH	SPACE HEATER
EC	EMPTY CONDUIT	SN	SOLID NEUTRAL
EL	ELEVATION OR EMERGENCY LIGHT	SO	SOLENOID OILER
EMH	ELECTRICAL MANHOLE	SP	SINGLE POLE
ES	ELECTRODE RELAY	SPDT	SINGLE POLE DOUBLE THROW
EW	END SWITCH	SPST	SINGLE POLE SINGLE THROW
ETM	ELAPSED TIME METER	SS	SELECTOR SWITCH
EX	EXISTING	SSS	SOLID STATE STARTER
F	FORWARD	SUPV	SUPERVISORY CONTROL
FS	FLOW SWITCH	SV	SOLENOID VALVE
G	GREEN OR GROUND	SWB	SWITCHBOARD
GD	GROUND DETECTOR	SWGR	SWITCHGEAR
GEN	GENERATOR		
GFI	GROUND FAULT INTERRUPTER	T	THERMOSTAT, TIMER, OR TOTALIZER
GLS	GEARED LIMIT SWITCH	TACH	TACHOMETER
RGB	#8 GROUND WIRE	TB	TERMINAL BLOCK
		TC	TIMER CLUTCH
H	HIGH OR HUMIDISTAT	TD	TIME DELAY RELAY
HC	HOT CIRCUIT	TEMP	TEMPERATURE
HH	HANDHOLE	TM	TIMER MOTOR
HMT	HIGH MOTOR TEMPERATURE	TQ	TORQUE
HOA	HAND-OFF-AUTO	TS	TEMPERATURE SWITCH
HOR	HAND-OFF-REMOTE	TTB	TELEPHONE TERMINAL BOX
HP	HORSEPOWER		
HWC	HIGH WATER CUTOFF	UG	UNDERGROUND
HZ	HERTZ (CYCLE)	UV	UNDER VOLTAGE
		UPS	UNINTERRUPTIBLE POWER SUPPLY
I/O	INPUT/OUTPUT		
INST	INSTANTANEOUS	V	VOLTS
J	JUNCTION BOX	VA	VOLT AMPERE
JB	JUNCTION BOX	VAR	VARMETER
		VLS	VALVE LIMIT SWITCH
K	KEY INTERLOCK	VM	VOLTMETER
KMIL	THOUSAND CIRCULAR MIL	VPI	VALVE POSITION INDICATOR
KV	KILOVOLT	VS	VOLTMETER SWITCH
KVA	KILOVOLT AMPERE		
KVAR	KILOVAR		
KW	KILOWATT	W	WHITE OR WATTS
KWH	KILOWATT HOUR	WH	WATTHOUR METER
		WM	WATT METER
L	LOW, LEVEL	WP	WEATHERPROOF
LA	LIGHTNING ARRESTER	WPI	WEATHERPROOF IN-USE
LAN	LOCAL AREA NETWORK	X	AUXILIARY RELAY
LC	LIGHTING CONTACTOR	XFMR	TRANSFORMER
LOA	LOCAL-OFF-AUTO	XP	EXPLOSION PROOF
LOR	LOCAL-OFF-REMOTE		
L.P	LIGHTING PANEL		
LS	LIMIT OR LEVEL SWITCH	Y	YELLOW
LWCO	LOW WATER CUTOFF		
		Z	AUXILIARY RELAY
1-1PR#16S	ONE, SINGLE PAIR, TWISTED, SHIELDED #16 CABLE	ZS	POSITION SWITCH
3-7/C#14	THREE, SINGLE, SEVEN CONDUCTOR #14 MULTICONDUCTOR CONTROL CABLES	ZSS	ZERO SPEED SWITCH

AREA DESIGNATIONS

THE SPECIAL AREA DESIGNATION BOXES, AS DEFINED BELOW, ARE LOCATED ON THE PLAN DRAWINGS TO DEFINE ELECTRICAL INSTALLATION REQUIREMENTS. DESIGNATION BOXES ARE LOCATED WITHIN ROOM OR BELOW ROOM NUMBER. ALL INDOOR AREAS NOT INDICATED OTHERWISE ARE AREA TYPE 1 AND MINIMUM NEMA TYPE 1 ENCLOSURES.

AREA TYPE 1A

AREA TYPE 4

AREA TYPE 7A

AREA TYPE 7B

AREA TYPE 12

CORROSIVE CHEMICAL FEED AND STORAGE ROOMS.
CONDUIT SYSTEM SHALL BE EXPOSED PVC RIGID NON-METALLIC
CONDUIT WITH PVC FITTINGS, BOXES, AND ACCESSORIES.
INDOOR WET LOCATIONS SUCH AS VAULTS, HOSEDOWN AREAS,
BASEMENTS, ETC. MINIMUM NEMA TYPE 4 ENCLOSURE FOR
EQUIPMENT AND GASKETED FITTINGS IN A CONDUIT SYSTEM.
CLASS 1, DIVISION 1 AREA AS DEFINED BY NEC. ALL
EQUIPMENT AND CONDUIT SYSTEMS SHALL BE RATED FOR
USE IN THIS AREA.
CLASS 1, DIVISION 2, GROUP C AND D (METHANE, GASOLINE)
AS DEFINED BY NEC. EQUIPMENT AND CONDUITS SYSTEMS
SHALL BE RATED FOR USE IN THIS AREA.
INDOOR, DRY, DIRTY AREA. REQUIRES MINIMUM NEMA TYPE
12 GASKETED ENCLOSURES FOR ALL EQUIPMENT AND GASKETED
FITTINGS IN CONDUIT SYSTEMS.



GENERAL REQUIREMENTS

1. THE CONTRACTOR SHALL BE RESPONSIBLE FOR ROUTING ALL CONDUITS NOT SHOWN ON THE PLANS. THIS SHALL INCLUDE ALL CONDUITS SHOWN ON THE ONE-LINES AND HOME-RUNS SHOWN ON THE PLAN DRAWINGS. CONDUITS SHALL BE ROUTED AS DEFINED IN THE SPECIFICATIONS.
2. SPARE WIRES SHALL BE TAPED AND COILED.
3. IF EQUIPMENT SUPPLIED BY MANUFACTURER HAS A LARGER LOAD THAN VALUE SHOWN, THE CABLE CONDUIT AND ELECTRICAL EQUIPMENT SHALL BE ENLARGED, AS REQUIRED, TO ACCOMMODATE THE HIGHER VALUE.
4. THE CONTRACTOR SHALL BE RESPONSIBLE FOR FURNISHING PROPERLY SIZED STARTER OVERLOADS FOR EQUIPMENT FURNISHED.
5. LIGHTING AND RECEPTACLE CIRCUITS DESIGNATED ON THE FLOOR PLAN AND NOT SHOWN ON THE ONE-LINES CONDUCTORS FOR LIGHTING, RECEPTABLES, AND MISCELLANEOUS 120VAC CIRCUITS SHALL BE MINIMUM NO. 12 AWG. CONDUIT FOR LIGHTING, RECEPTABLES, AND MISCELLANEOUS 120VAC CIRCUITS SHALL BE MINIMUM 3/4".
6. IN AREAS WHERE THERE ARE OVERHEAD BRIDGE CRANES, HOISTS, ETC., NO CONDUITS SHALL BE RUN OVERHEAD THAT WILL INTERFERE WITH THE OPERATION OF THE EQUIPMENT.


GENERAL NOTES

1. SOLID LINES (————) INDICATE NEW WORK OR EQUIPMENT.
2. SCREENED LINES (-----) INDICATE EXISTING WORK OR EQUIPMENT.
3. DASHED LINES (-----) INDICATE FUTURE WORK OR EQUIPMENT.
4. REFER TO THE FOLLOWING DRAWING(S) FOR INSTRUMENTATION LEGEND: I-1, I-2, I-3
5. THIS IS A GENERAL LEGEND SHEET. SOME SYMBOLS AND ABBREVIATIONS MAY NOT BE UTILIZED ON THIS SPECIFIC PROJECT.
6. INFORMATION RELATED TO CIRCUIT IDENTIFICATION, WIRE & CONDUIT SIZES, AND ROUTING, IS ON THE FOLLOWING DRAWING TYPES.
 - A. ONE-LINE DIAGRAMS SHOW CIRCUIT IDENTIFICATION, WIRE QUANTITY AND SIZES, AND CONDUIT SIZE WITHIN STRUCTURES. ONE-LINE DIAGRAMS ALSO INDICATE ORIGIN AND DESTINATION OF CIRCUITS, AND IDENTIFY CIRCUITS ROUTED UNDERGROUND.
 - B. FOR CIRCUITS WITHOUT UNDERGROUND PORTIONS, BUILDING FLOOR PLANS SHOW LOCATION OF EQUIPMENT FOR DETERMINING CIRCUIT LENGTH WITHIN THE STRUCTURE. FOR CIRCUITS WITH UNDERGROUND PORTIONS, ANTICIPATED PENETRATION OF UNDERGROUND CONDUITS ARE SHOWN ON STRUCTURE PLANS FOR DETERMINING THE LENGTH OF THE IN-STRUCTURE PORTIONS OF CIRCUITS. BUILDING FLOOR PLANS MAY ALSO SHOW HOME RUNS FOR LIGHTING, RECEPTACLE, AND OTHER MISCELLANEOUS EQUIPMENT CIRCUITS.
 - C. SITE PLANS INDICATE THE GENERAL ROUTING OF UNDERGROUND CONDUITS AND DUCT BANKS. CIRCUITS ROUTED IN UNDERGROUND CONDUITS OR DUCT BANKS ARE INDICATED IN DUCT BANK SECTIONS REFERENCED ON THE SITE PLAN.
 - D. DUCT BANK SECTIONS AND SCHEDULES IDENTIFY CONDUIT SIZE CONDUIT MATERIAL, ARRANGEMENT OF THE UNDERGROUND CONDUITS, AND CIRCUITS ROUTED IN EACH UNDERGROUND CONDUIT.

WTP

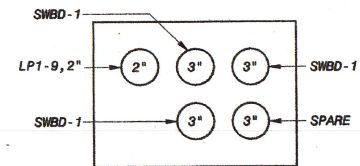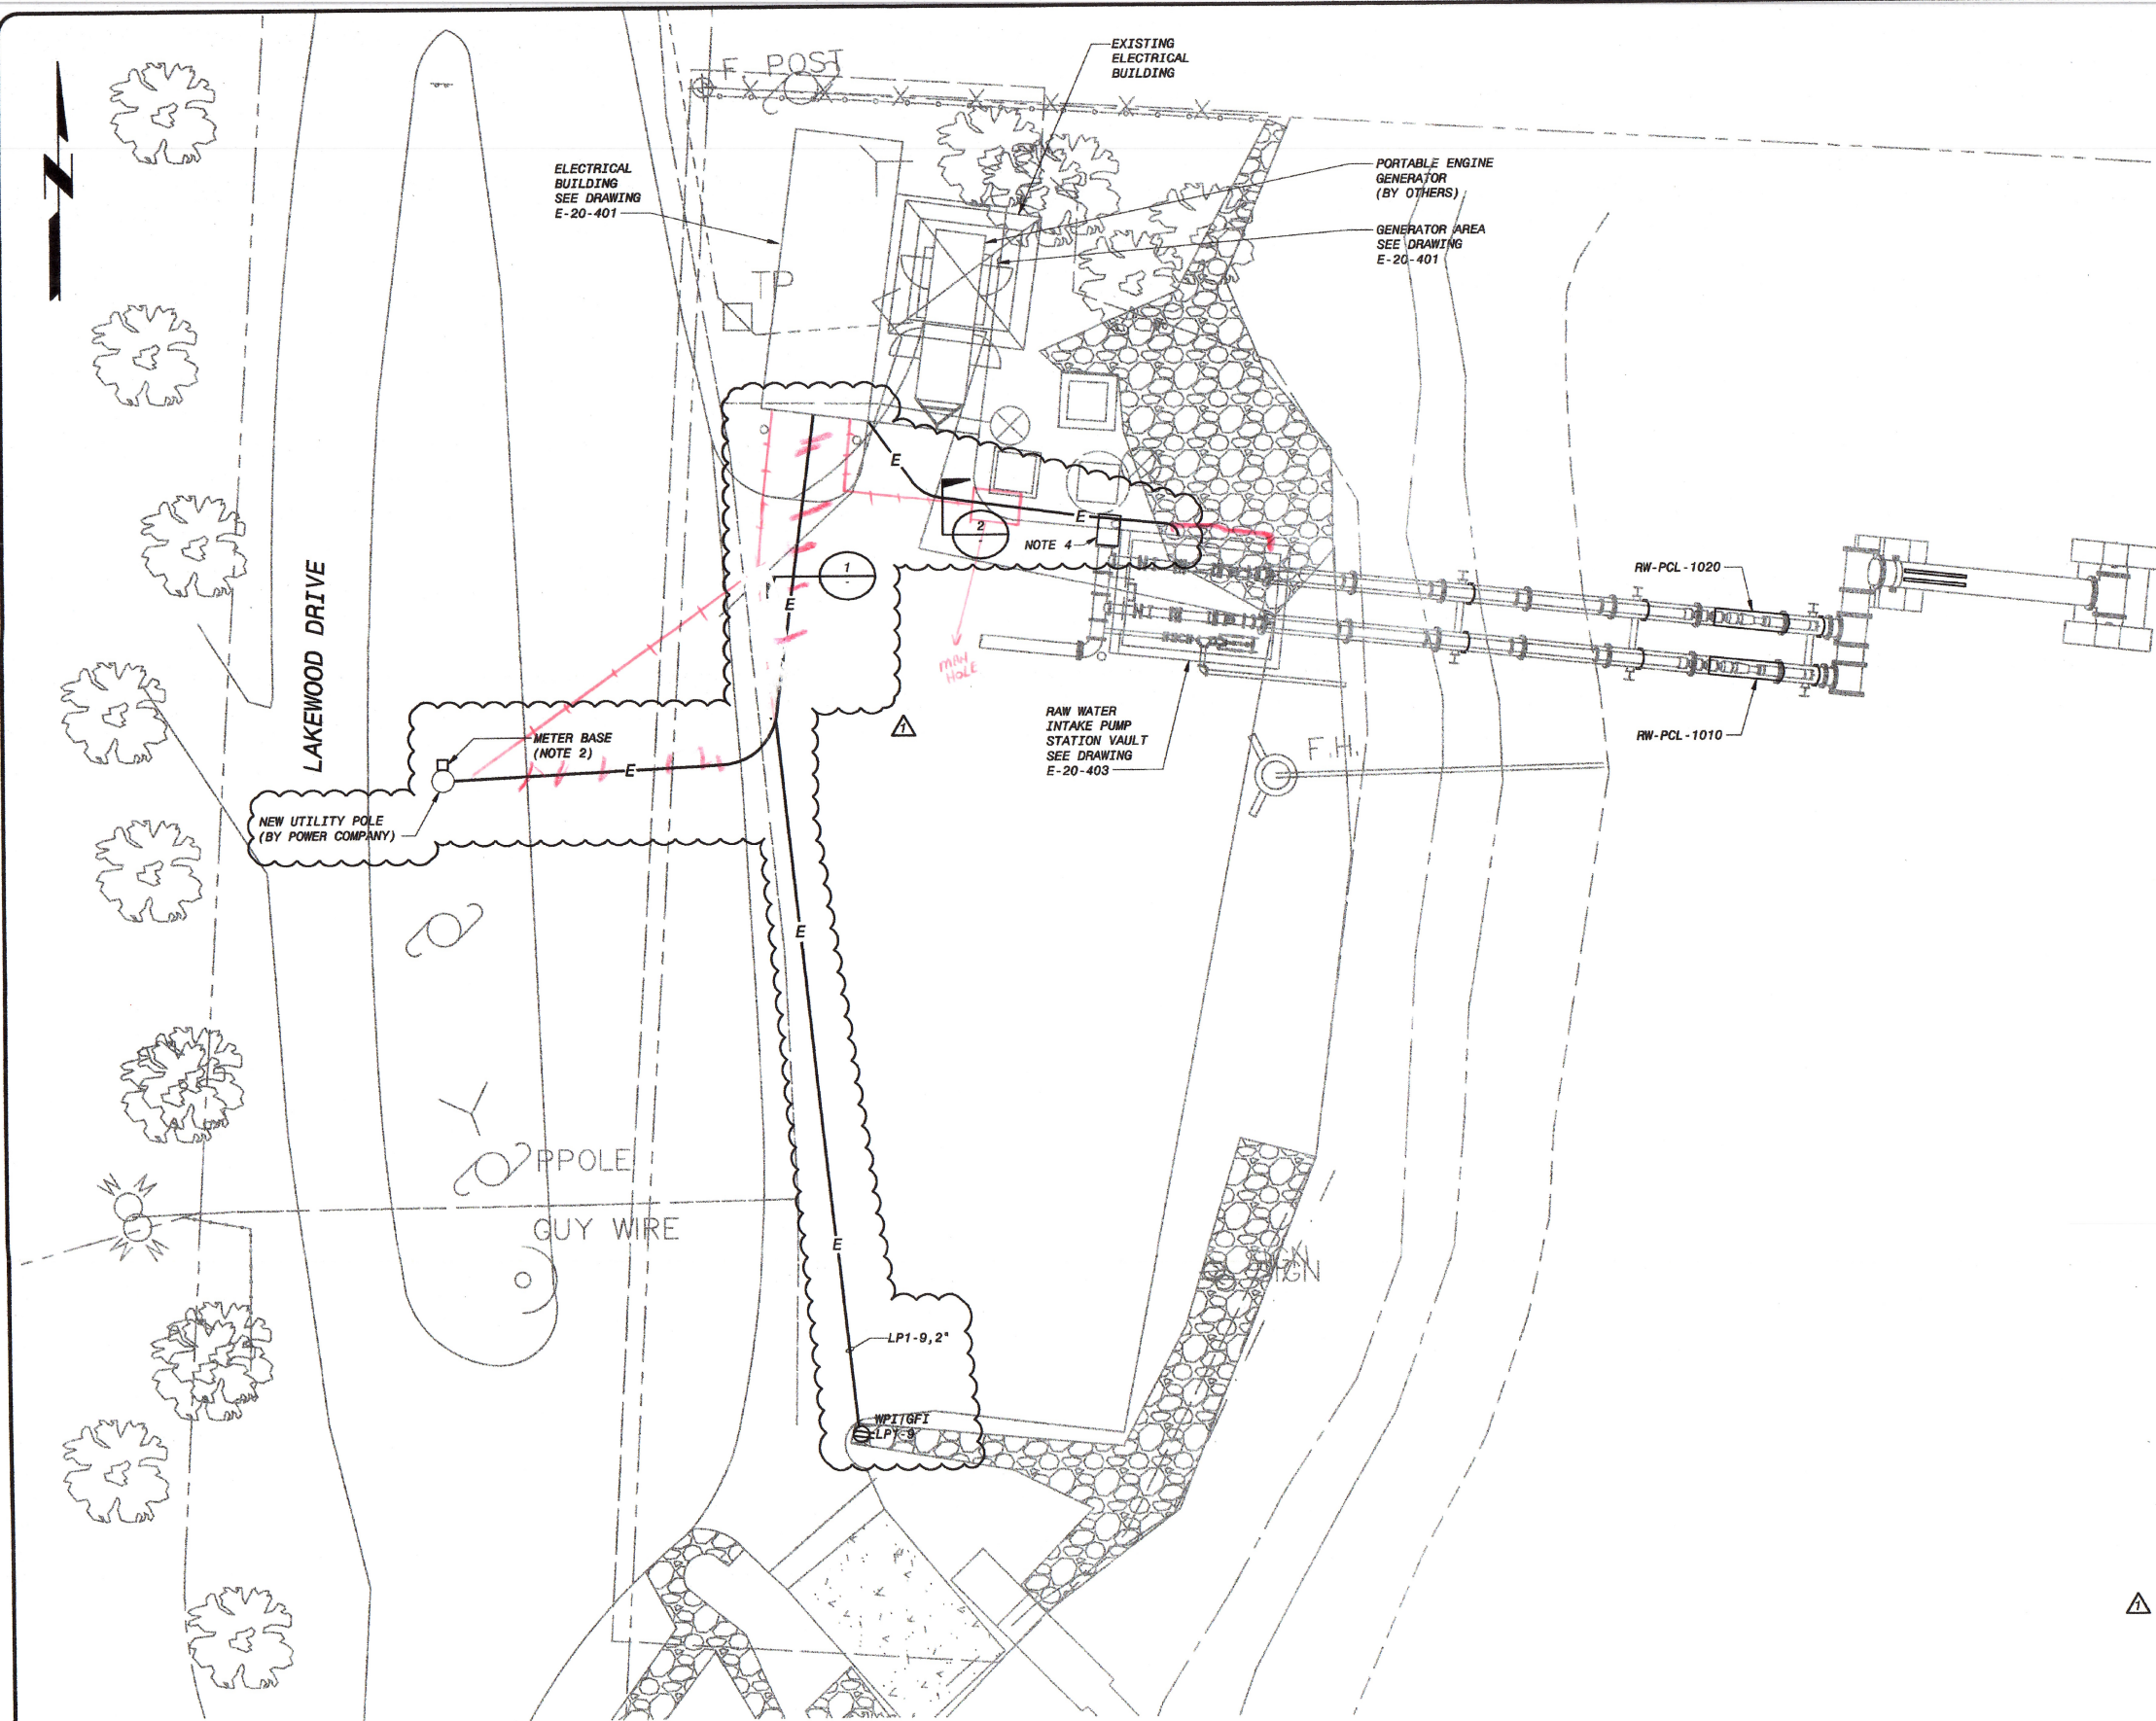


SECTION 1
NO SCALE

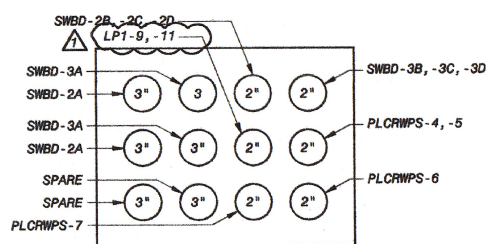

SECTION 2
NO SCALE
(NOTE 3)


NOTES:

 - SEE DRAWING E-00-001 FOR ELECTRICAL LEGEND AND ABBREVIATIONS & GENERAL REQUIREMENTS.
- COORDINATE WITH POWER COMPANY TO DETERMINE LOCATION OF METER BASE. LOCATION SHOWN IS BASED ON TRANSFORMER MOUNTED CURRENT TRANSFORMERS.
- CONTRACTOR SHALL FIELD COORDINATE DUCT BANK LOCATION TO AVOID EXISTING BURIED INFRASTRUCTURE.
- IN ORDER TO AVOID CONFLICT WITH FUTURE PIPING THE TOP OF DUCT BANK WITHIN SPECIFIED BOUNDARY SHALL BE AT AN ELEVATION NO GREATER THAN 797.5'.



ISSUED FOR CONSTRUCTION

NO.	BY	DATE	REVISIONS AND RECORD OF ISSUE
1	ZKO	01/12/16	GENERAL REVISIONS
2	ZKO	02/04/16	ISSUED FOR CONSTRUCTION
3	ZKO	02/04/16	REVISIONS AND RECORD OF ISSUE
4	ZKO	02/04/16	REVISIONS AND RECORD OF ISSUE
5	ZKO	02/04/16	REVISIONS AND RECORD OF ISSUE
6	ZKO	02/04/16	REVISIONS AND RECORD OF ISSUE
7	ZKO	02/04/16	REVISIONS AND RECORD OF ISSUE
8	ZKO	02/04/16	REVISIONS AND RECORD OF ISSUE
9	ZKO	02/04/16	REVISIONS AND RECORD OF ISSUE
10	ZKO	02/04/16	REVISIONS AND RECORD OF ISSUE

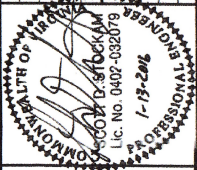


BLACK & VEATCH
Building a world of difference.
Black & Veatch Corporation
Virginia Beach, VA

**BEDFORD REGIONAL WATER AUTHORITY
SMITH MOUNTAIN LAKE WTP &
RAW WATER PUMPING STATION / INTAKE
ELECTRICAL
INTAKE STRUCTURE
SITE PLAN**


DESIGNED: ZKO
DRAWN: DGP
CHECKED: SDS
APPROVED:
DATE: 01/12/16
PROJECT NO. 189317

E-20-101
SHEET OF

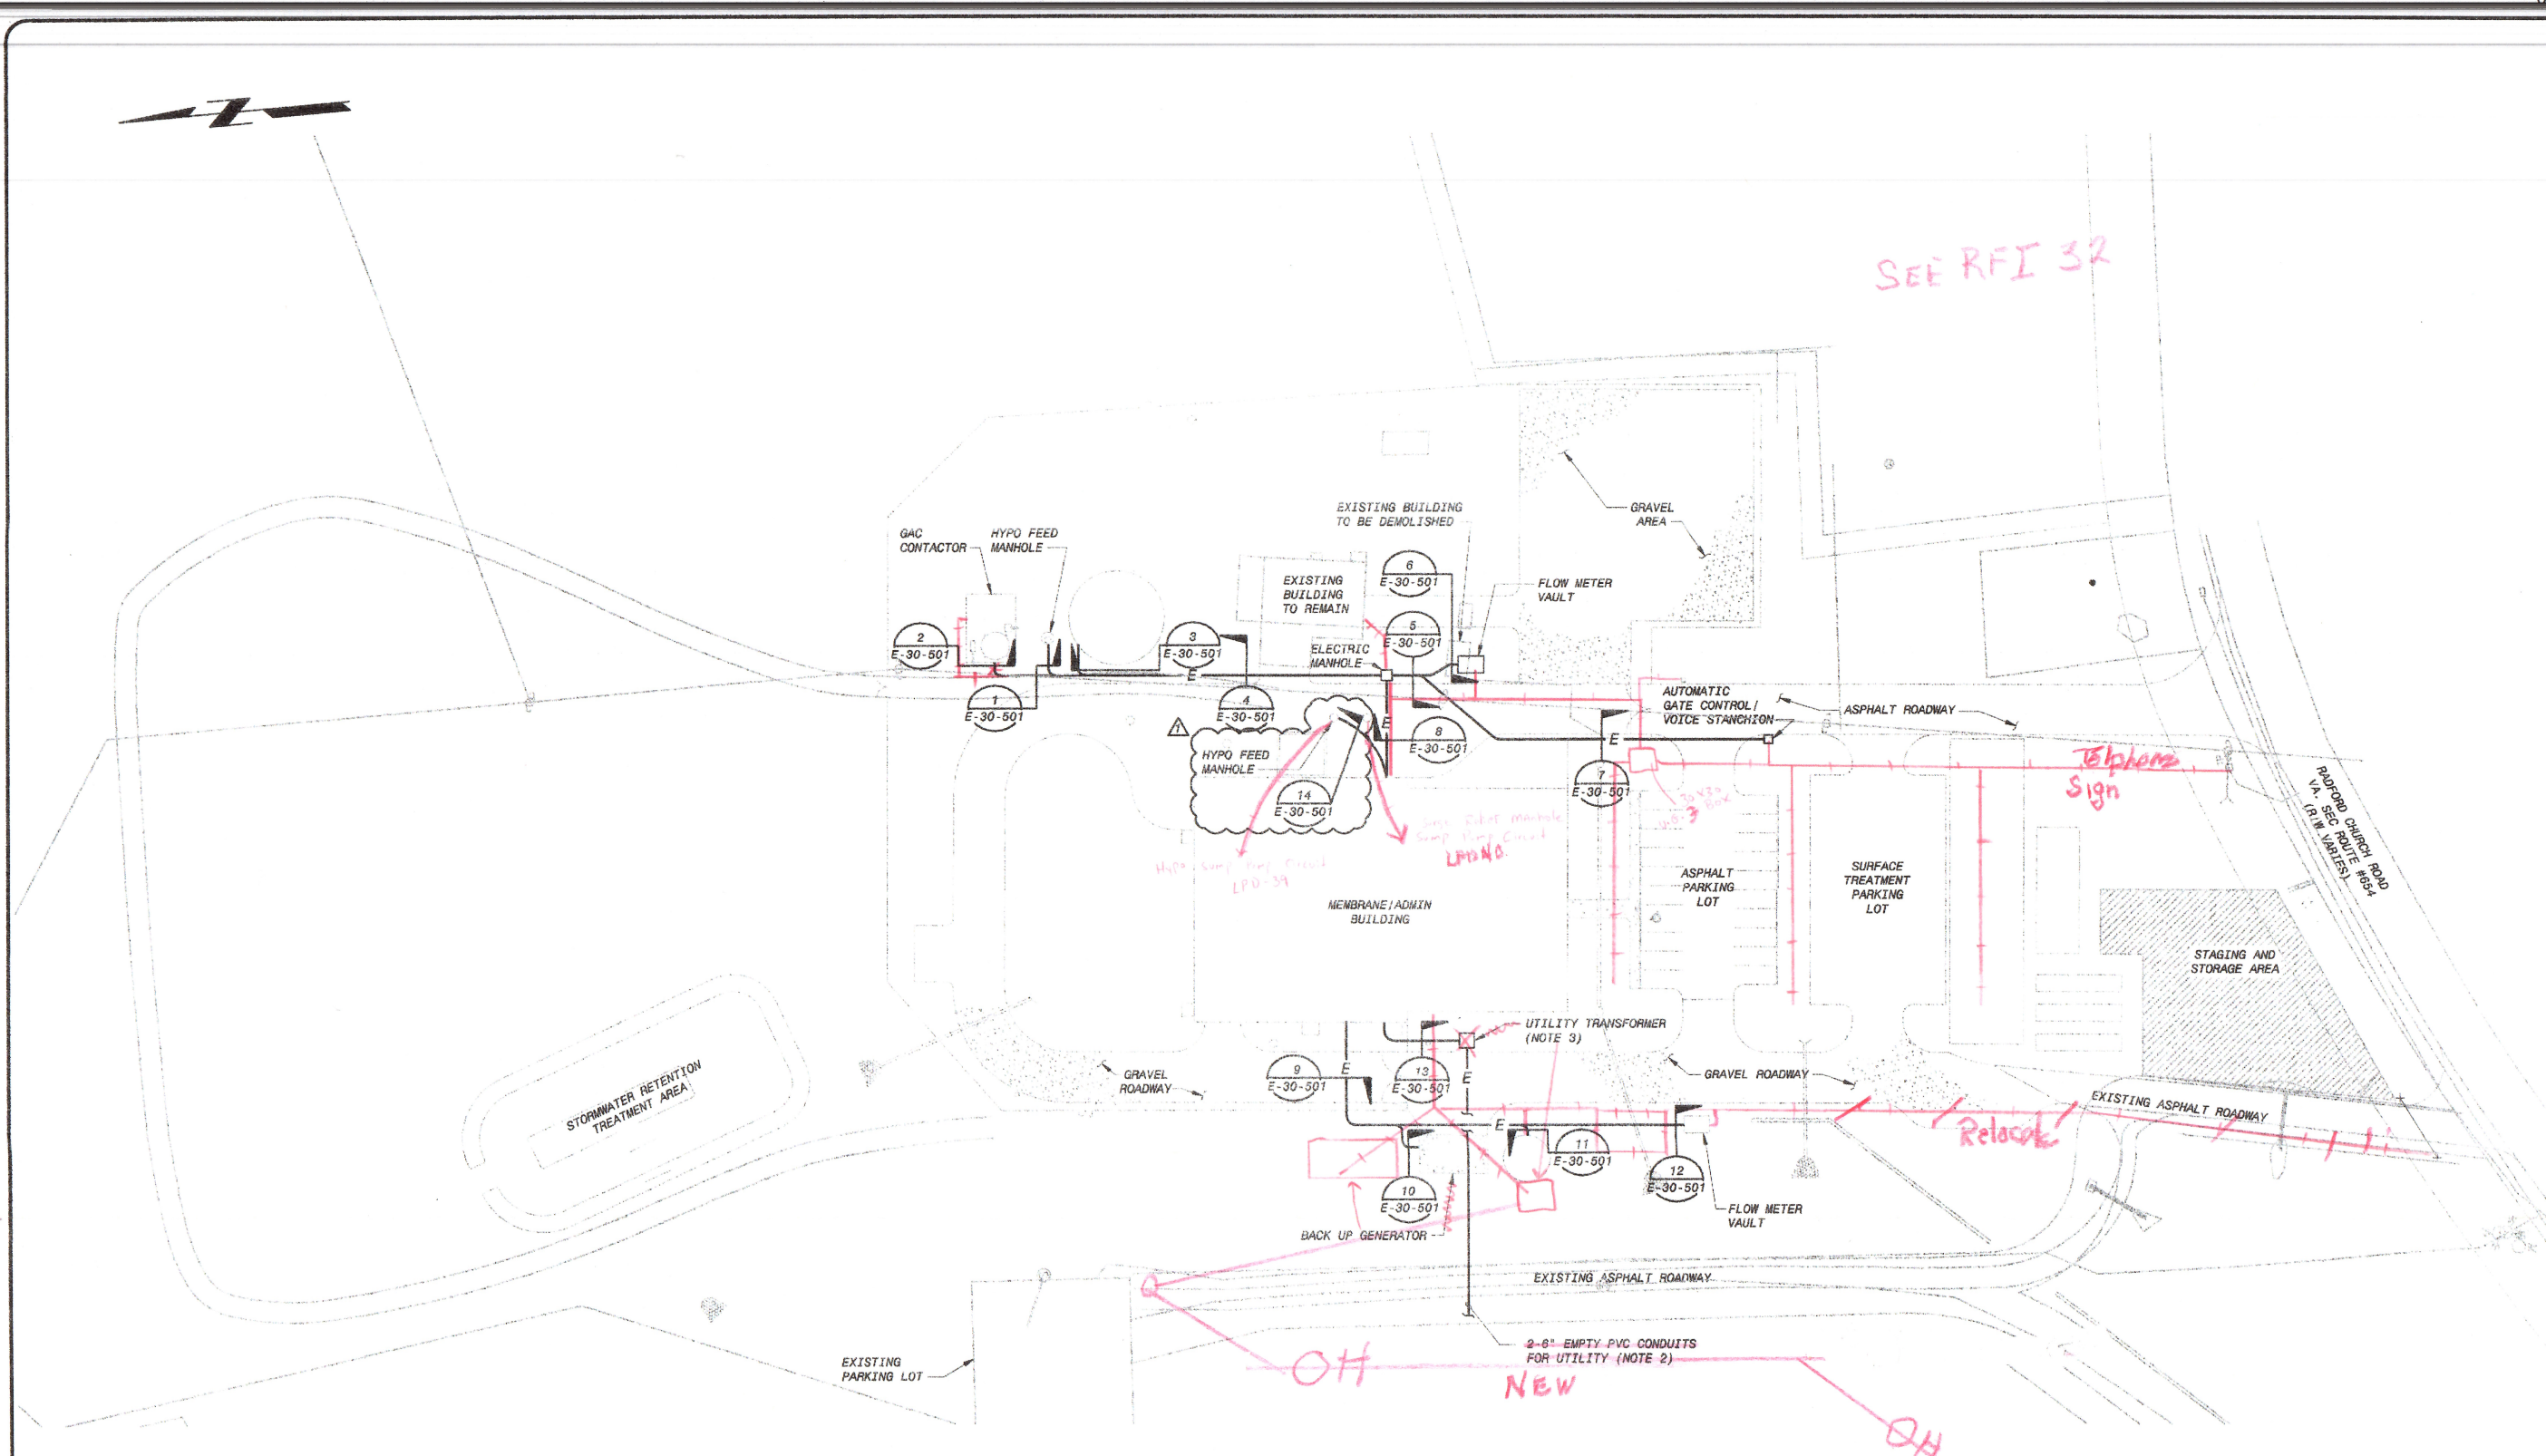



MEMBRANE BUILDING - SITE PLAN
1" = 40' - 0"

 - NOTES:**
- SEE DRAWING E-00-001 FOR ELECTRICAL LEGEND & ABBREVIATIONS AND GENERAL REQUIREMENTS.
 - COORDINATE WITH POWER COMPANY REGARDING REQUIREMENTS FOR UTILITY SERVICE AND INSTALLATION.
 - UTILITY TRANSFORMER SHALL BE PER POWER COMPANY REQUIREMENTS.



ISSUED FOR CONSTRUCTION

DESIGNED: ZKO		CHECKED: SDS		DATE: 01/11/16													
DETAILED: DGP		APPROVED:		DATE: 01/11/16													
IF THIS BAR DOES NOT MEASURE 1" THEN DRAWING IS NOT TO FULL SCALE PROJECT NO. 189317 E-30-101 SHEET OF																	
BLACK & VEATCH Building a world of difference. Black & Veatch Corporation Virginia Beach, VA																	
BEDFORD REGIONAL WATER AUTHORITY SMITH MOUNTAIN LAKE WTP & RAW WATER PUMPING STATION / INTAKE MEMBRANE BUILDING SITE PLAN																	
REVISIONS <table border="1"> <thead> <tr> <th>NO.</th> <th>BY</th> <th>DATE</th> <th>REVISIONS AND RECORD OF ISSUE</th> </tr> </thead> <tbody> <tr> <td>1</td> <td>ZKO</td> <td>01/11/16</td> <td>GENERAL REVISIONS</td> </tr> <tr> <td>2</td> <td>ZKO</td> <td>01/11/16</td> <td>ISSUED FOR CONSTRUCTION</td> </tr> </tbody> </table> PLOTTED: 01/11/16 PLOTTER: DRE66804 USER: DRE66804						NO.	BY	DATE	REVISIONS AND RECORD OF ISSUE	1	ZKO	01/11/16	GENERAL REVISIONS	2	ZKO	01/11/16	ISSUED FOR CONSTRUCTION
NO.	BY	DATE	REVISIONS AND RECORD OF ISSUE														
1	ZKO	01/11/16	GENERAL REVISIONS														
2	ZKO	01/11/16	ISSUED FOR CONSTRUCTION														

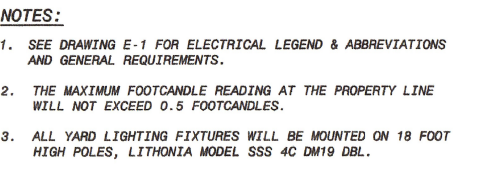 


LIGHTING FIXTURE MODELS:

FIXTURE TYPE 1: LITHONIA# - KAD LED 40C 1000 40K R2 480
SPD 04 PER7 HS DBLXL DLL480F1.5 CUL

FIXTURE TYPE 2: LITHONIA# - KAD LED 40C 1000 40K R3 480
SPD 04 PER7 HS DBLXL DLL480F1.5 CUL

 FIXTURE TYPE 3: LITHONIA# - KAD LED 40C 1000 40K R4 480
SPD 04 PER7 HS DBLXL DLL480F1.5 CUL



ISSUED FOR CONSTRUCTION

[illegible]

Black & Veatch
Building a world of difference:


Black & Veatch Corporation
Virginia Beach, VA

**BEDFORD REGIONAL WATER AUTHORITY
SMITH MOUNTAIN LAKE WTP &
RAW WATER PUMPING STATION / INTAKE**

DESIGNED:	ZKO
DETAILED:	DAH
CHECKED:	SDS
APPROVED:	
DATE:	01/11/16
 IF THIS BAR DOES NOT MEASURE 1" THEN DRAWING IS NOT TO FULL SCALE	
PROJECT NO. 189317	
E-30-102 SHEET OF	

GENERAL NOTES

1. CIRCUIT ALL EXIT SIGNS TO PANEL HV CIRCUIT 10 WITH 2#10, 1#10G IN 3/4" C.

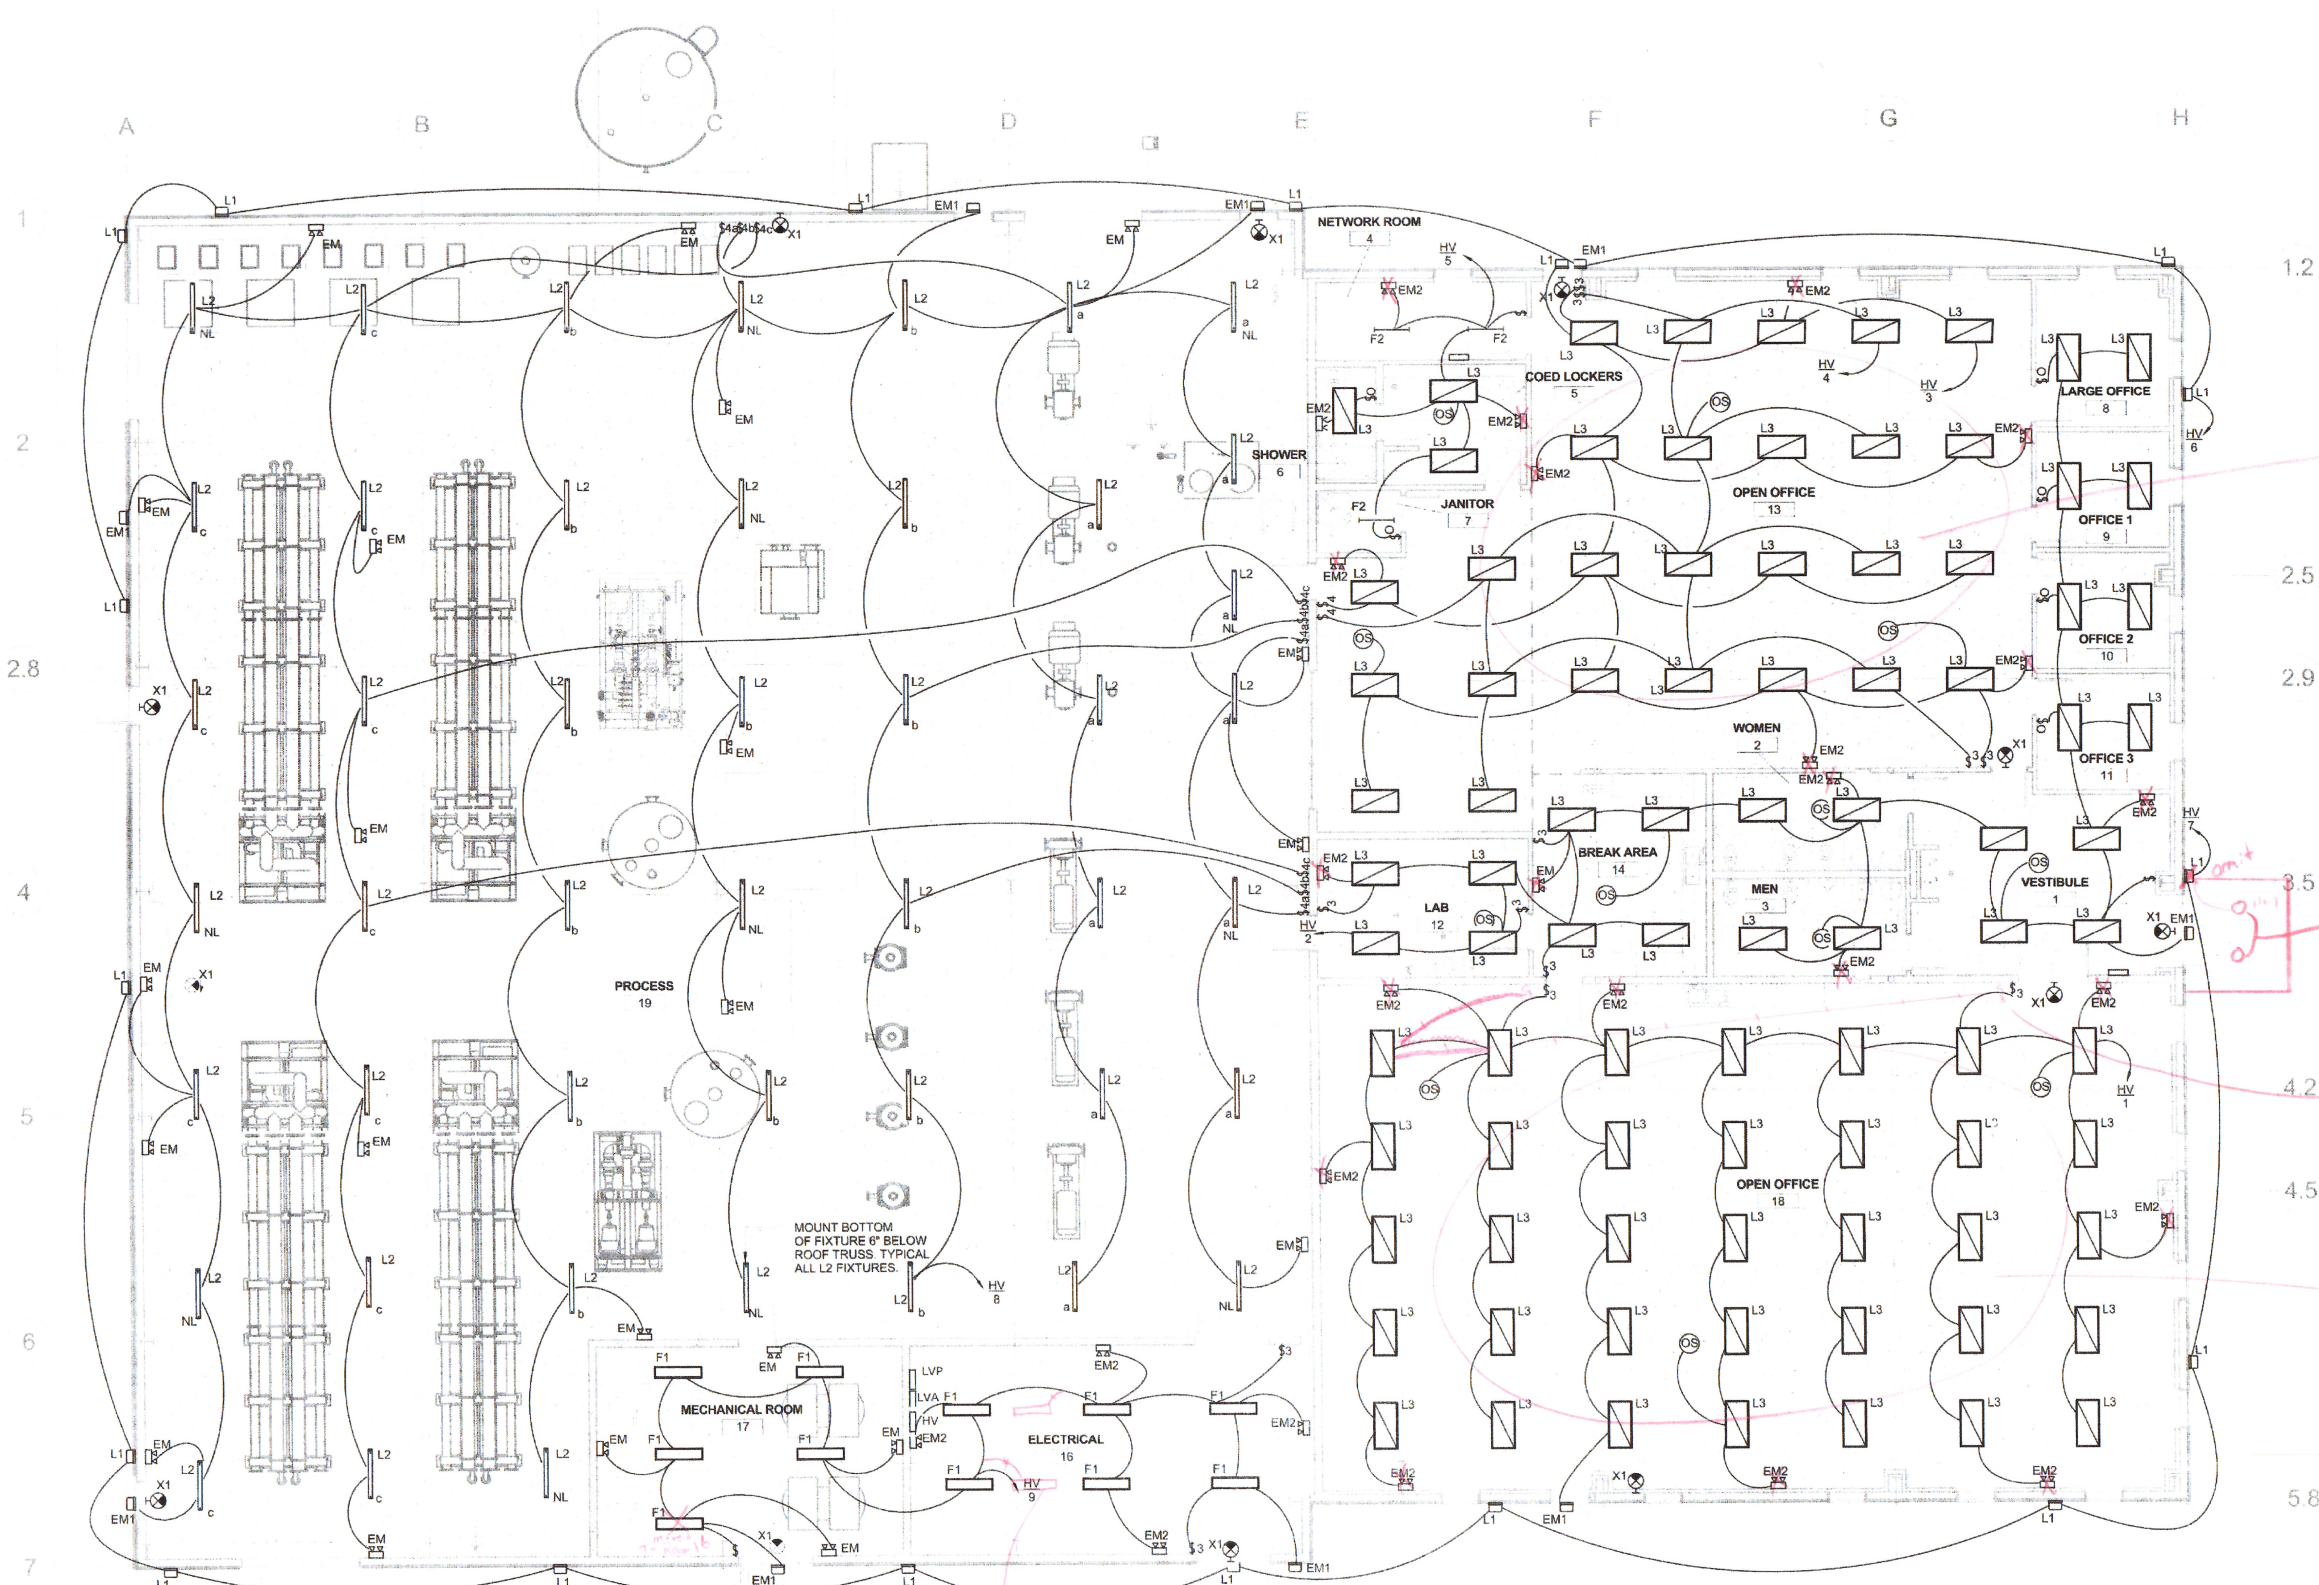

New Lighting Layout on Following Page

2-4\"/>


Area 2, stay within for Regular Plan of Lights

New Lighting Layout on Following Page

1 LIGHTING PLAN - OPERATING FLOOR
1/8" = 1'-0"


ISSUED FOR CONSTRUCTION

ISSUED FOR CONSTRUCTION REVISIONS AND RECORD OF ISSUE DATE: 01/06/16 BY: CHK APP NO. BY: CHK APP PROJECT: V:\Projects\BWA\27872\27872-0001_REVIT\08 ELEC\27872-0001-08 ELEC.dwg SAVED: 1/7/2016 9:45:31 AM PLOT: 1/7/2016 9:45:31 AM USER: DNG VER: A		BLACK & VEATCH Building a world of difference Black & Veatch Corporation Kansas City, Missouri		BEDFORD REGIONAL WATER AUTHORITY SMITH MOUNTAIN LAKE WTP & LAKES TO FOREST WATER LINE EXTENSION ELECTRICAL MEMBRANE/ADMIN LIGHTING PLAN	
DESIGNED: MA DETAILED: CJE CHECKED: MLS APPROVED: MLS DATE: 8/14/15		IF THIS BAR DOES NOT MEASURE 1" THEN DRAWING IS NOT TO FULL SCALE		CHA PROJECT NO. 27872 E-30-401 SHEET OF	

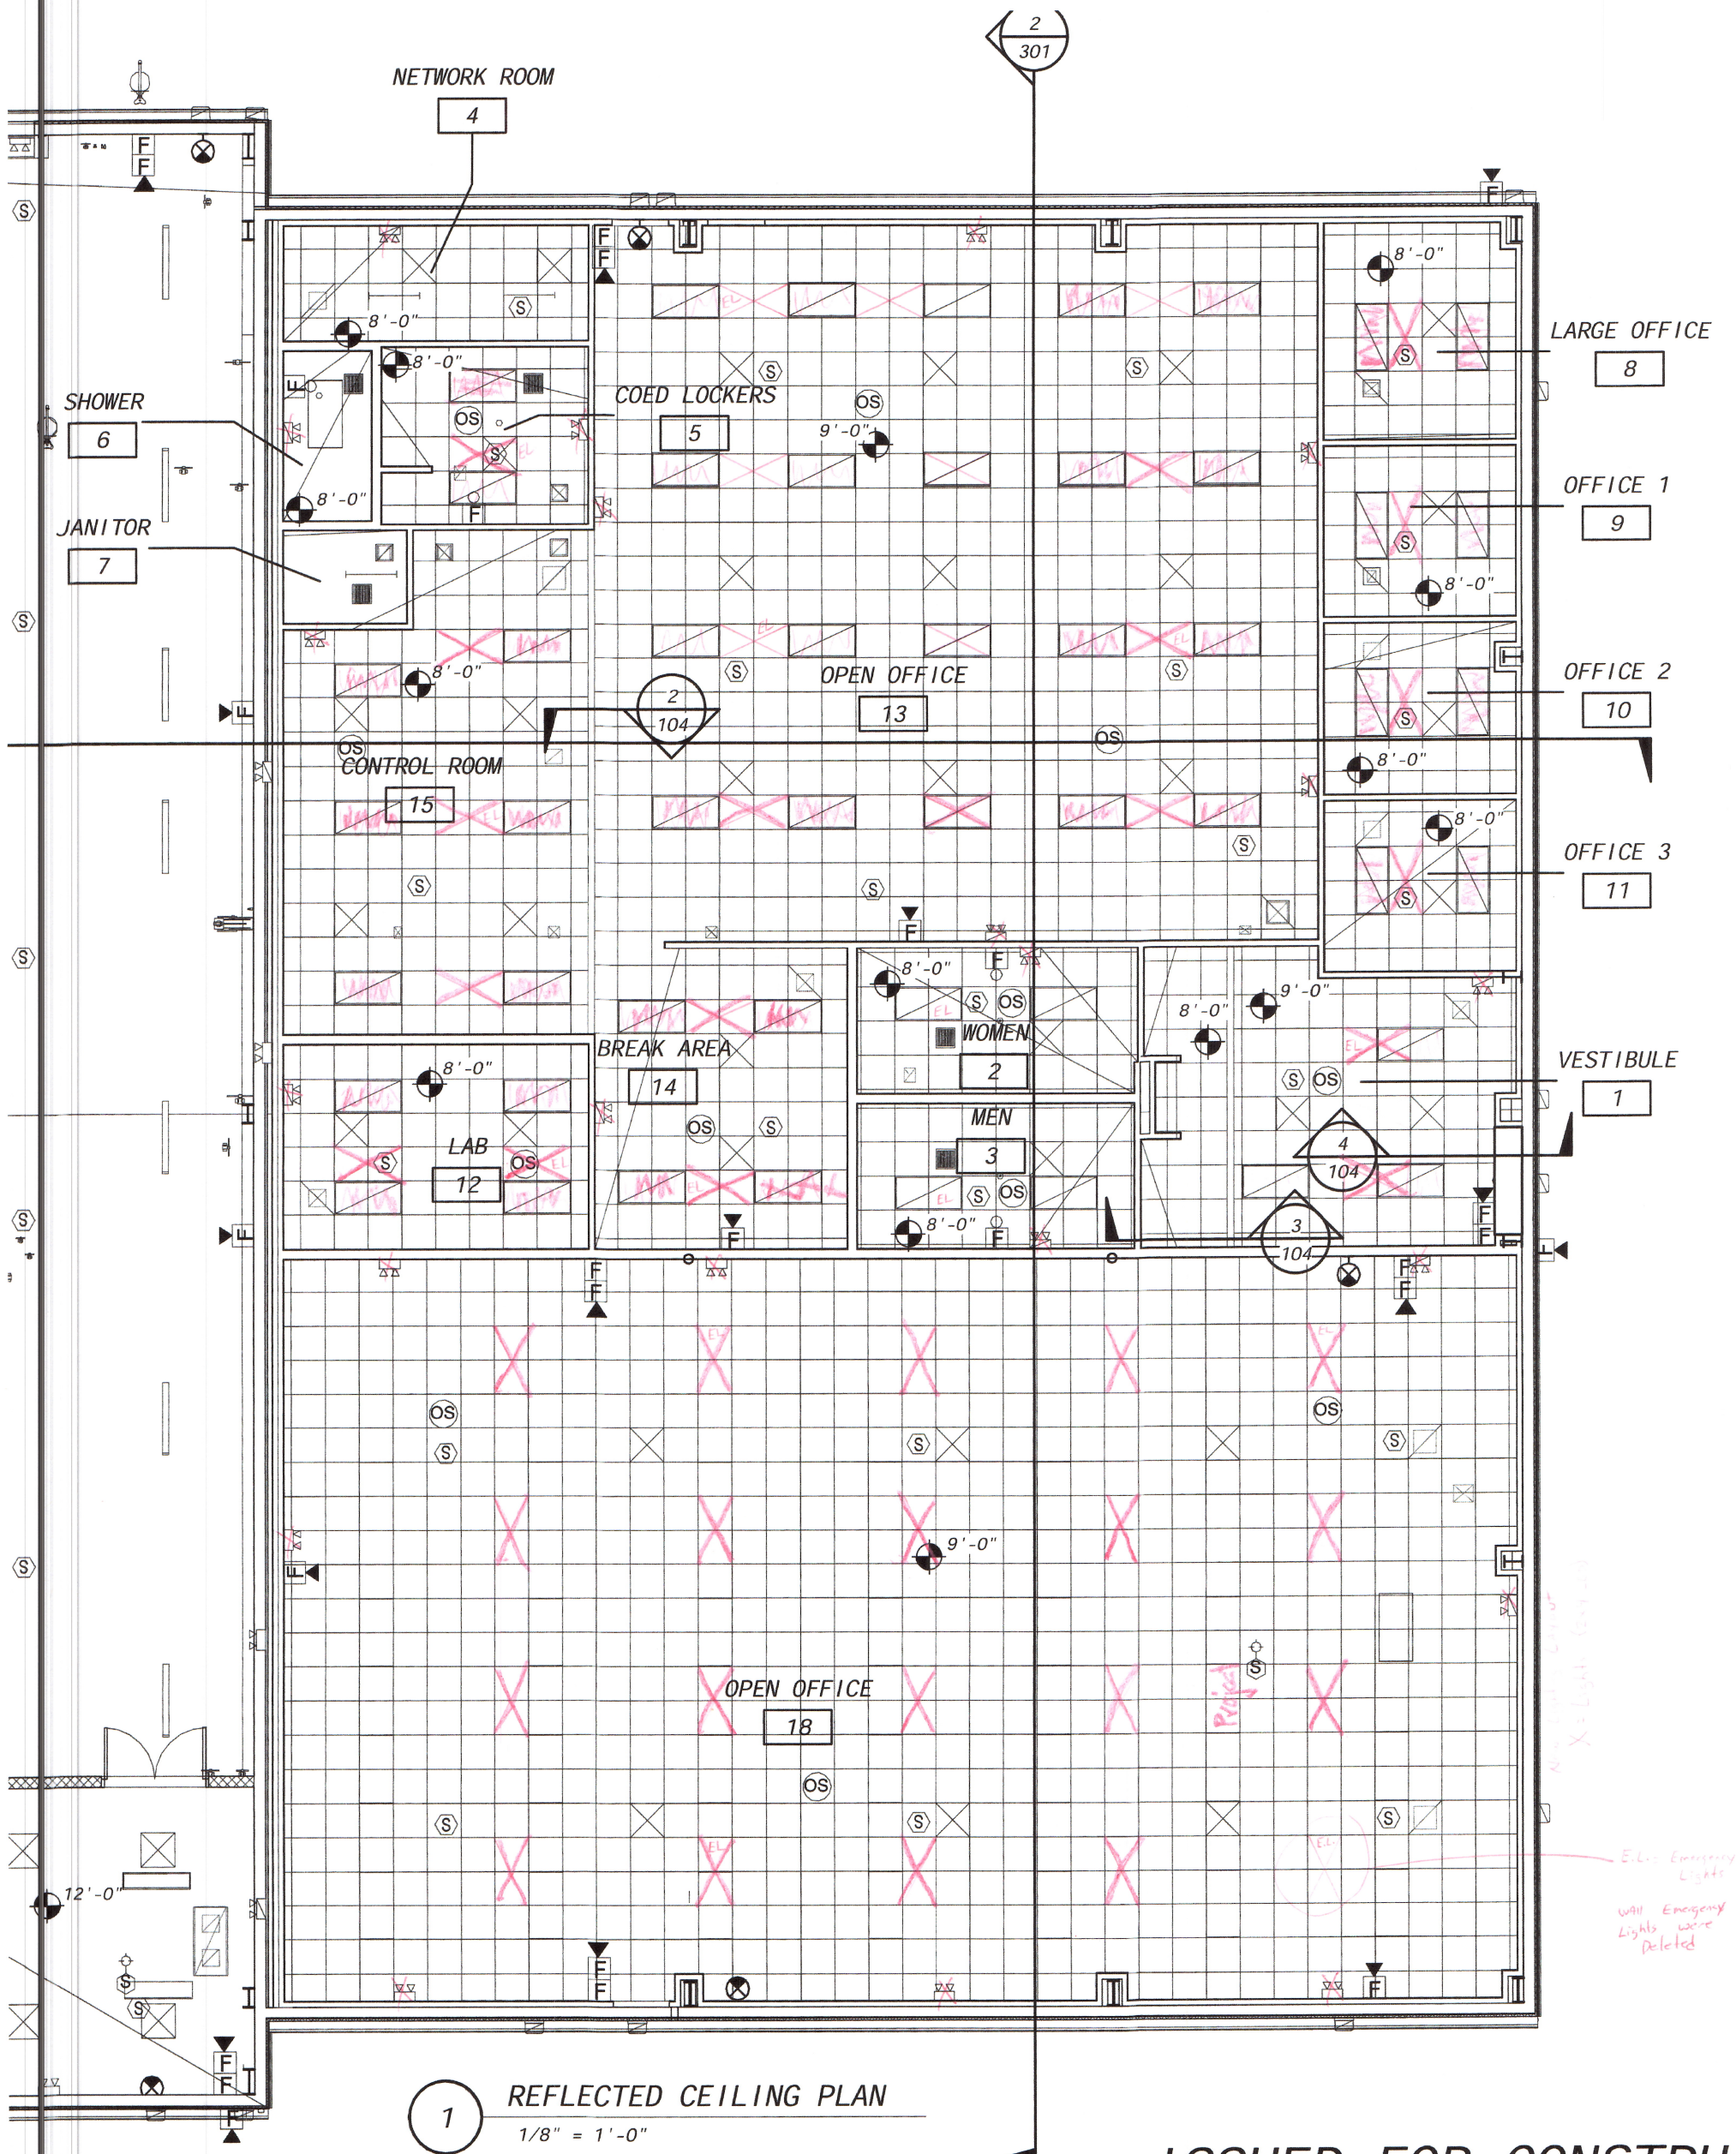




LVP = Now IS LP-C
LVA = Now IS LP-B

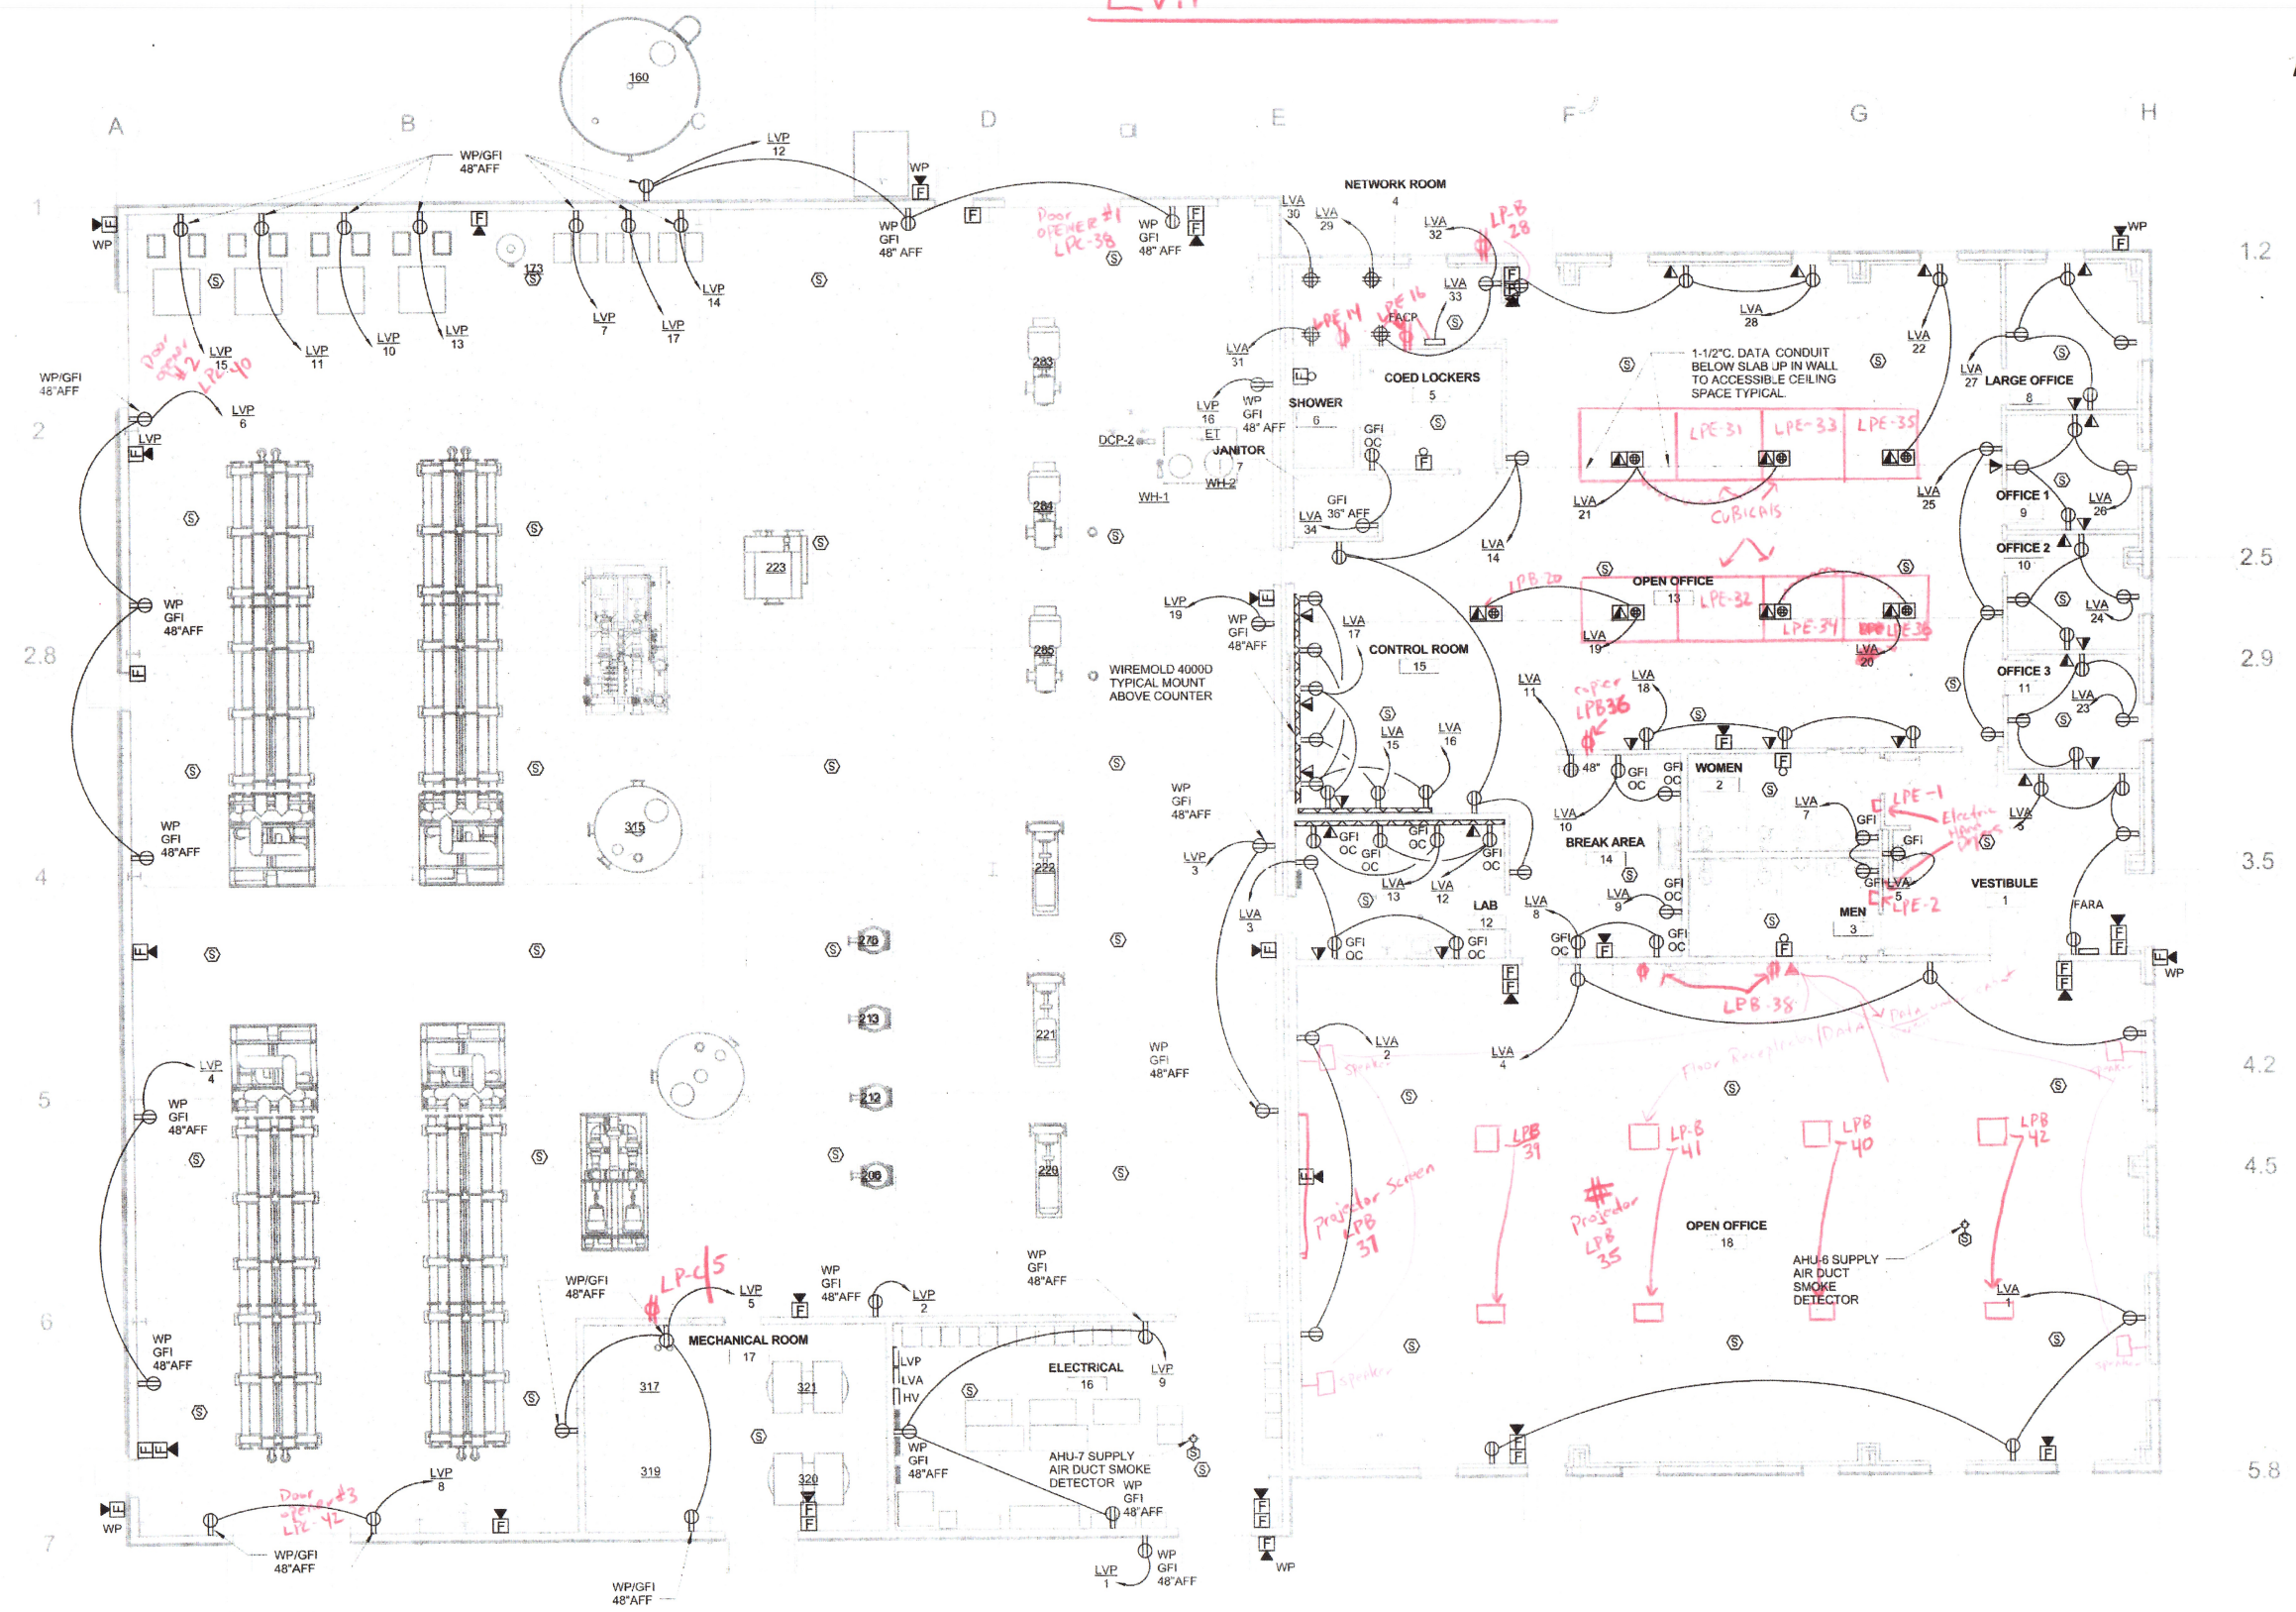

1 POWER PLAN - OPERATING FLOOR
1/8" = 1'-0"


ISSUED FOR CONSTRUCTION

ISSUED FOR CONSTRUCTION REVISIONS AND RECORD OF ISSUE DATE: 06/16/16 DRAWN: J. B. MILLER CHECKED: J. B. MILLER APPROVED: J. B. MILLER DATE: 06/16/16		XREF1: 1/17/2016 9:45:50 AM XREF2: 1/17/2016 9:45:50 AM XREF3: 1/17/2016 9:45:50 AM XREF4: 1/17/2016 9:45:50 AM	
BLACK & VEATCH Building a world of difference Black & Veatch Corporation Kansas City, Missouri		BEDFORD REGIONAL WATER AUTHORITY SMITH MOUNTAIN LAKE WTP & LAKES TO FOREST WATER LINE EXTENSION ELECTRICAL CONVENIENCE POWER AND SYSTEMS PLAN	
DESIGNED: JMA CHECKED: CJE APPROVED: MJS DATE: 8/14/15		CHA PROJECT NO. 27872 E-30-402 SHEET OF	

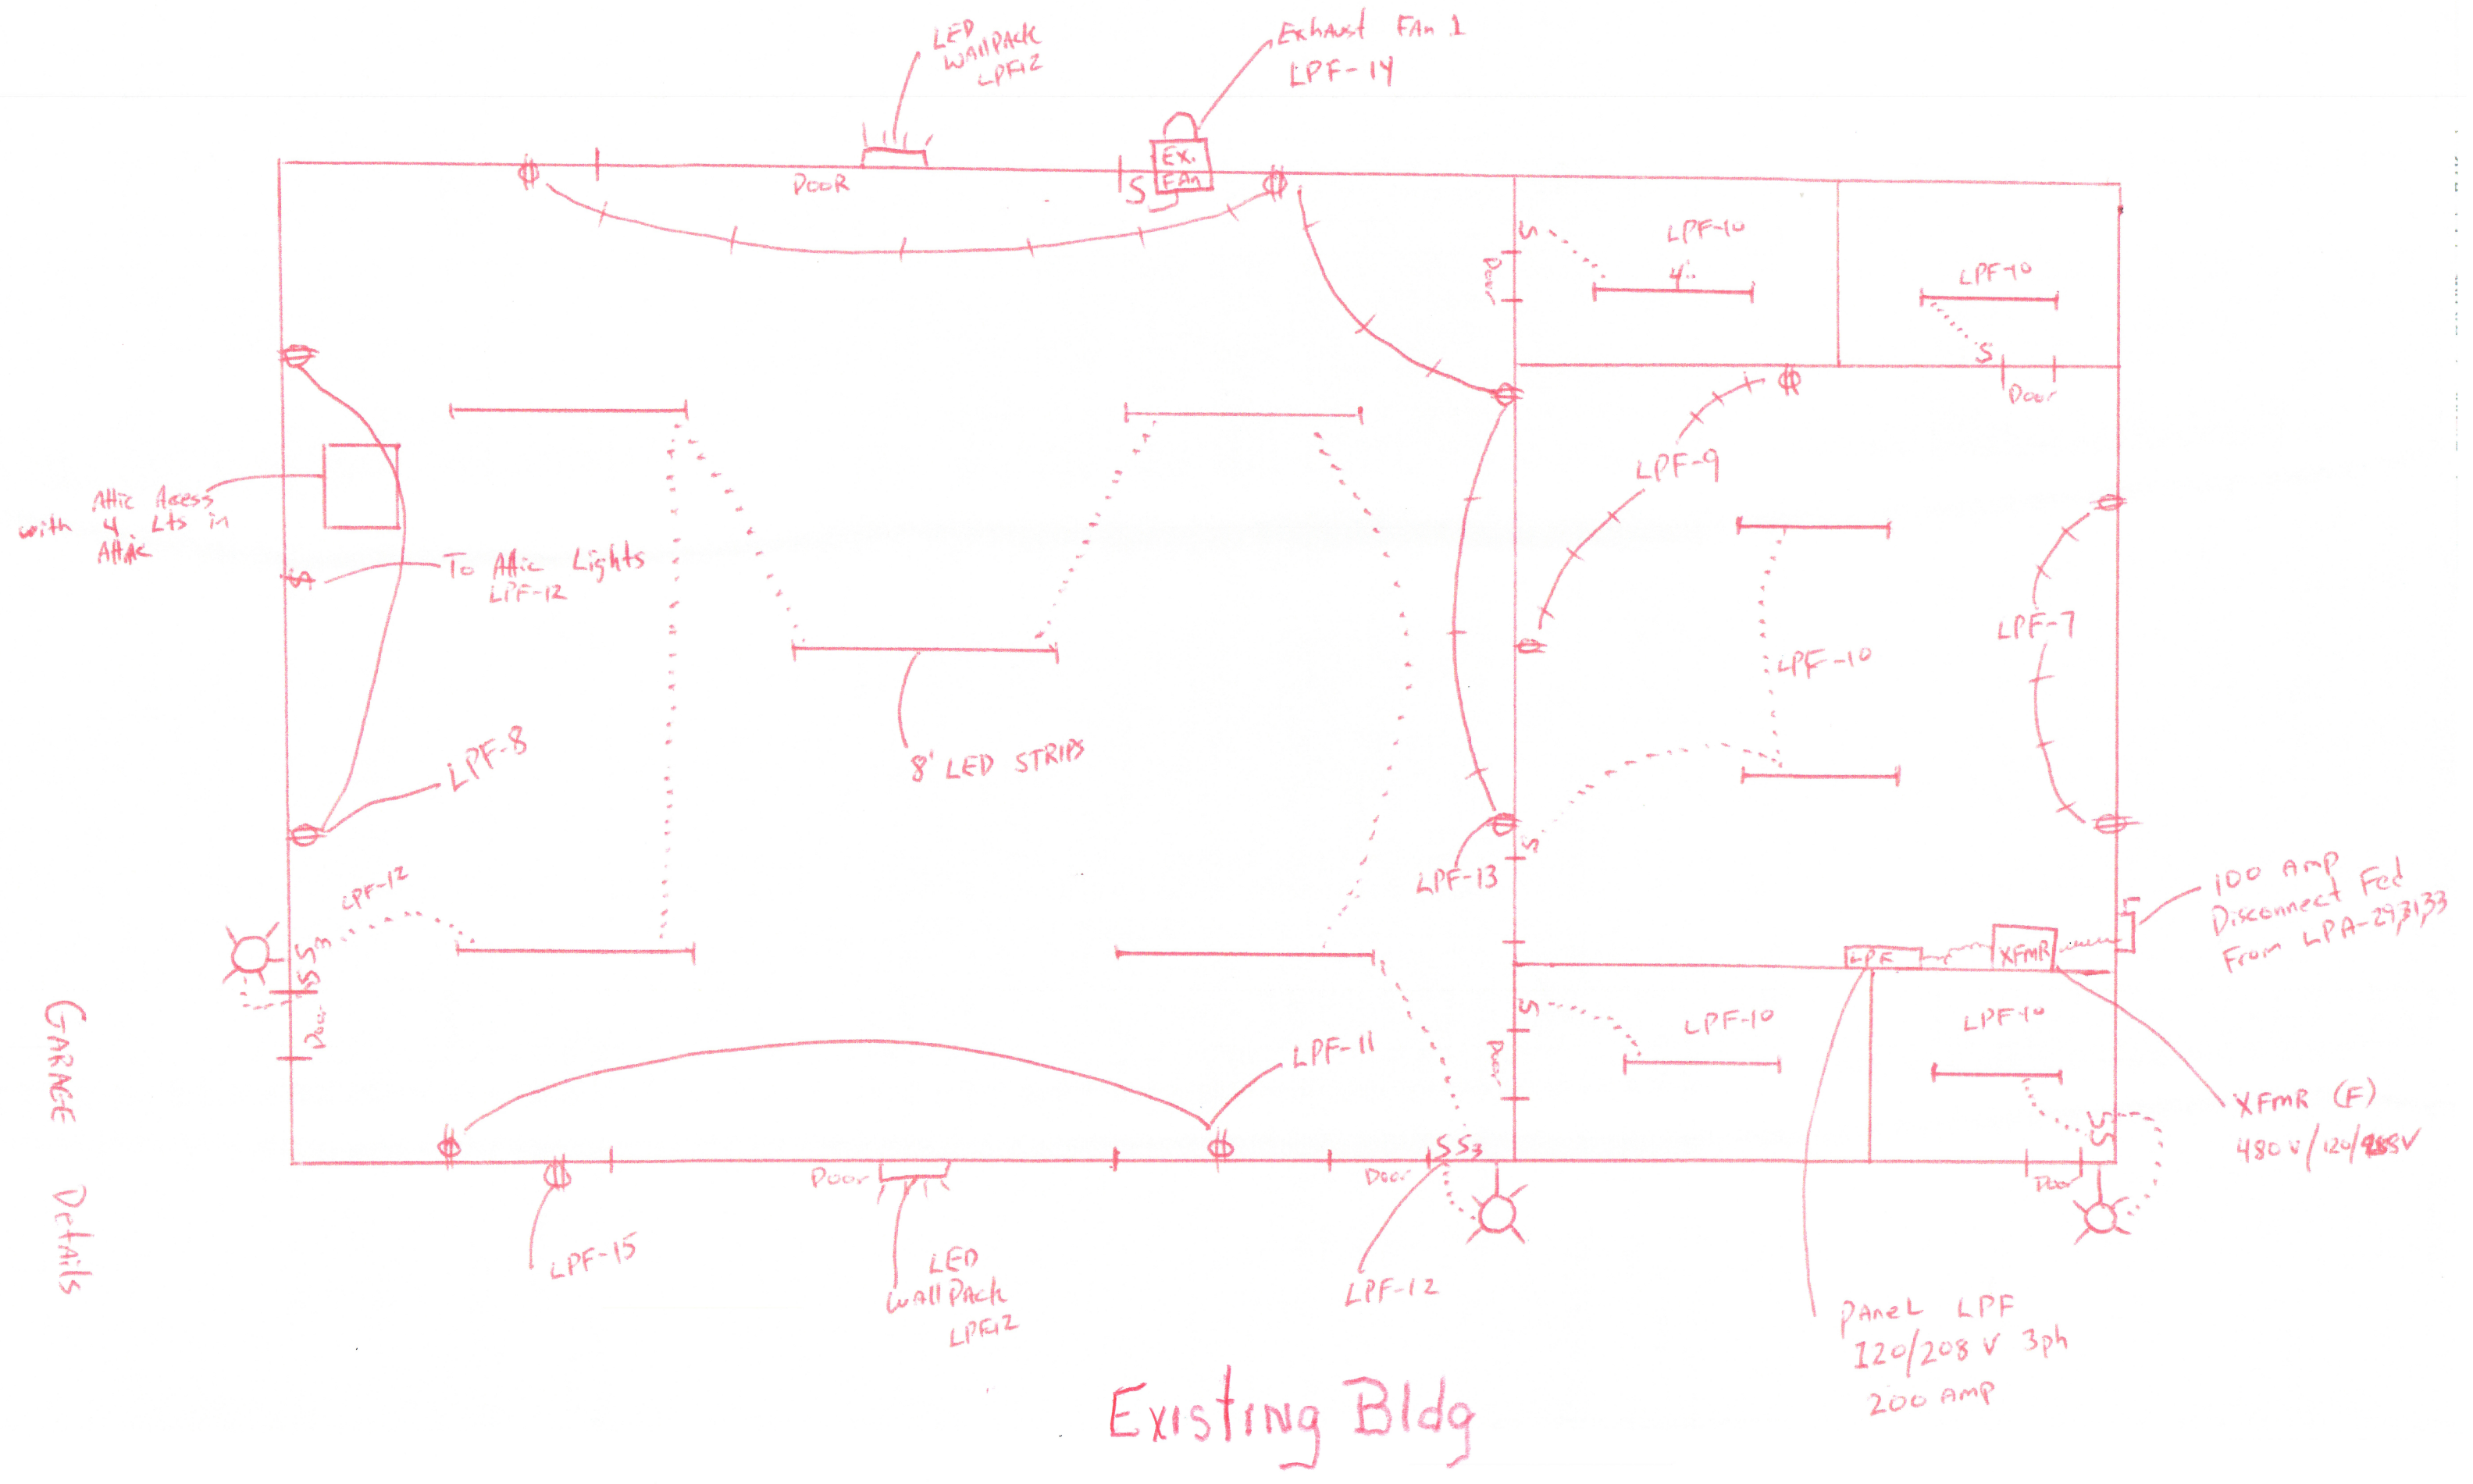

Existing Bldg


GARAGE Details

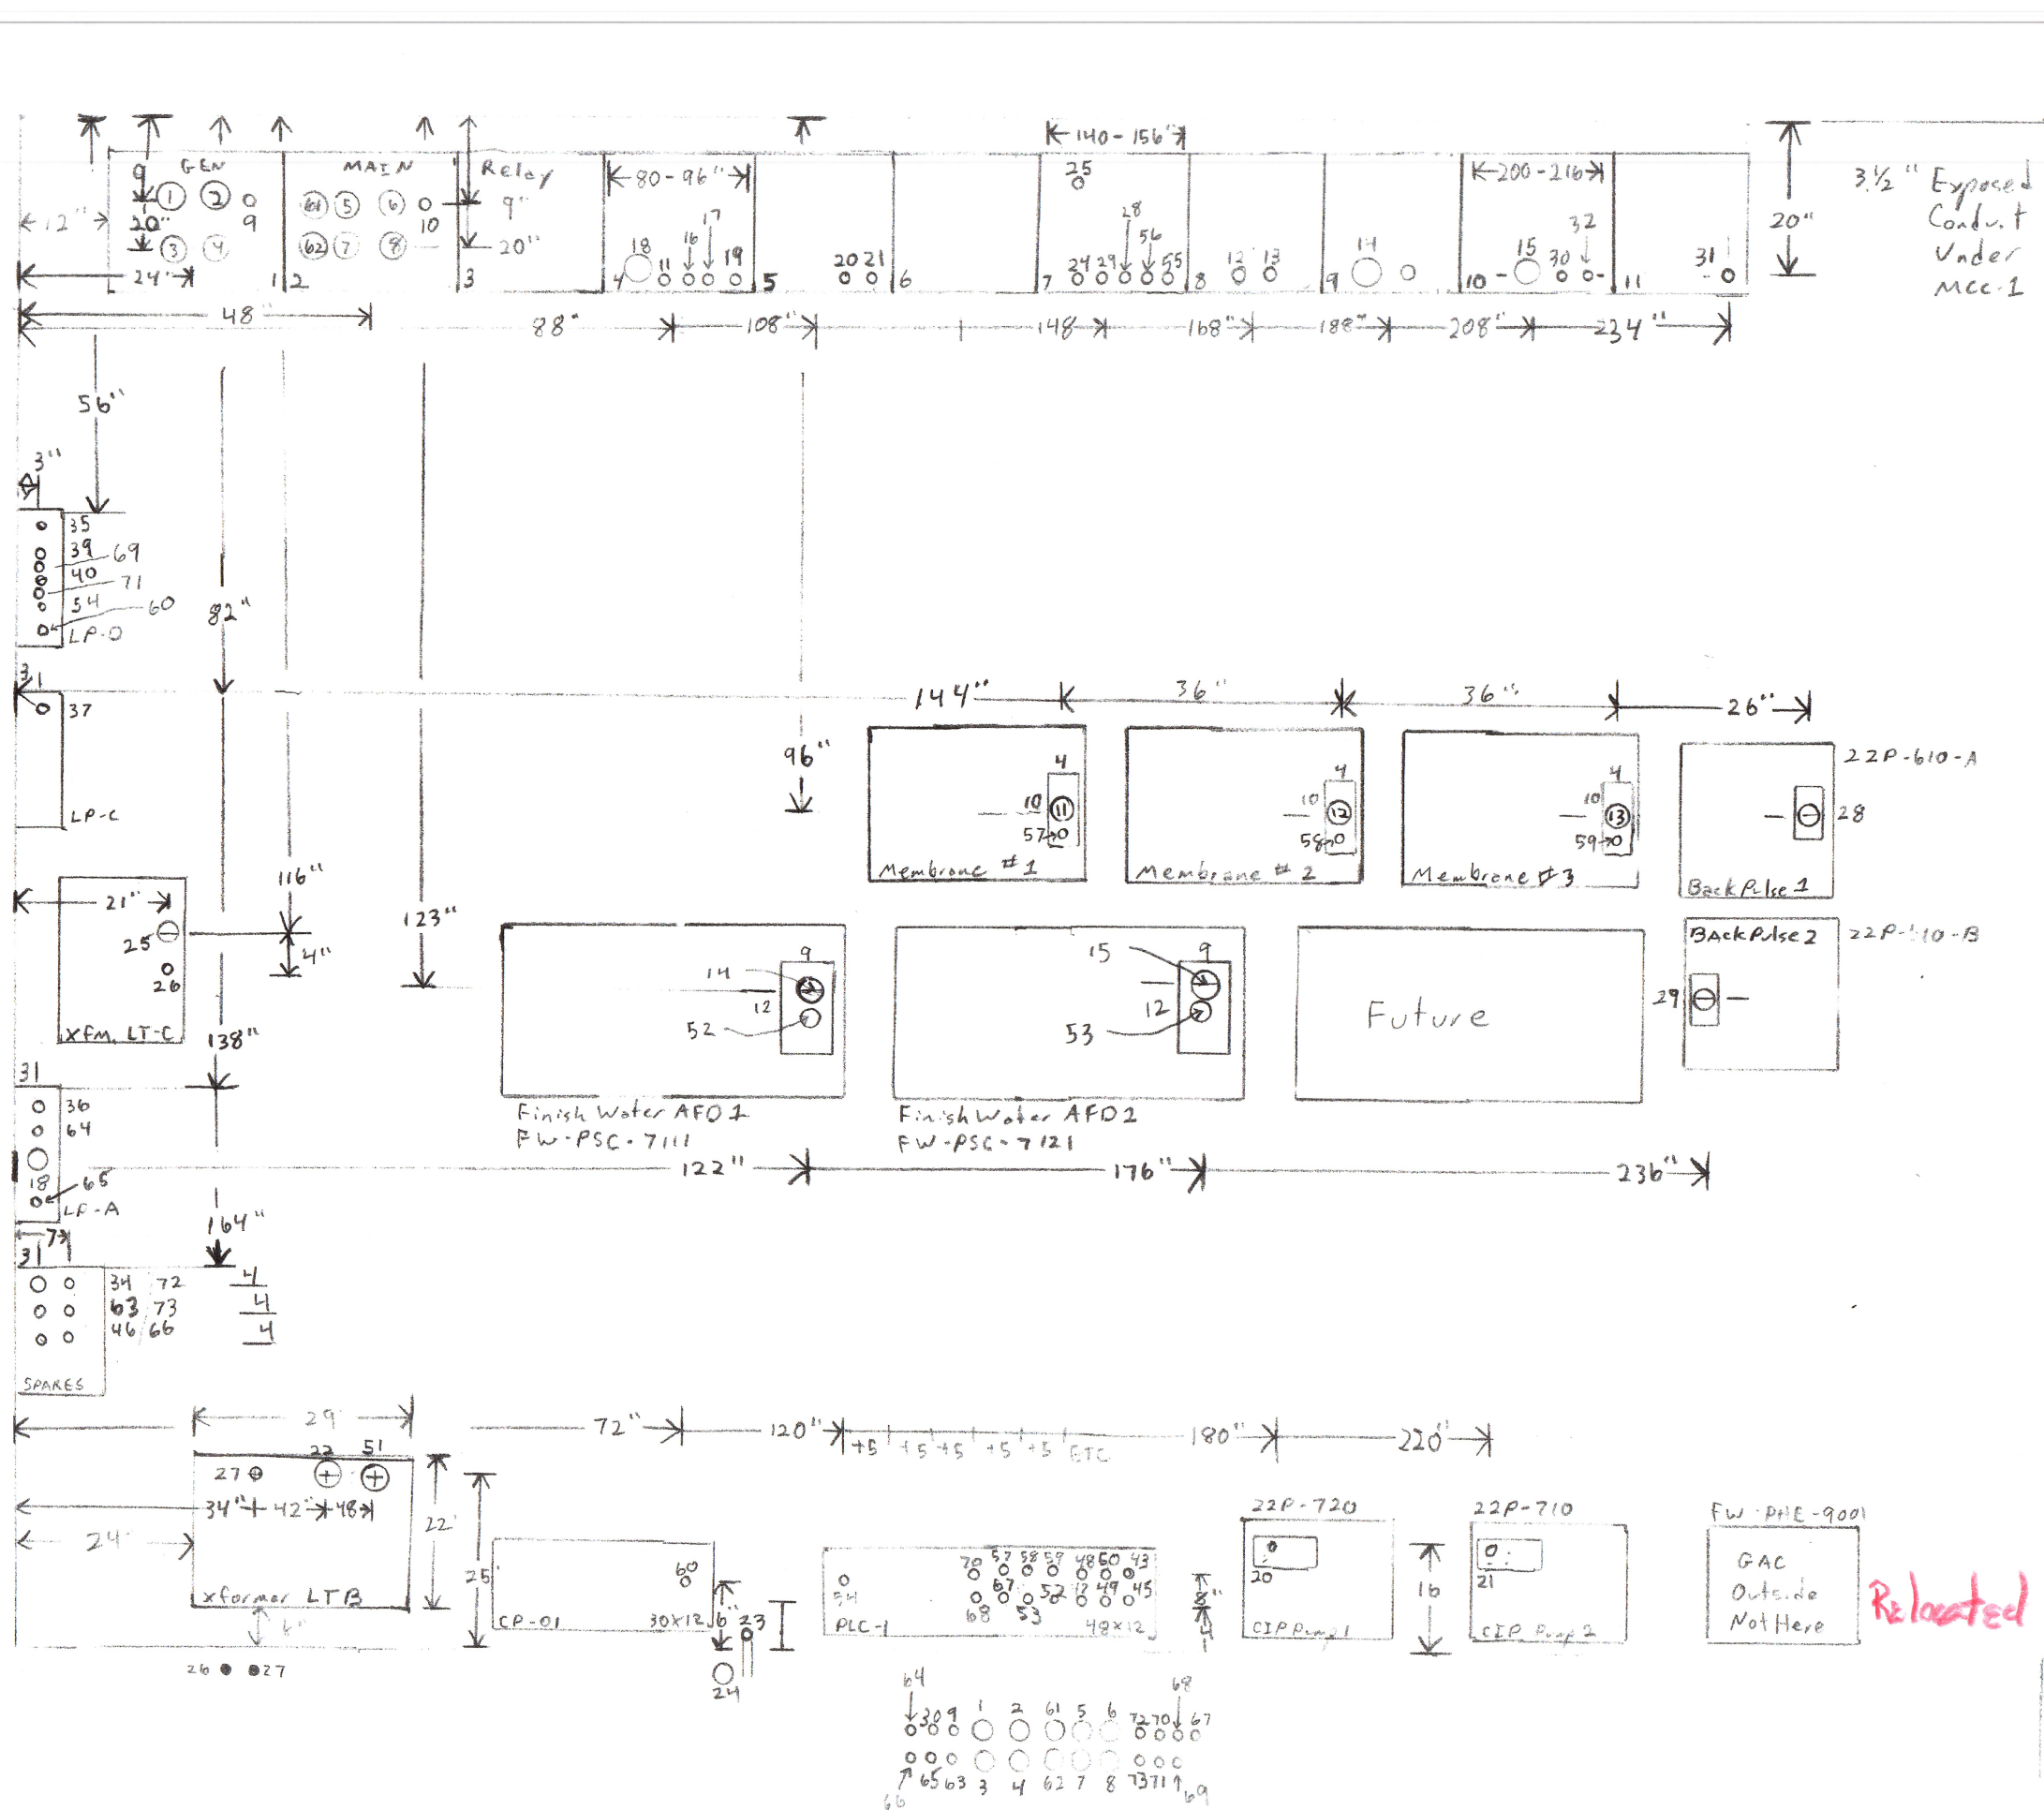

DOORWAY

NEW Electrical Room Layout

DOORWAY

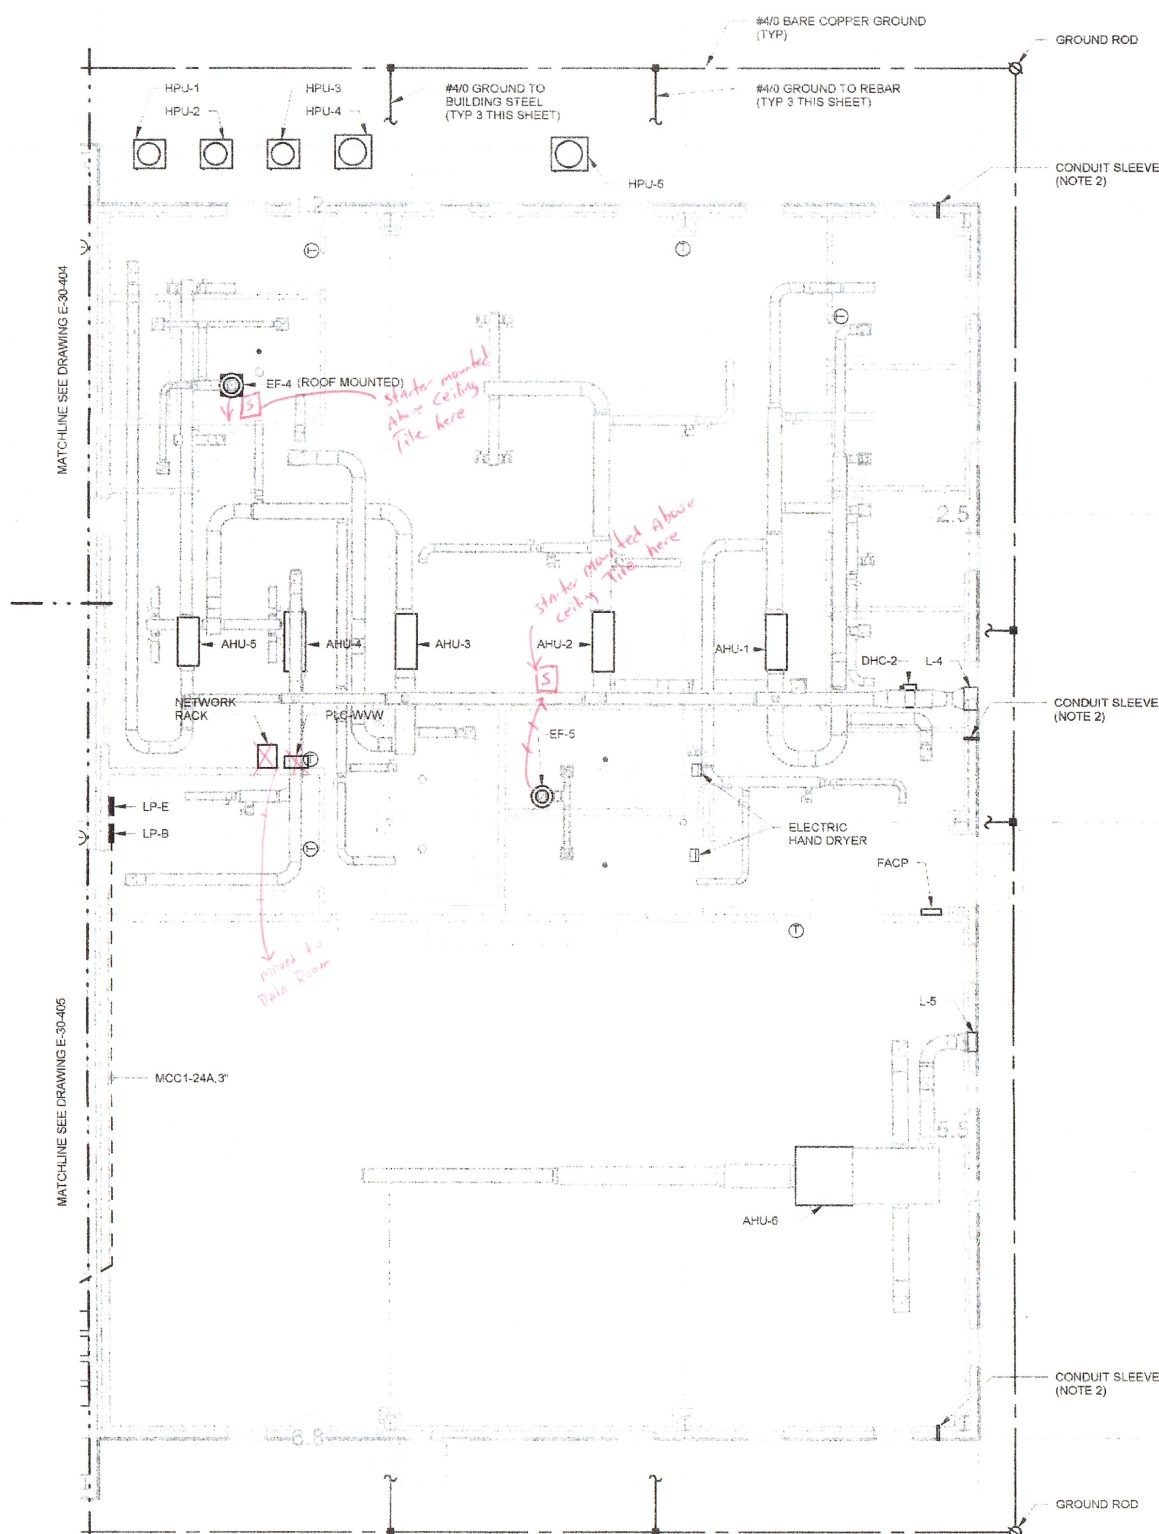

1 POWER PLAN - OPERATING FLOOR
1/8" = 1'-0"


NOTES:

1. SEE DRAWING E-00-001 FOR ELECTRICAL LEGEND & ABBREVIATIONS AND GENERAL REQUIREMENTS.
2. CONTRACTOR SHALL INSTALL A MINIMUM 3/4" PVC CONDUIT SLEEVE FROM BUILDING INTERIOR TO EXTERIOR OF BUILDING A MINIMUM ONE FOOT BELOW GRADE FOR LIGHTNING PROTECTION DOWNLEAD. REFER TO LIGHTNING PROTECTION SUBMITTAL FOR MORE DETAILS.

BEDFORD REGIONAL WATER AUTHORITY
SMITH MOUNTAIN LAKE WTP &
LAKES TO FOREST WATER LINE EXTENSION
ELECTRICAL
MEMBRANE/ADMIN BUILDING
PARTIAL POWER PLAN


DESIGNED: ZKO	PROJECT NO. 182262
DETAILED: PTD	E-30-406
CHECKED: SDS	SHEET OF
APPROVED:	
DATE: 01/11/16	
IF THIS BAR DOES NOT BLASE, 1" THEN DRAWING IS NOT TO FULL SCALE	

BLACK & VEATCH
Building a world of difference.
Black & Veatch Corporation
Virginia Beach, VA

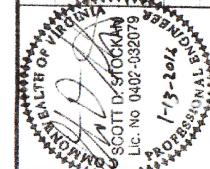

ISSUED FOR CONSTRUCTION	DATE: 01/11/16	USER:
REVISIONS AND RECORD OF ISSUE	DATE: 01/11/16	USER:
NO. BY CHK APP	DATE: 01/11/16	USER:
1. 2KO SDS	DATE: 01/11/16	USER:
2. C:\pw_working\bwv_america\lms21249_3D-E-30-MEMBRANE.BV.PLT	DATE: 01/11/16	USER:
3. 1/11/2016 5:48:48 PM	DATE: 01/11/16	USER:
4. 1/11/2016 5:48:48 PM	DATE: 01/11/16	USER:
5. 1/11/2016 5:48:48 PM	DATE: 01/11/16	USER:
6. 1/11/2016 5:48:48 PM	DATE: 01/11/16	USER:
7. 1/11/2016 5:48:48 PM	DATE: 01/11/16	USER:
8. 1/11/2016 5:48:48 PM	DATE: 01/11/16	USER:
9. 1/11/2016 5:48:48 PM	DATE: 01/11/16	USER:
10. 1/11/2016 5:48:48 PM	DATE: 01/11/16	USER:

ISSUED FOR CONSTRUCTION

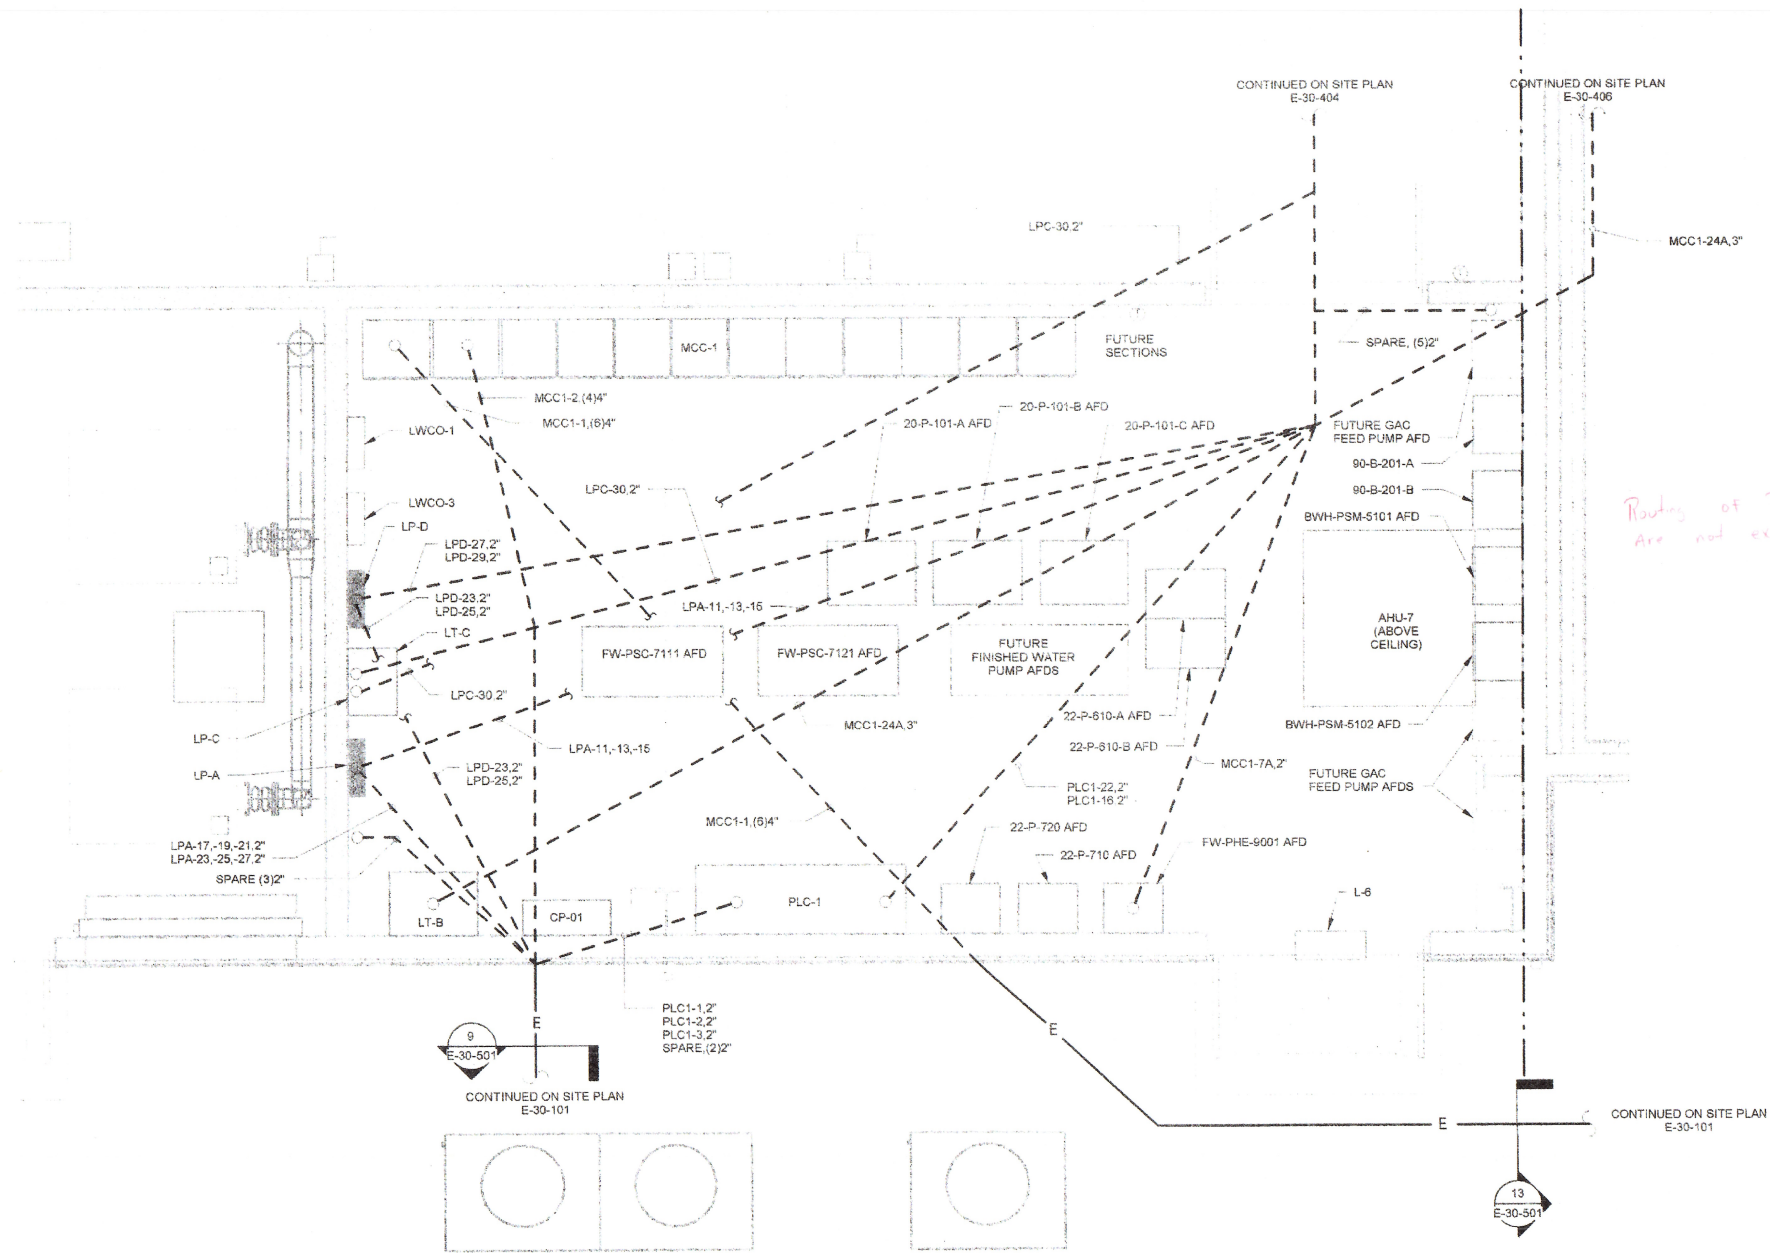

Routing of These Conduits Shown
Are not exactly as shown.

1 ENLARGED UNDER SLAB POWER PLAN - OPERATING FLOOR
3/8" = 1'-0"

NOTES:
1. SEE DRAWING E-30-001 FOR ELECTRICAL LEGEND & ABBREVIATIONS AND GENERAL REQUIREMENTS

ISSUED FOR CONSTRUCTION

BEDFORD REGIONAL WATER AUTHORITY SMITH MOUNTAIN LAKE WTP & LAKES TO FOREST WATER LINE EXTENSION ELECTRICAL MEMBRANE/ADMIN BUILDING UNDER SLAB CONDUIT ROUTING POWER PLAN		DESIGNED: ZKO DETAILER: RTD CHECKED: SDS APPROVED: DATE: 01/11/16	PROJECT NO. 182262 E-30-407 SHEET OF
BLACK & VEATCH Building a world of difference. Black & Veatch Corporation Virginia Beach, VA		ISSUED FOR CONSTRUCTION REVISIONS AND RECORD OF ISSUE NO. BY CHK APP 0 ZKO SDS DATE 11/11/16 DWG: C:\DW\Working\Unw\americas\182262\182262-E-30-MEMBRANE.BV.rvt XREF1: XREF2: XREF3: XREF4: PLOTTED: 1/12/2016 10:49:29 AM USER:	SCOTT D. STOKKAN Lic. No. 0402-032019 1/1/2016 PROFESSIONAL














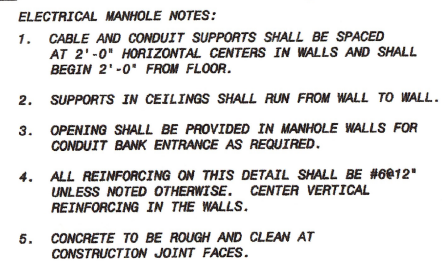


Diagram illustrating the rack layout for a PLC system, showing 24 slots and various components:

- Slot 1: PLC1-22, -23, -25
- Slot 2: GACVBF3-1
- Slot 3: LPD-29
- Slot 4: LCP-30
- Slot 5: MCC1-7A
- Slot 6: LPC-30
- Slot 7: SPARE
- Slot 8: SPARE
- Slot 9: MCC1-55A, PLC1-44, -46
- Slot 10: MCC1-55
- Slot 11: SPARE
- Slot 12: SPARE
- Slot 13: SPARE
- Slot 14: SPARE
- Slot 15: SPARE
- Slot 16: SPARE
- Slot 17: SPARE
- Slot 18: SPARE
- Slot 19: SPARE
- Slot 20: SPARE
- Slot 21: SPARE
- Slot 22: SPARE
- Slot 23: SPARE
- Slot 24: SPARE

Additional labels and connections include:

- MCC1-7B, -7C
- MCC1-55B
- PLC1-17
- PLC1-18
- SECTION 4
- NO SCALE
- E-30-101

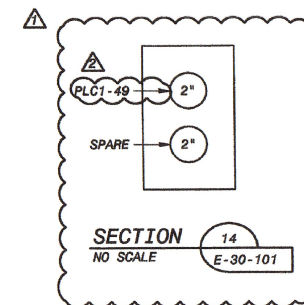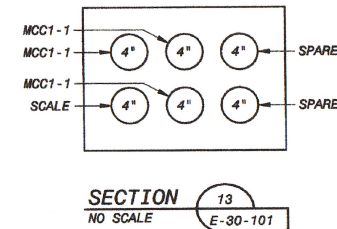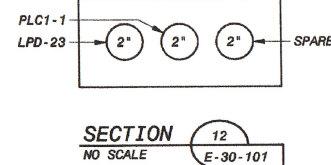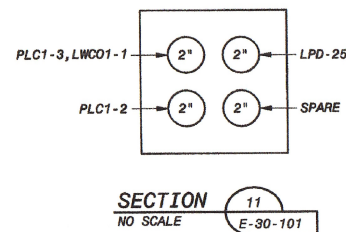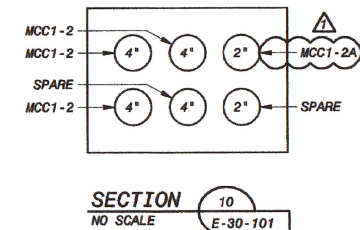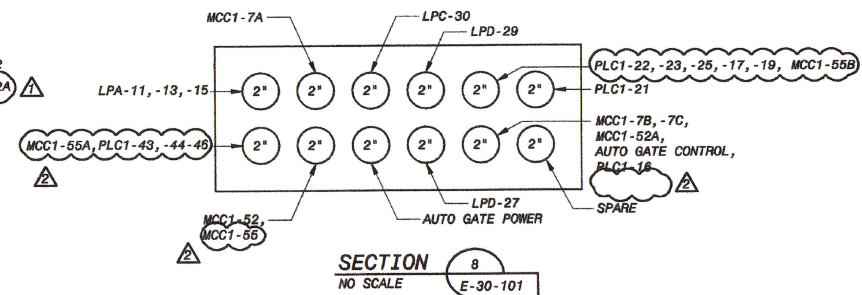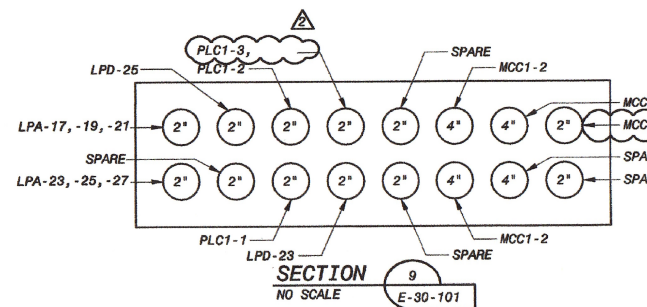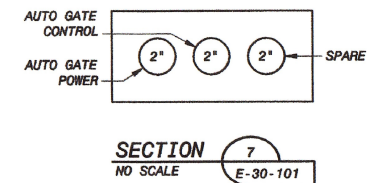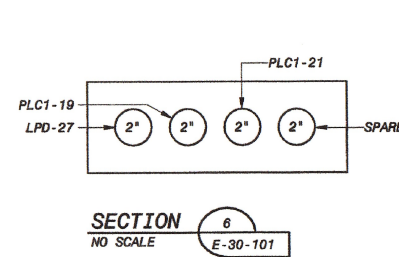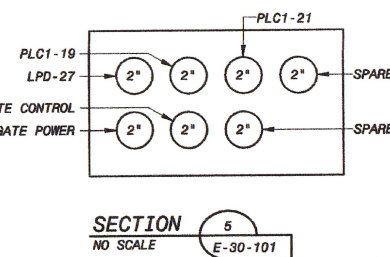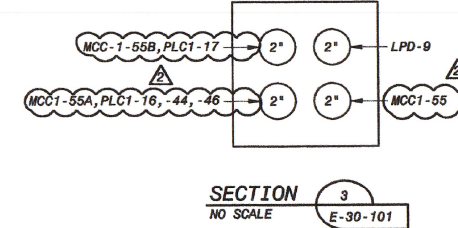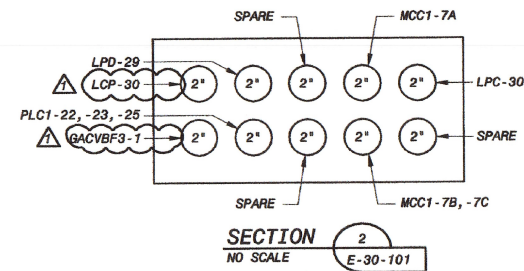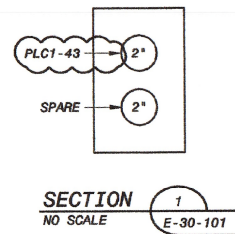

DESIGNED:	ZKO
DETAILED:	DAH
CHECKED:	SDS
APPROVED:	
DATE:	07/18/16

E-30-501
SHEET
OF

ISSUED FOR CONSTRUCTION

E-30-501
SHEET
OF


FD7000_PW
D7000

PHASE			PANELBOARD: LP-A			BUS: COPPER			MAINS: 3P-100A MAIN BREAKER			PHASE		
			SERVICE: 277/480V, 3PH, 4W, S/N			RATING: 100A			LOCATION: ELECTRICAL ROOM					
"A"	"B"	"C"	MOUNTING: SURFACE			P	BKR	CKT #	BKR	P	LOAD	"A"	"B"	"C"
V.A.	V.A.	V.A.	LOAD									V.A.	V.A.	V.A.
1120			LTG. - OPEN OFFICE 18			1	20	1	2	20	1	768		
480			LTG. - OPEN OFFICE 13			1	20	3	4	20	1	352		
	270		LTG. - ROOM 4, 5, 6, 7			1	20	5	6	20	1		504	
720			LTG. - EXTERIOR SOUTH			1	20	7	8	20	1	2254		
	648		LTG. - ROOM 16, 17			1	20	9	10	20	1		2	
			SITE LIGHTING - EAST SIDE			3	20	11	12	20	1			
			---					13	14	20	1			
			SITE LIGHTING - WEST SIDE			3	20	17	18	20	3			
			---					19	20					
			---					21	22					
			PARKING LOT LIGHTING			3	20	23	24	20	3			
			---					25	26					
			---					27	28					
			SPARE			3	20	29	30		1			
			---					31	32		1			
			---					33	34		1			
			SPARE			1	20	35	36		1			
			SPARE			1	20	37	38		1			
			SPARE			1	20	39	40		1			
			SPARE			1	20	41	42		1			
1840			TOTAL "A"					4862				3022		
1120			TOTAL "B"					1482				354		
	270		TOTAL "C"					774					504	
			TOTAL =					7118						

PHASE			PANELBOARD: LP-D			BUS: COPPER			MAINS: 3P-150A MAIN BREAKER			PHASE		
			SERVICE: 120/208V, 3PH, 4W, S/N			RATING: 225A			LOCATION: ELECTRICAL ROOM					
"A"	"B"	"C"	MOUNTING: SURFACE			P	BKR	CKT #	BKR	P	LOAD	"A"	"B"	"C"
V.A.	V.A.	V.A.	LOAD									V.A.	V.A.	V.A.
500			PLC-1			1	20	1	2	20	1			
	500		NOCL-PPS-8201			1	20	3	4	20	1			
		500	NOCL-PPS-8601			1	20	5	6	20	1			
500			CP-02			1	20	7	8	20	1			
	50		LIT-7002			1	20	9	10	20	1		100	
	250		23-P-801-A			1	20	11	12	20	1		250	
250			23-P-601-A			1	20	13	14	20	1		250	
	250		23-P-701-A			1	20	15	16	20	1		250	
		1700	90-DR-001-A			1	20	17	18	20	1		1700	
500			DCP-1			1	20	19	20	20	1		500	
	500		OUTDOOR EYEWASH/SHOWER			1	20	21	22	20	1		500	
		100	FIT-3001			1	20	23	24	20	1		500	
100			LIT-3001			1	20	25	26	20	1		500	
	100		FIT-7131			1	20	27	28	20	1		500	
		100	FIT-9005			1	20	29	30	20	1		250	
100			FIT-5201			1	20	31	32	20	1		250	
		100	22-FIT-601			1	20	33	34	20	1			
			SPARE			1	20	35	36	20	1			
			SPARE			1	20	37	38	20	1			
			SPARE			1	20	39	40	20	1			
			SPARE			1	20	41	42	20	1			
1950			TOTAL "A"					3950				2000		
1500			TOTAL "B"					3600				2100		
	2650		TOTAL "C"					5350					2700	
			TOTAL =					12900						

PHASE			PANELBOARD: LP-B			BUS: COPPER			MAINS: 3P-100A MAIN BREAKER			PHASE		
			SERVICE: 120/208V, 3PH, 4W, S/N			RATING: 100A			LOCATION: CONTROL ROOM					
"A"	"B"	"C"	MOUNTING: SURFACE			P	BKR	CKT #	BKR	P	LOAD	"A"	"B"	"C"
V.A.	V.A.	V.A.	LOAD									V.A.	V.A.	V.A.
540			RECPT - OPEN OFFICE 18			1	20	1	2	20	1	360		
	540		RECPT - LAB 12			1	20	3	4	20	1		540	
		180	RECPT - ELECTRIC WATER COOLER			1	20	5	6	20	1			720
360			RECPT - MENS 3 & WOMENS 2			1	20	7	8	20	1	360		
	180		RECPT - BREAK AREA 14			1	20	9	10	20	1		360	
		180	RECPT - BREAK ARE FRIDGE			1	20	11	12	20	1		360	
360			RECPT - LAB 12			1	20	13	14	20	1	720		
	540		RECPT - CONTROL ROOM 15			1	20	15	16	20	1		540	
		360	RECPT - CONTROL ROOM 15			1	20	17	18	20	1		540	
800			RECPT - OPEN OFFICE 13 FLOOR			1	20	19	20	20	1	800		
	800		RECPT - OPEN OFFICE 13 FLOOR			1	20	21	22	20	1		580	
		720	RECPT - OFFICE 3 (ROOM 11)			1	20	23	24	20	1		720	
540			RECPT - OPEN OFFICE 13			1	20	25	26	20	1	720		
	720		RECPT - OPEN OFFICE 13			1	20	27	28	20	1		540	
		360	RECPT - NETWORK ROOM 4			1	20	29	30	20	1		360	
360			RECPT - NETWORK ROOM 4			1	20	31	32	20	1	540		
	1200		FACP PANEL			1	20	33	34	20	1	360		
			SPARE			1	20	35	36	20	1			
			SPARE			1	20	37	38	20	1			
			SPARE			1	20	39	40	20	1			
			SPARE			1	20	41	42	20	1			
2960			TOTAL "A"					6460				3500		
3980			TOTAL "B"					6900				2920		
	1800		TOTAL "C"					4500					2700	
			TOTAL =					17860						


PANELBOARD: LP-E						BUS: COPPER						MAINS: 3P-350A MAIN BREAKER								
SERVICE: 120/208V, 3PH, 4W, S/N						RATING: 400A						LOCATION: CONTROL ROOM						PHASE		
PHASE			LOAD																	
"A"	"B"	"C"	V.A.	V.A.	V.A.	P	BKR	CKT #	BKR	P	LOAD	V.A.	"B"	"C"	V.A.	V.A.	V.A.			
1000			500			1	20	1	2	20	1	ELECTRIC HAND DRYER	1000							
						1	20	3	4	20	1	EF-5		500						
		7280				2	70	5	6	80	2	AHU-2			7800					
7280						--	--	7	8	--	--		7800							
						2	80	9	10	40	2	AHU-4			4000					
	7600					--	--	11	12	--	--					4000				
4000						2	40	13	14	20	1	NETWORK RACK	500							
						--	--	15	16	20	1	PLC-WWW		500						
		2800				2	40	17	18	60	2	HPU-2			3750					
2800						--	--	19	20	--	--		3750							
	3120					2	50	21	22	20	2	HPU-4		1040						
		9120				--	--	23	24	20	--				1040					
1250						2	20	25	26	100	3	LIGHTING PANEL LP-B	6460							
	1250					--	--	27	28	--	--			6900						
						1	20	29	30	--	--				4500					
						1	20	31	32	20	1	SPARE								
						1	20	33	34	20	1	SPARE								
						1	20	35	36	20	1	SPARE								
						1	20	37	38	20	1	SPARE								
						1	20	39	40	20	1	SPARE								
						1	20	41	42	20	1	SPARE								
16330																				
	16470																			
		20800																		

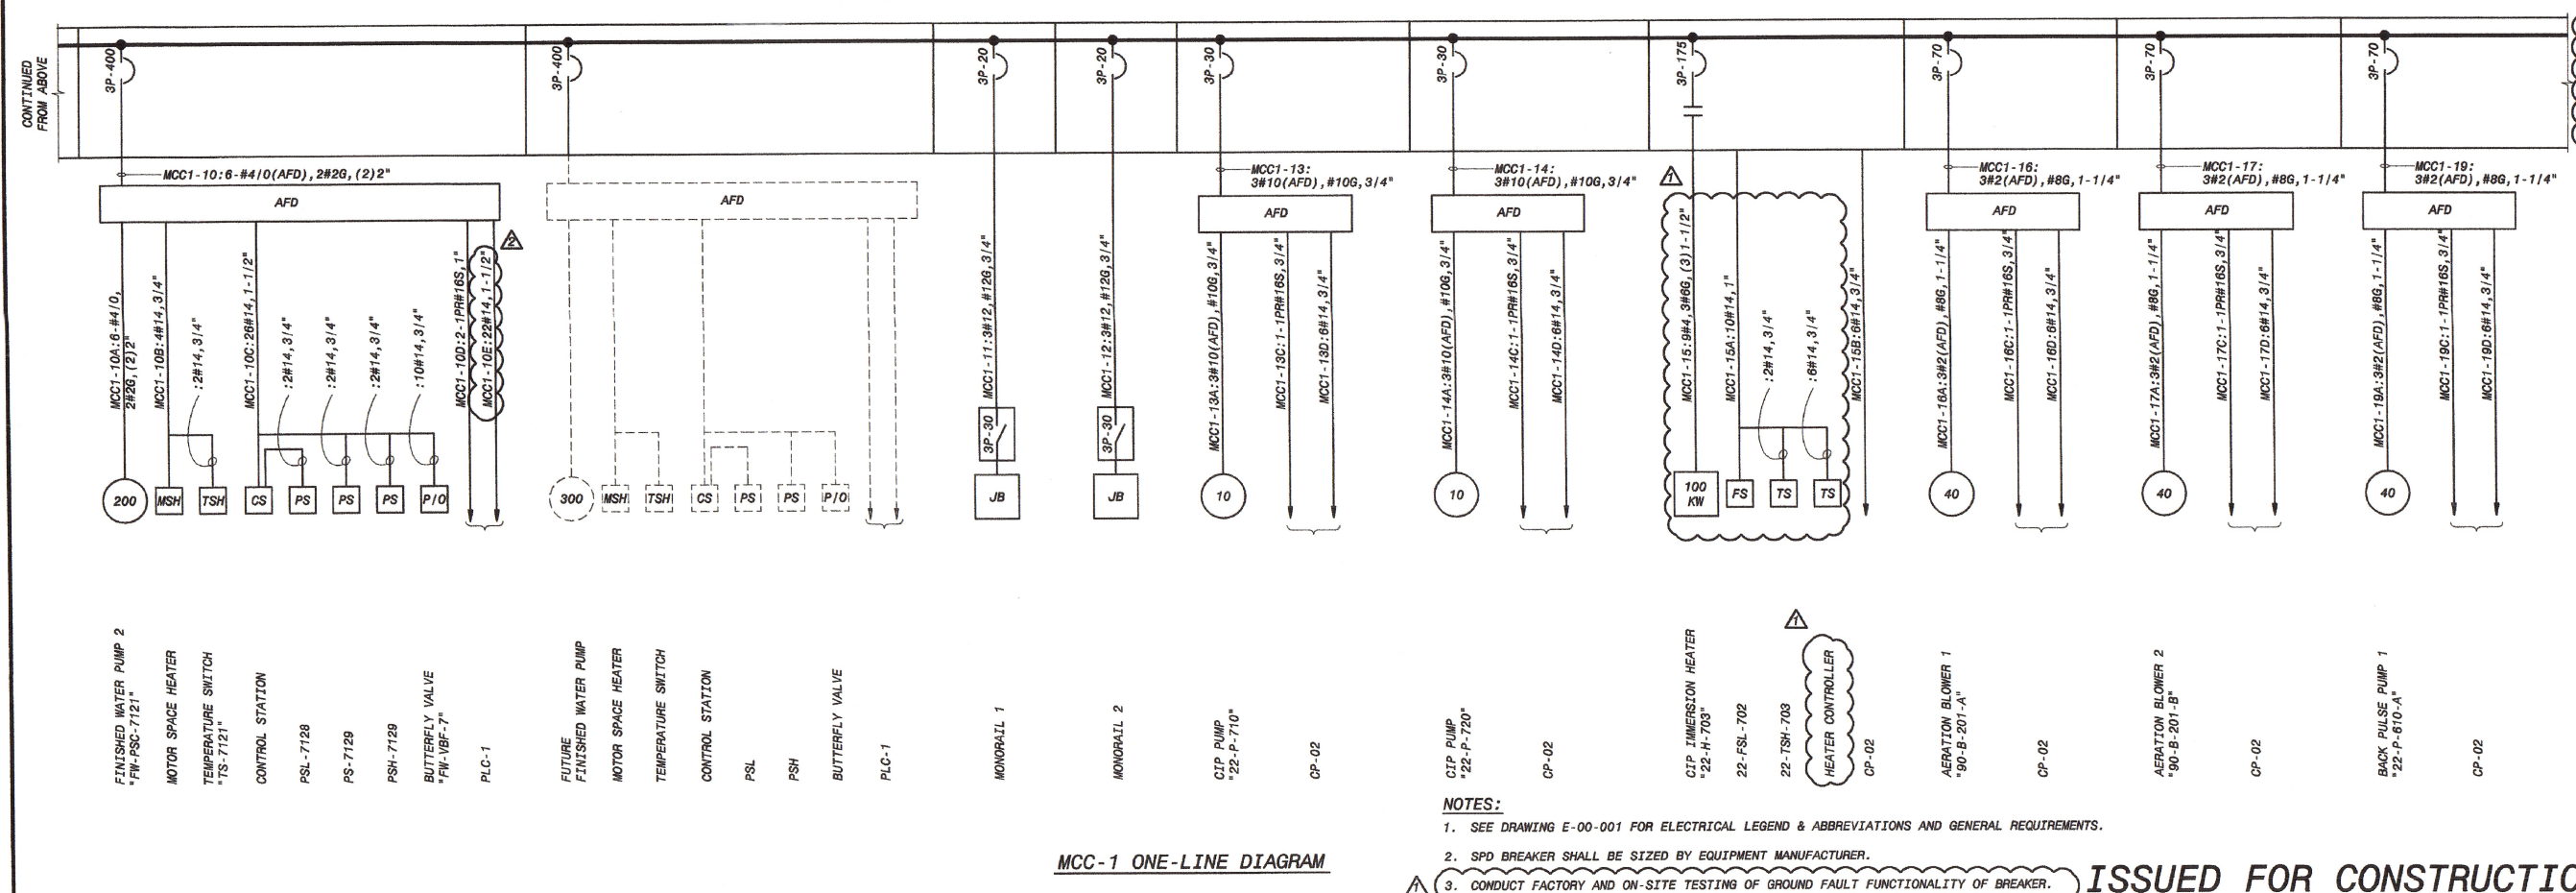

3. CONDUCT FACTORY AND ON-SITE TESTING OF GROUND FAULT FUNCTIONALITY OF BREAKER.

ISSUED FOR CONSTRUCTION

BEDFORD REGIONAL WATER AUTHORITY SMITH MOUNTAIN LAKE WTP & RAW WATER PUMPING STATION / INTAKE		ELECTRICAL MCC - 1 ONE-LINE DIAGRAM	
DESIGNED:	ZKO	DATE:	07/18/16
DETAILED:	DAH		
CHECKED:	SDS		
APPROVED:			
IF THIS BAR DOES NOT MEASURE 1" THEN DRAWING IS NOT TO FULL SCALE		PROJECT NO. 189317	
E-30-701 SHEET		BLACK & VEATCH Building a world of difference® Black & Veatch Corporation Virginia Beach, VA	

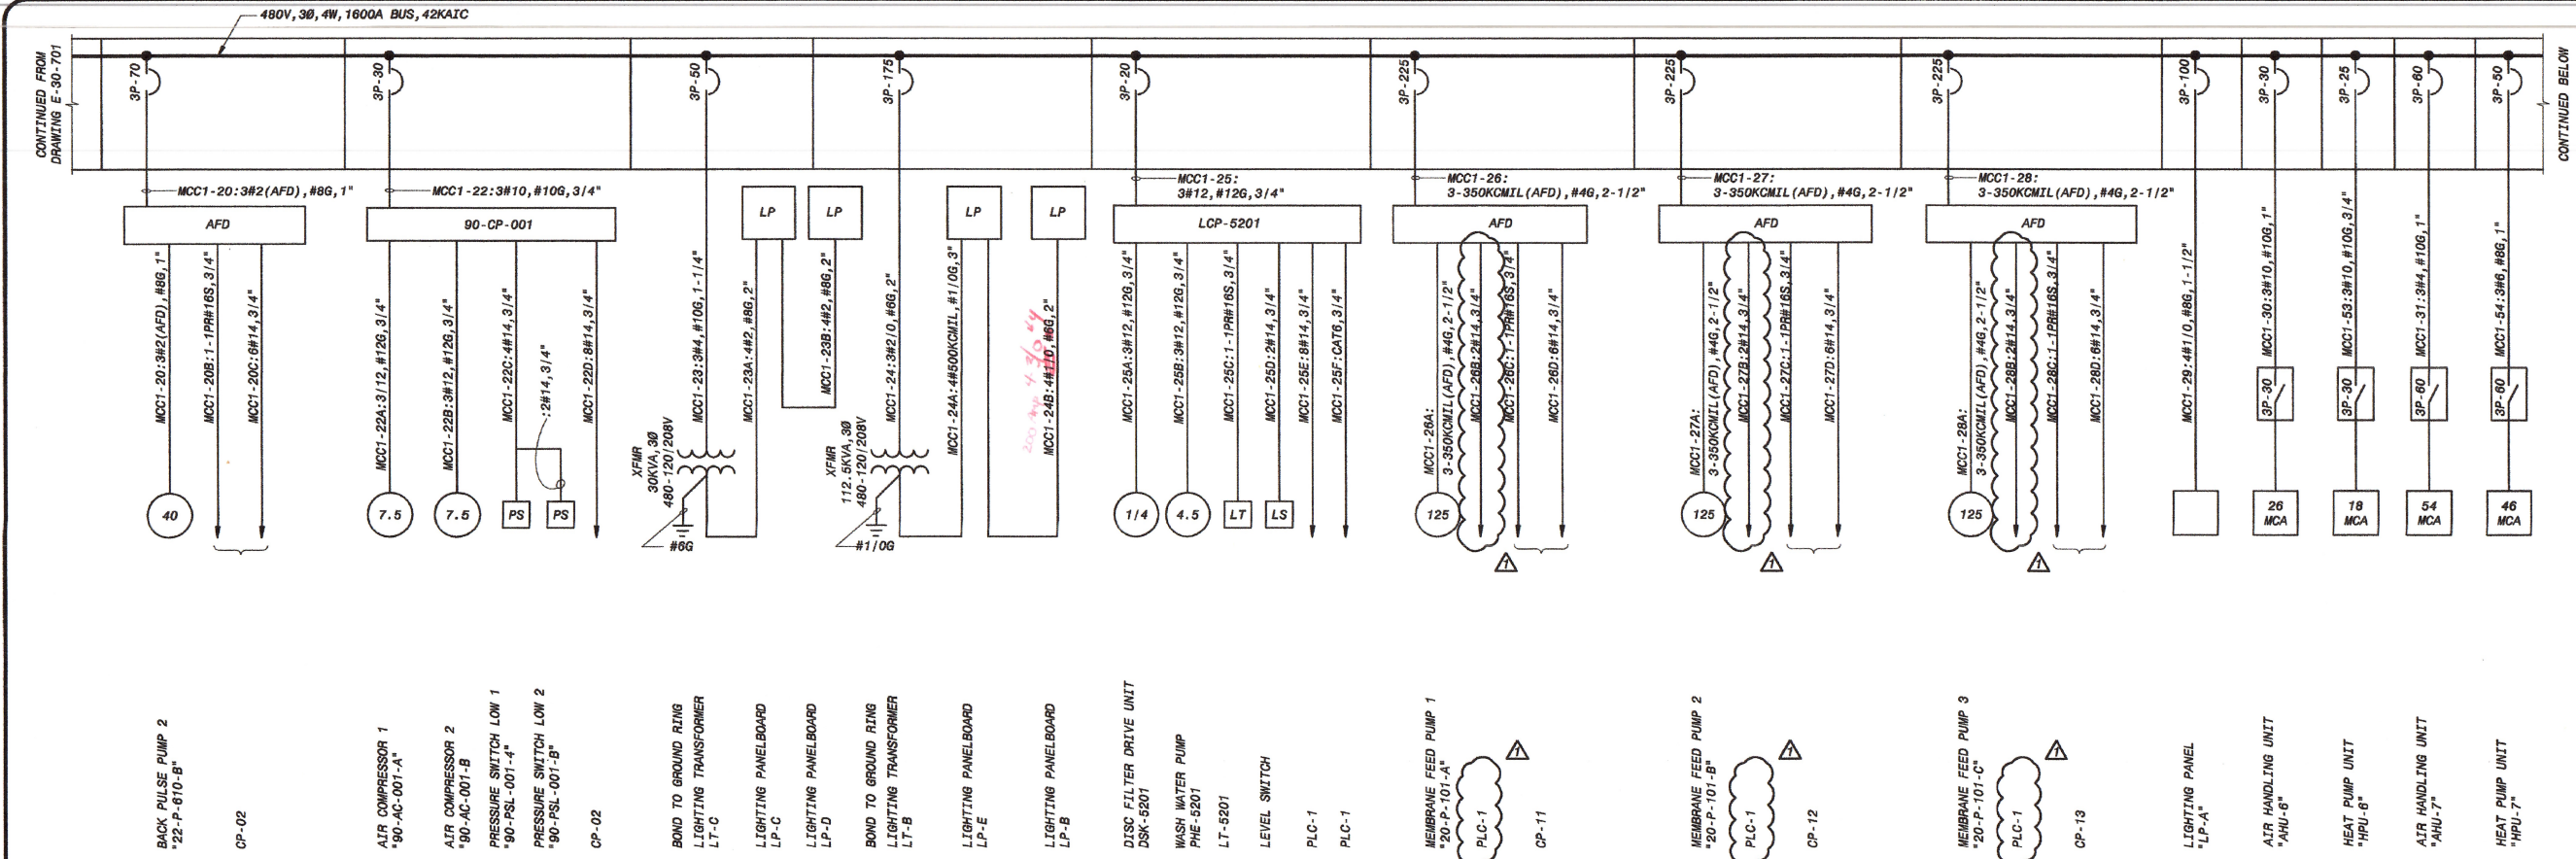

MCC-1 ONE-LINE DIAGRAM

MCC-1 ONE-LINE DIAGRAM

- ISSUED FOR CONSTRUCTION**


DESIGNED: ZKO DETAILED: JES CHECKED: SDS APPROVED: DATE: 07/18/16	0 1/2 1 IF THIS BAR DOES NOT MEASURE 1/2" NEW DRAWING IS NOT TO FULL SCALE
PROJECT NO. 189317	
E-30-702 SHEET OF	

BLACK & VEATCH
Building a world of difference.[®]

Black & Veatch Corporation
Virginia Beach, VA

ELECTRICAL
MCC-1 ONE-LINE DIAGRAM

[illegible]

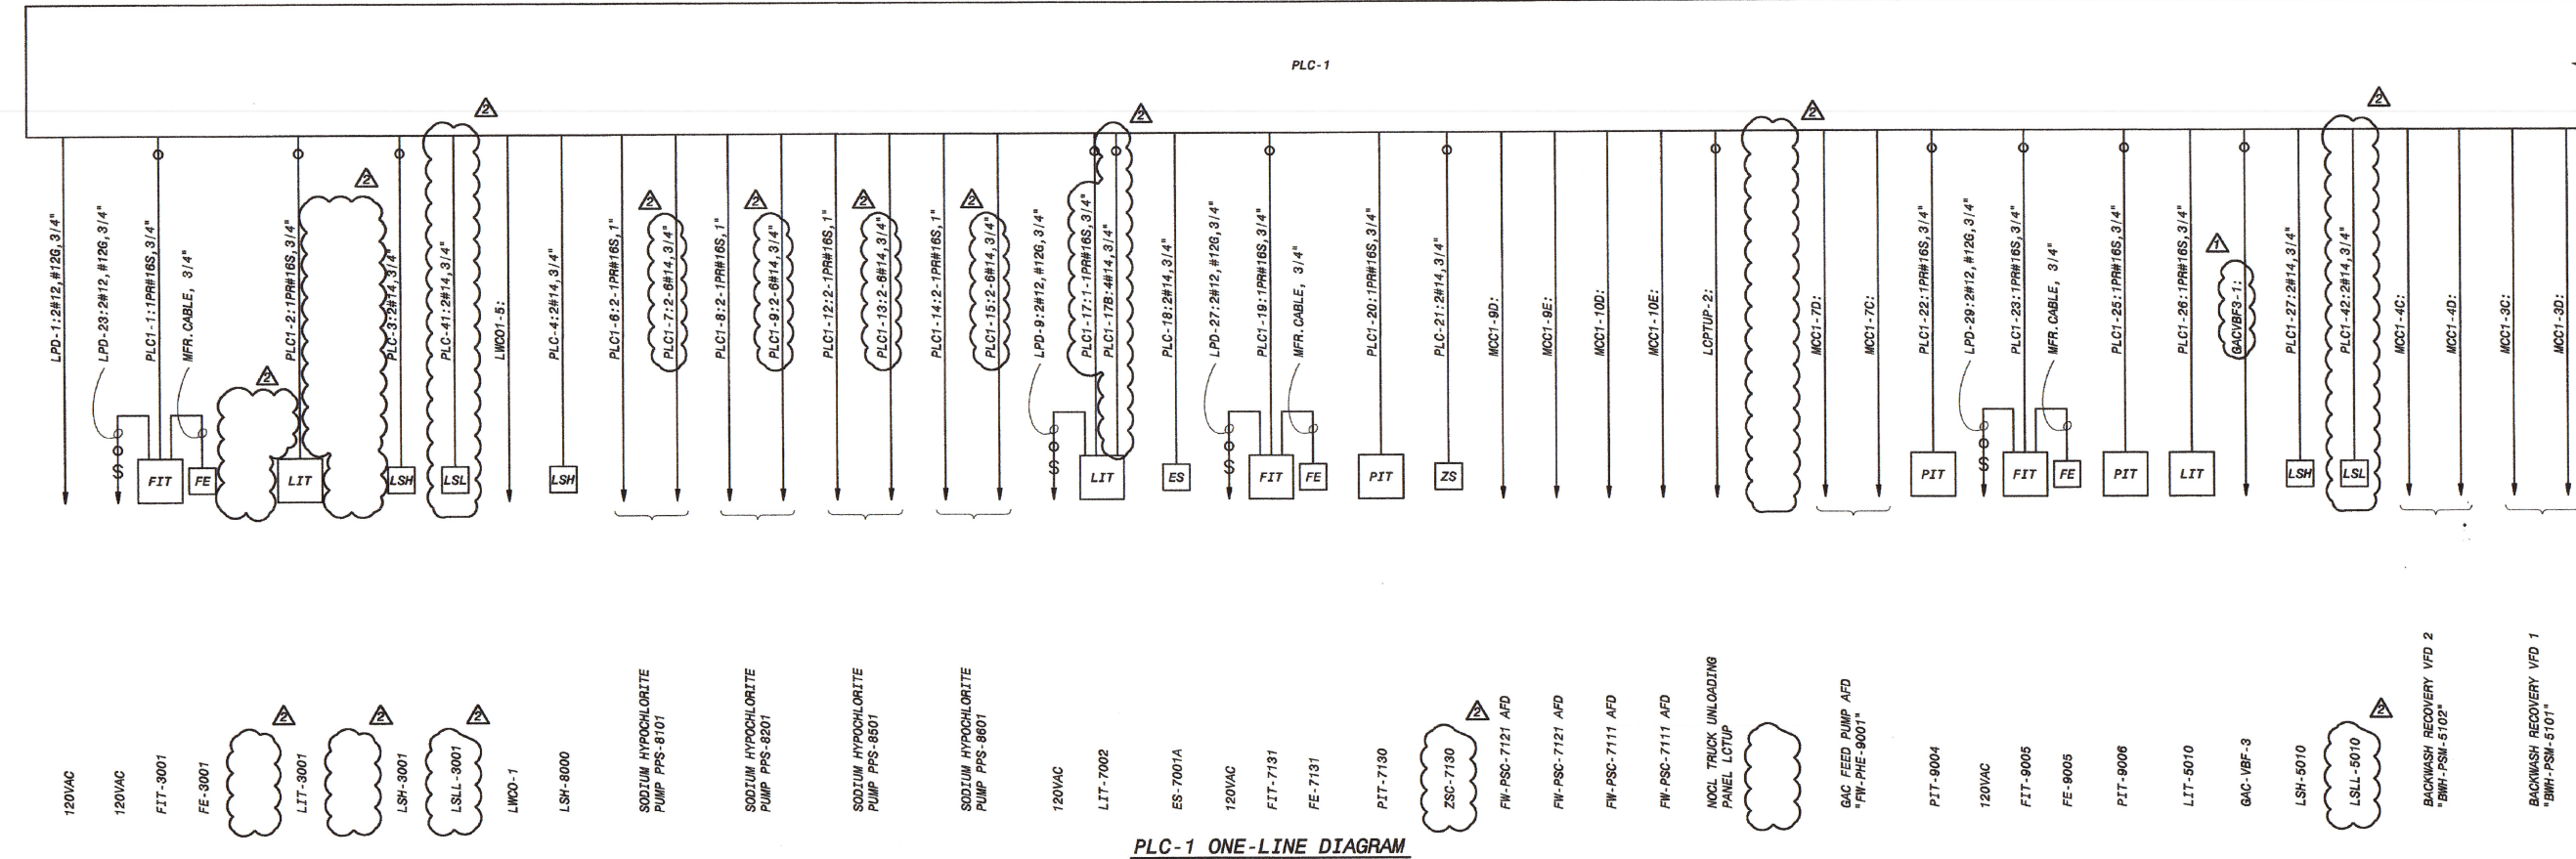

1. SEE DRAWING E-00-001 FOR ELECTRICAL LEGEND & ABBREVIATIONS AND GENERAL REQUIREMENTS.

CONTINUED BELOW				
1/18/16	ECH-013	2	ZWO	0
01/11/16	GENERAL REVISIONS	1	ZWO	0
12/04/15	ISSUED FOR CONSTRUCTION	0	ZWO	0
DATE	REVISIONS AND RECORD OF ISSUE	NO.	BY	
601.3040 - Electrical Drawings 601.3042 - chg SCOTT D. STOCKHAM Lic. No. 0402-032078				
XREF1: BINDER.dwg XREF2: XREF3: XREF4:		7-18-2016 PROFESSIONAL		
SAVED: 1/11/2016 2:04:48 PM PLOTTED: 1/11/2016 1:53:52 PLOTTED: 1/11/2016 1:53:52				

BLACK & VEATCH

Black & Veatch Corporation
Virginia Beach, VA

DATE: 07/18/16


0 1/2 1

IF THIS BAR DOES NOT
MEASURE 1" THEN DRAWING IS
NOT TO FULL SCALE


PROJECT NO.
189317

E-30-703


SHEET
OF

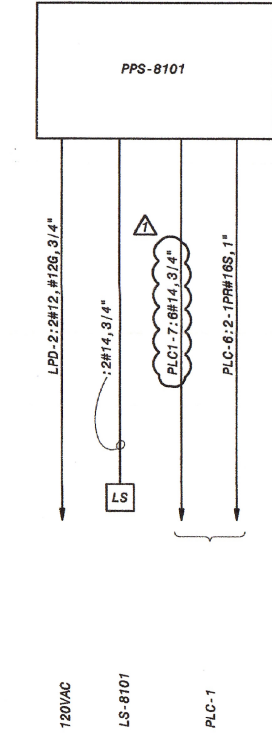


PPS-8101
ONE-LINE DIAGRAM
(TYP. FOR PPS-8201, -8501, -8801)

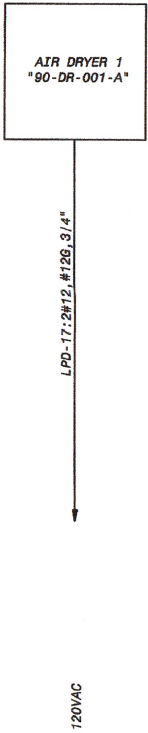


90-DR-001-A
ONE-LINE DIAGRAM
(TYP. FOR 90-DR-001-B)

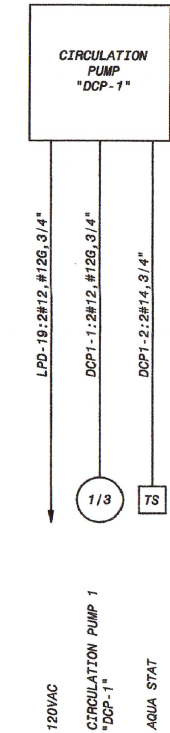


DCP-1
ONE-LINE DIAGRAM
(TYP. FOR DCP-2)

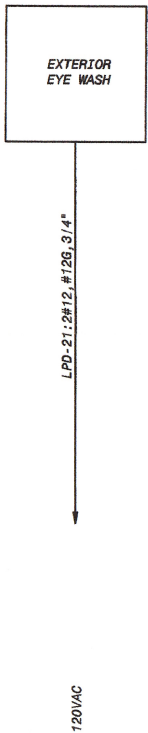


EXTERIOR EYEWASH STATION

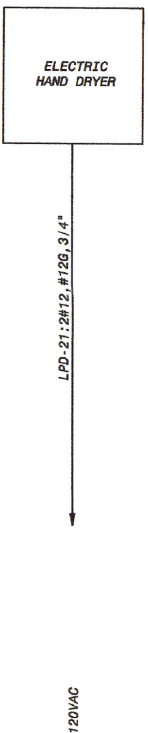


MEN'S BATHROOM ELECTRIC HAND DRYER
(TYP. FOR WOMEN'S BATHROOM)

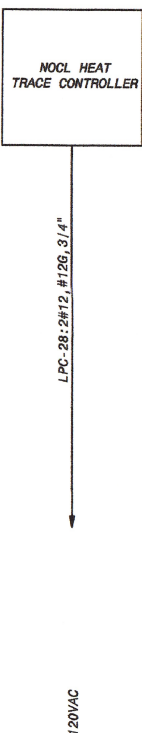

NOCL HEAT TRACE CONTROLLER

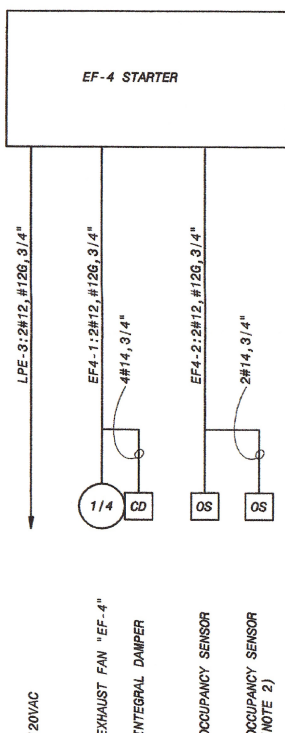

EF-4
ONE-LINE DIAGRAM
(TYP. FOR EF-5)

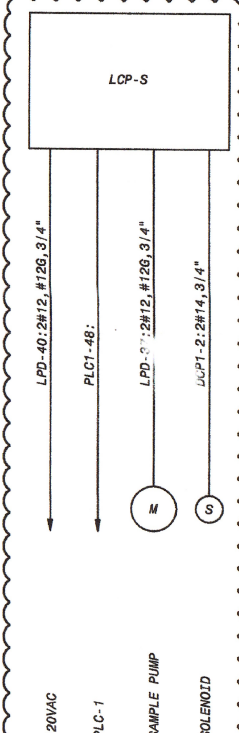


LCP-S
ONE-LINE DIAGRAM


NOTES:

- SEE DRAWING E-00-001 FOR ELECTRICAL LEGEND & ABBREVIATIONS AND GENERAL REQUIREMENTS.
- SECOND OCCUPANCY SENSOR PROVIDED FOR EF-5 ONLY.

ISSUED FOR CONSTRUCTION

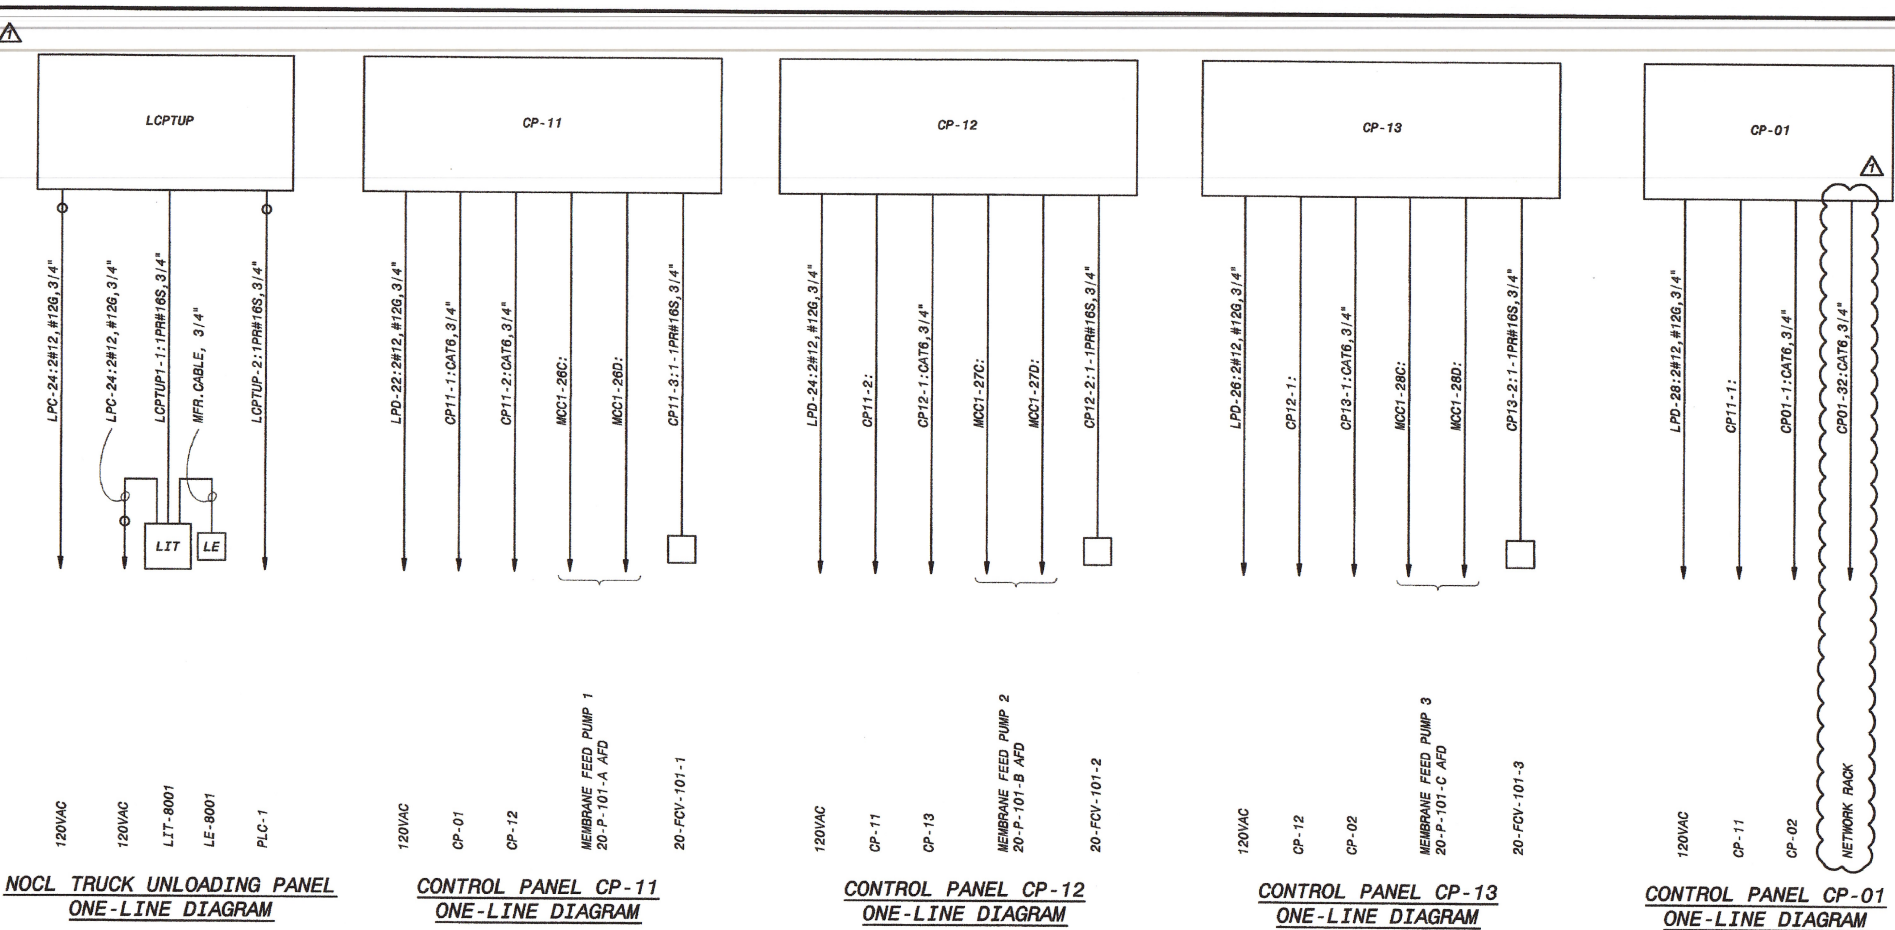

DESIGNED: ZKD	DATE: 07/18/16	ECN-013	ISSUED FOR CONSTRUCTION
DETAILLED: JES	DATE: 07/11/16	ISSUED FOR CONSTRUCTION	REVISIONS AND RECORD OF ISSUE
CHECKED: SDS	DATE: 07/11/16	ISSUED FOR CONSTRUCTION	REVISIONS AND RECORD OF ISSUE
APPROVED: SDS	DATE: 07/18/16	ISSUED FOR CONSTRUCTION	REVISIONS AND RECORD OF ISSUE
PROJECT NO. 189317			
E-30-704 SHEET OF			
BLACK & VEATCH Building a world of difference. Black & Veatch Corporation Virginia Beach, VA			
BEDFORD REGIONAL WATER AUTHORITY SMITH MOUNTAIN LAKE WTP & RAW WATER PUMPING STATION / INTAKE ELECTRICAL MISCELLANEOUS ONE-LINE DIAGRAM			
NO. 3000 - Electrical Drawings E-30-704.dwg SAVED: DRE6984, 7/17/2016 5:24:17 PM PLOTTER: HP18686, 8/12/2016 1:53: USER: DRE6984 DWG VER: 1000			

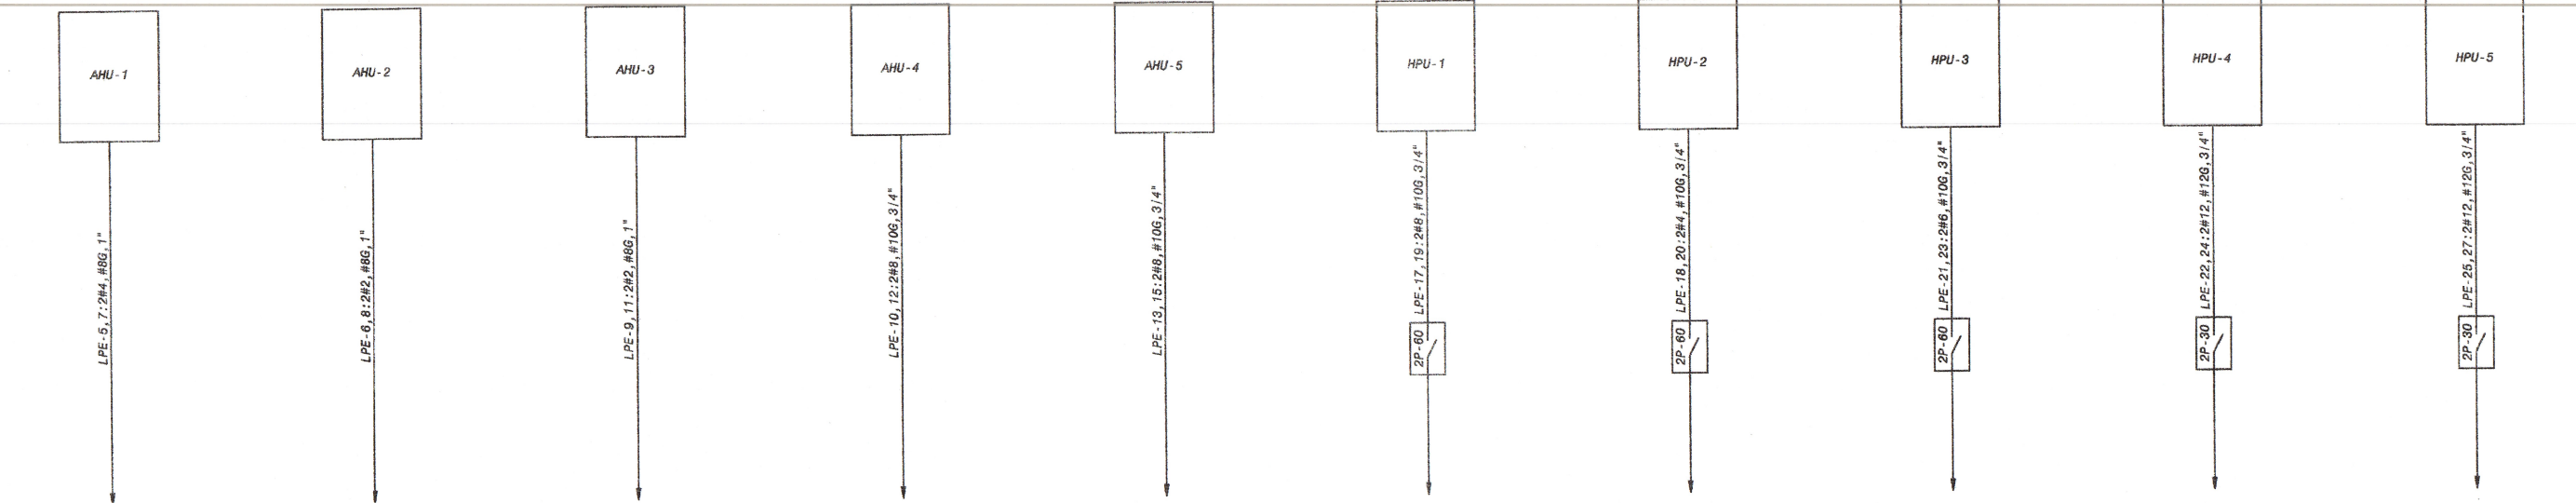

AHU-1
ONE-LINE DIAGRAM

AHU-2
ONE-LINE DIAGRAM

AHU-3
ONE-LINE DIAGRAM

AHU-4
ONE-LINE DIAGRAM

AHU-5
ONE-LINE DIAGRAM


HPU-1
ONE-LINE DIAGRAM

HPU-2
ONE-LINE DIAGRAM

HPU-3
ONE-LINE DIAGRAM

HPU-4
ONE-LINE DIAGRAM

HPU-5
ONE-LINE DIAGRAM

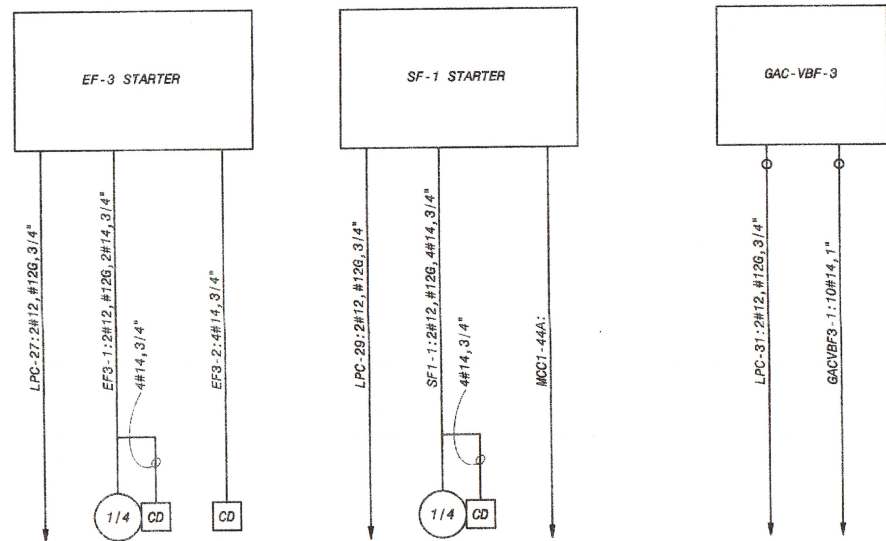

EF-3
ONE-LINE DIAGRAM

SF-1
ONE-LINE DIAGRAM


GAC-VBF-3
ONE-LINE DIAGRAM

NOTES:

1. SEE DRAWING E-00-001 FOR ELECTRICAL LEGEND & ABBREVIATIONS AND GENERAL REQUIREMENTS.


ISSUED FOR CONSTRUCTION

DESIGNED: ZKO		DATE: 01/11/16	
DETAILED: JES		1/2	
CHECKED: SOS		1	
APPROVED:		PROJECT NO. 189317	
IF THIS BAR DOES NOT MEASURE 1" THEN DRAWING IS NOT TO FULL SCALE		SHEET OF	
BEDFORD REGIONAL WATER AUTHORITY SMITH MOUNTAIN LAKE WTP & RAW WATER PUMPING STATION / INTAKE		E-30-705	
ELECTRICAL MISCELLANEOUS ONE-LINE DIAGRAM		SHEET OF	
BLACK & VEATCH Building a world of difference. Black & Veatch Corporation Virginia Beach, VA		E-30-705	
Professional Seal L.C. No. 0402-032079 1-13-2016		E-30-705	
ISSUED FOR CONSTRUCTION		E-30-705	
REVISIONS AND RECORD OF ISSUE		E-30-705	
NO. BY CH APP		E-30-705	
0 ZKO SOS		E-30-705	
XREF1: BINDER.dwg		E-30-705	
XREF2:		E-30-705	
XREF3:		E-30-705	
XREF4:		E-30-705	
USER: DRE68884		E-30-705	
DWG. VER: 1000		E-30-705	

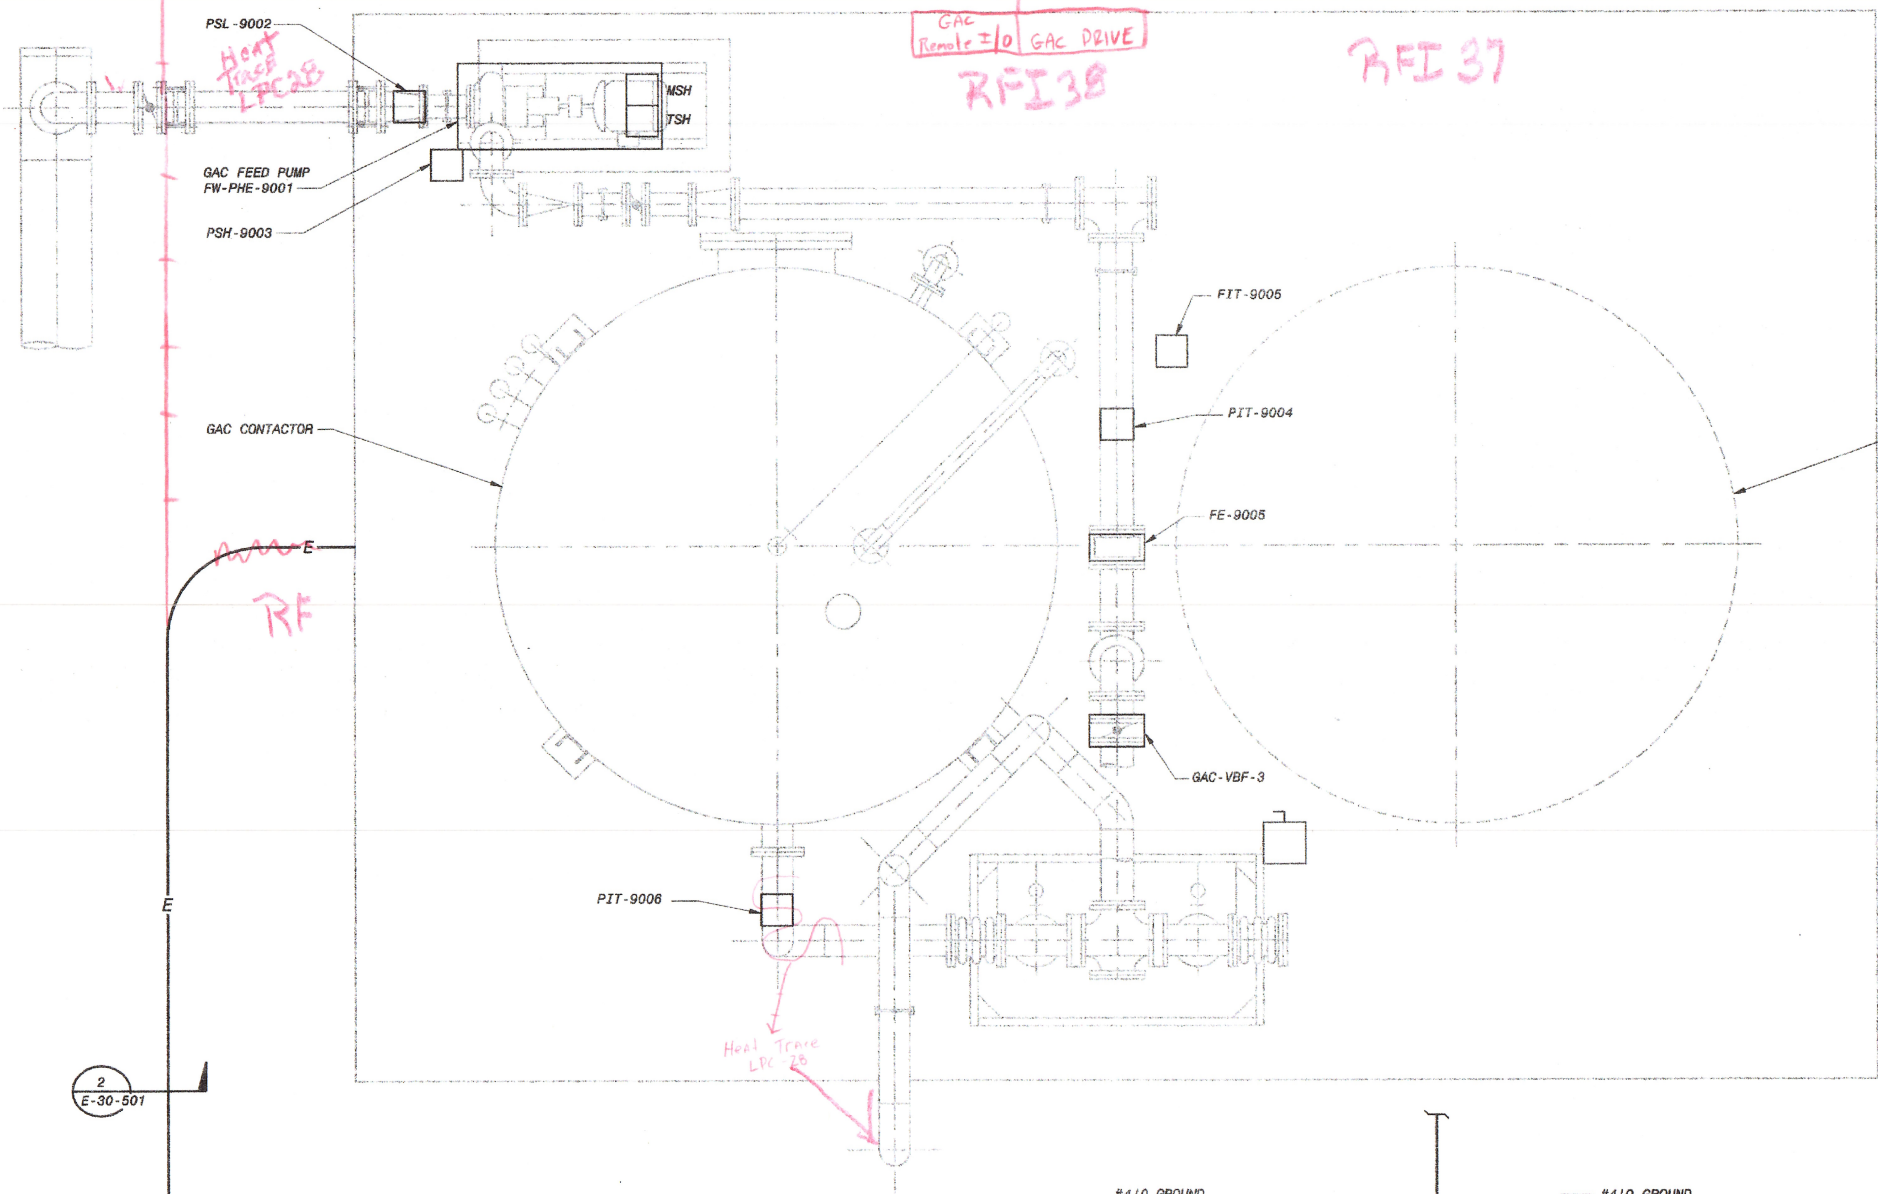

2
E-30-501

CONTINUED ON
SITE PLAN
E-30-101

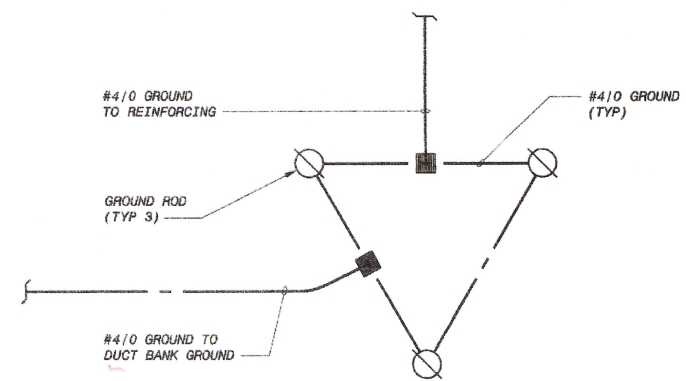

GAC
Remote I/O GAC DRIVE
RFI 38

RFI 37

FUTURE
GAC CONTACTOR

PIT-9006

FIT-9005

PIT-9004

FE-9005

GAC-VBF-3

#4/0 GROUND
TO REINFORCING

 
#4/0 GROUND
(TYP)

GROUND ROD
(TYP 3)

#4/0 GROUND TO
DUCT BANK GROUND

NOTES:

1. SEE DRAWING E-00-0001 FOR ELECTRICAL LEGEND & ABBREVIATIONS AND GENERAL REQUIREMENTS.



ISSUED FOR CONSTRUCTION

DESIGNED: ZKO	ISSUED FOR CONSTRUCTION	DATE: 01/11/16	PROJECT NO. 189317
DETAILED: DGP	REVISIONS AND RECORD OF ISSUE	DATE: 01/11/16	PROJECT NO. 189317
CHECKED: SDS	DATE: 01/11/16	DATE: 01/11/16	PROJECT NO. 189317
APPROVED:	DATE: 01/11/16	DATE: 01/11/16	PROJECT NO. 189317
DATE: 01/11/16	DATE: 01/11/16	DATE: 01/11/16	PROJECT NO. 189317

BLACK & VEATCH
Building a world of difference.
Black & Veatch Corporation
Virginia Beach, VA

BEDFORD REGIONAL WATER AUTHORITY
SMITH MOUNTAIN LAKE WTP &
RAW WATER PUMPING STATION / INTAKE
ELECTRICAL
GAC CONTACTOR AND PUMP AREA
POWER PLAN

DESIGNED: ZKO	ISSUED FOR CONSTRUCTION	DATE: 01/11/16	PROJECT NO. 189317
DETAILED: DGP	REVISIONS AND RECORD OF ISSUE	DATE: 01/11/16	PROJECT NO. 189317
CHECKED: SDS	DATE: 01/11/16	DATE: 01/11/16	PROJECT NO. 189317
APPROVED:	DATE: 01/11/16	DATE: 01/11/16	PROJECT NO. 189317
DATE: 01/11/16	DATE: 01/11/16	DATE: 01/11/16	PROJECT NO. 189317



4' 2' 0 4' 8'

$1/4'' = 1' - 0''$


DESIGNED: ZKO
 DETAILED: DGP
 CHECKED: SDS
 APPROVED:
 DATE: 07/18/16



IF THIS BAR DOES NOT
 MEASURE 1" THEN DRAWING IS
 NOT TO FULL SCALE


PROJECT NO.
 189317

E-85-101
 SHEET
 OF

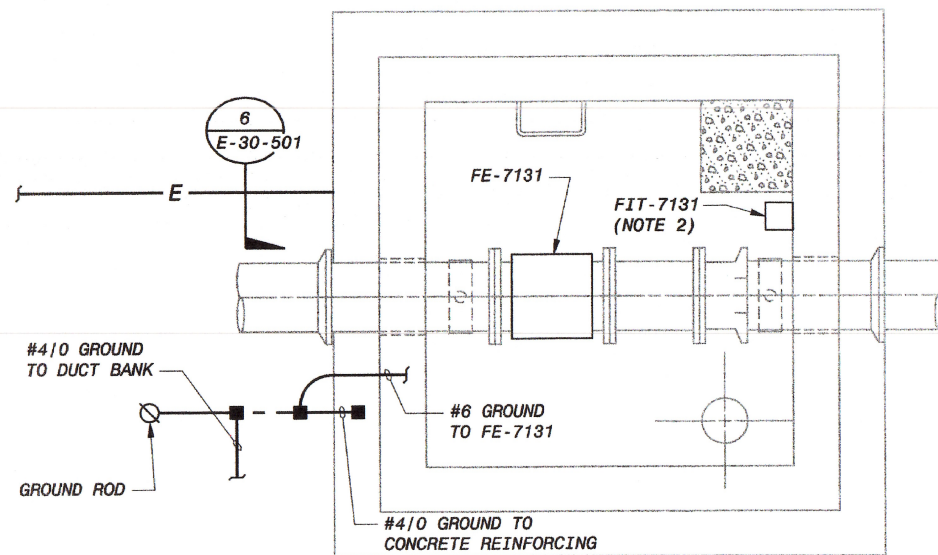

CONTINUED ON
E-30-101

FINISHED WATER FLOW METER VAULT
POWER PLAN
1/2" = 1'-0"

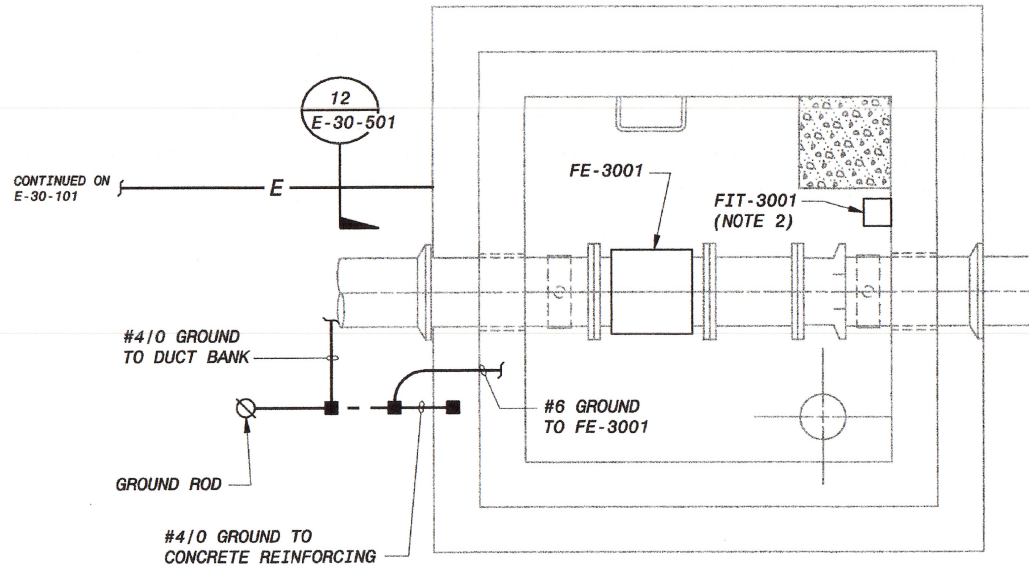


CONTINUED ON
E-30-101

RAW WATER FLOW METER VAULT
POWER PLAN
1/2" = 1'-0"

NOTES:

 1. SEE DRAWING E-00-001 FOR ELECTRICAL LEGEND & ABBREVIATIONS AND GENERAL REQUIREMENTS.
2. FLOW METER SHALL BE MOUNTED ON AN EQUIPMENT STAND ON TOP OF THE VAULT.



ISSUED FOR CONSTRUCTION

DESIGNED: ZKO		DATE: 01/11/16	
DETAILED: DGP		DATE: 01/11/16	
CHECKED: SDS		DATE: 01/11/16	
APPROVED:		DATE: 01/11/16	
PROJECT NO. 189317		PROJECT NO. 189317	
E-90-101		E-90-101	
SHEET		SHEET	
OF		OF	
BEDFORD REGIONAL WATER AUTHORITY SMITH MOUNTAIN LAKE WTP & RAW WATER PUMPING STATION / INTAKE		BEDFORD REGIONAL WATER AUTHORITY SMITH MOUNTAIN LAKE WTP & RAW WATER PUMPING STATION / INTAKE	
ELECTRICAL FLOW METER VAULTS POWER PLANS		ELECTRICAL FLOW METER VAULTS POWER PLANS	
BLACK & VEATCH Building a world of difference. Black & Veatch Corporation Virginia Beach, VA		BLACK & VEATCH Building a world of difference. Black & Veatch Corporation Virginia Beach, VA	
SCOTT D. STECKMAN Lic. No. 0402-032079 1-13-2016 PROFESSIONAL SEAL		SCOTT D. STECKMAN Lic. No. 0402-032079 1-13-2016 PROFESSIONAL SEAL	
ISSUED FOR CONSTRUCTION		ISSUED FOR CONSTRUCTION	
REVISED: 02/08/16		REVISED: 02/08/16	
DATE: 02/08/16		DATE: 02/08/16	
USER: DREG0094		USER: DREG0094	
DWG VER: 1000		DWG VER: 1000	
XREF1:		XREF1:	
XREF2:		XREF2:	
XREF3:		XREF3:	
XREF4:		XREF4:	