


REVISIONS	BY

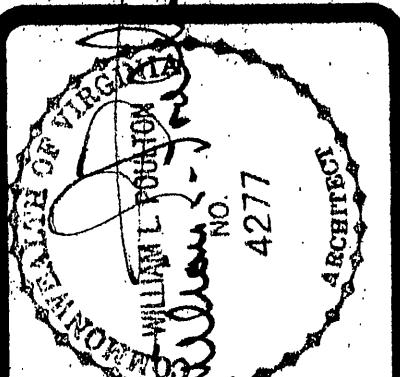

APPROVAL FOR PLATE 2

SCOTT STRICKLAND

HFC 400

DRAWN BY: SCOTT STRICKLAND


CHECKED BY: SCOTT STRICKLAND

DATE: 3/10/03

SCALE: 1/2 INCH = 1'-0"


JOB NO.: 20110

SHEET: 2

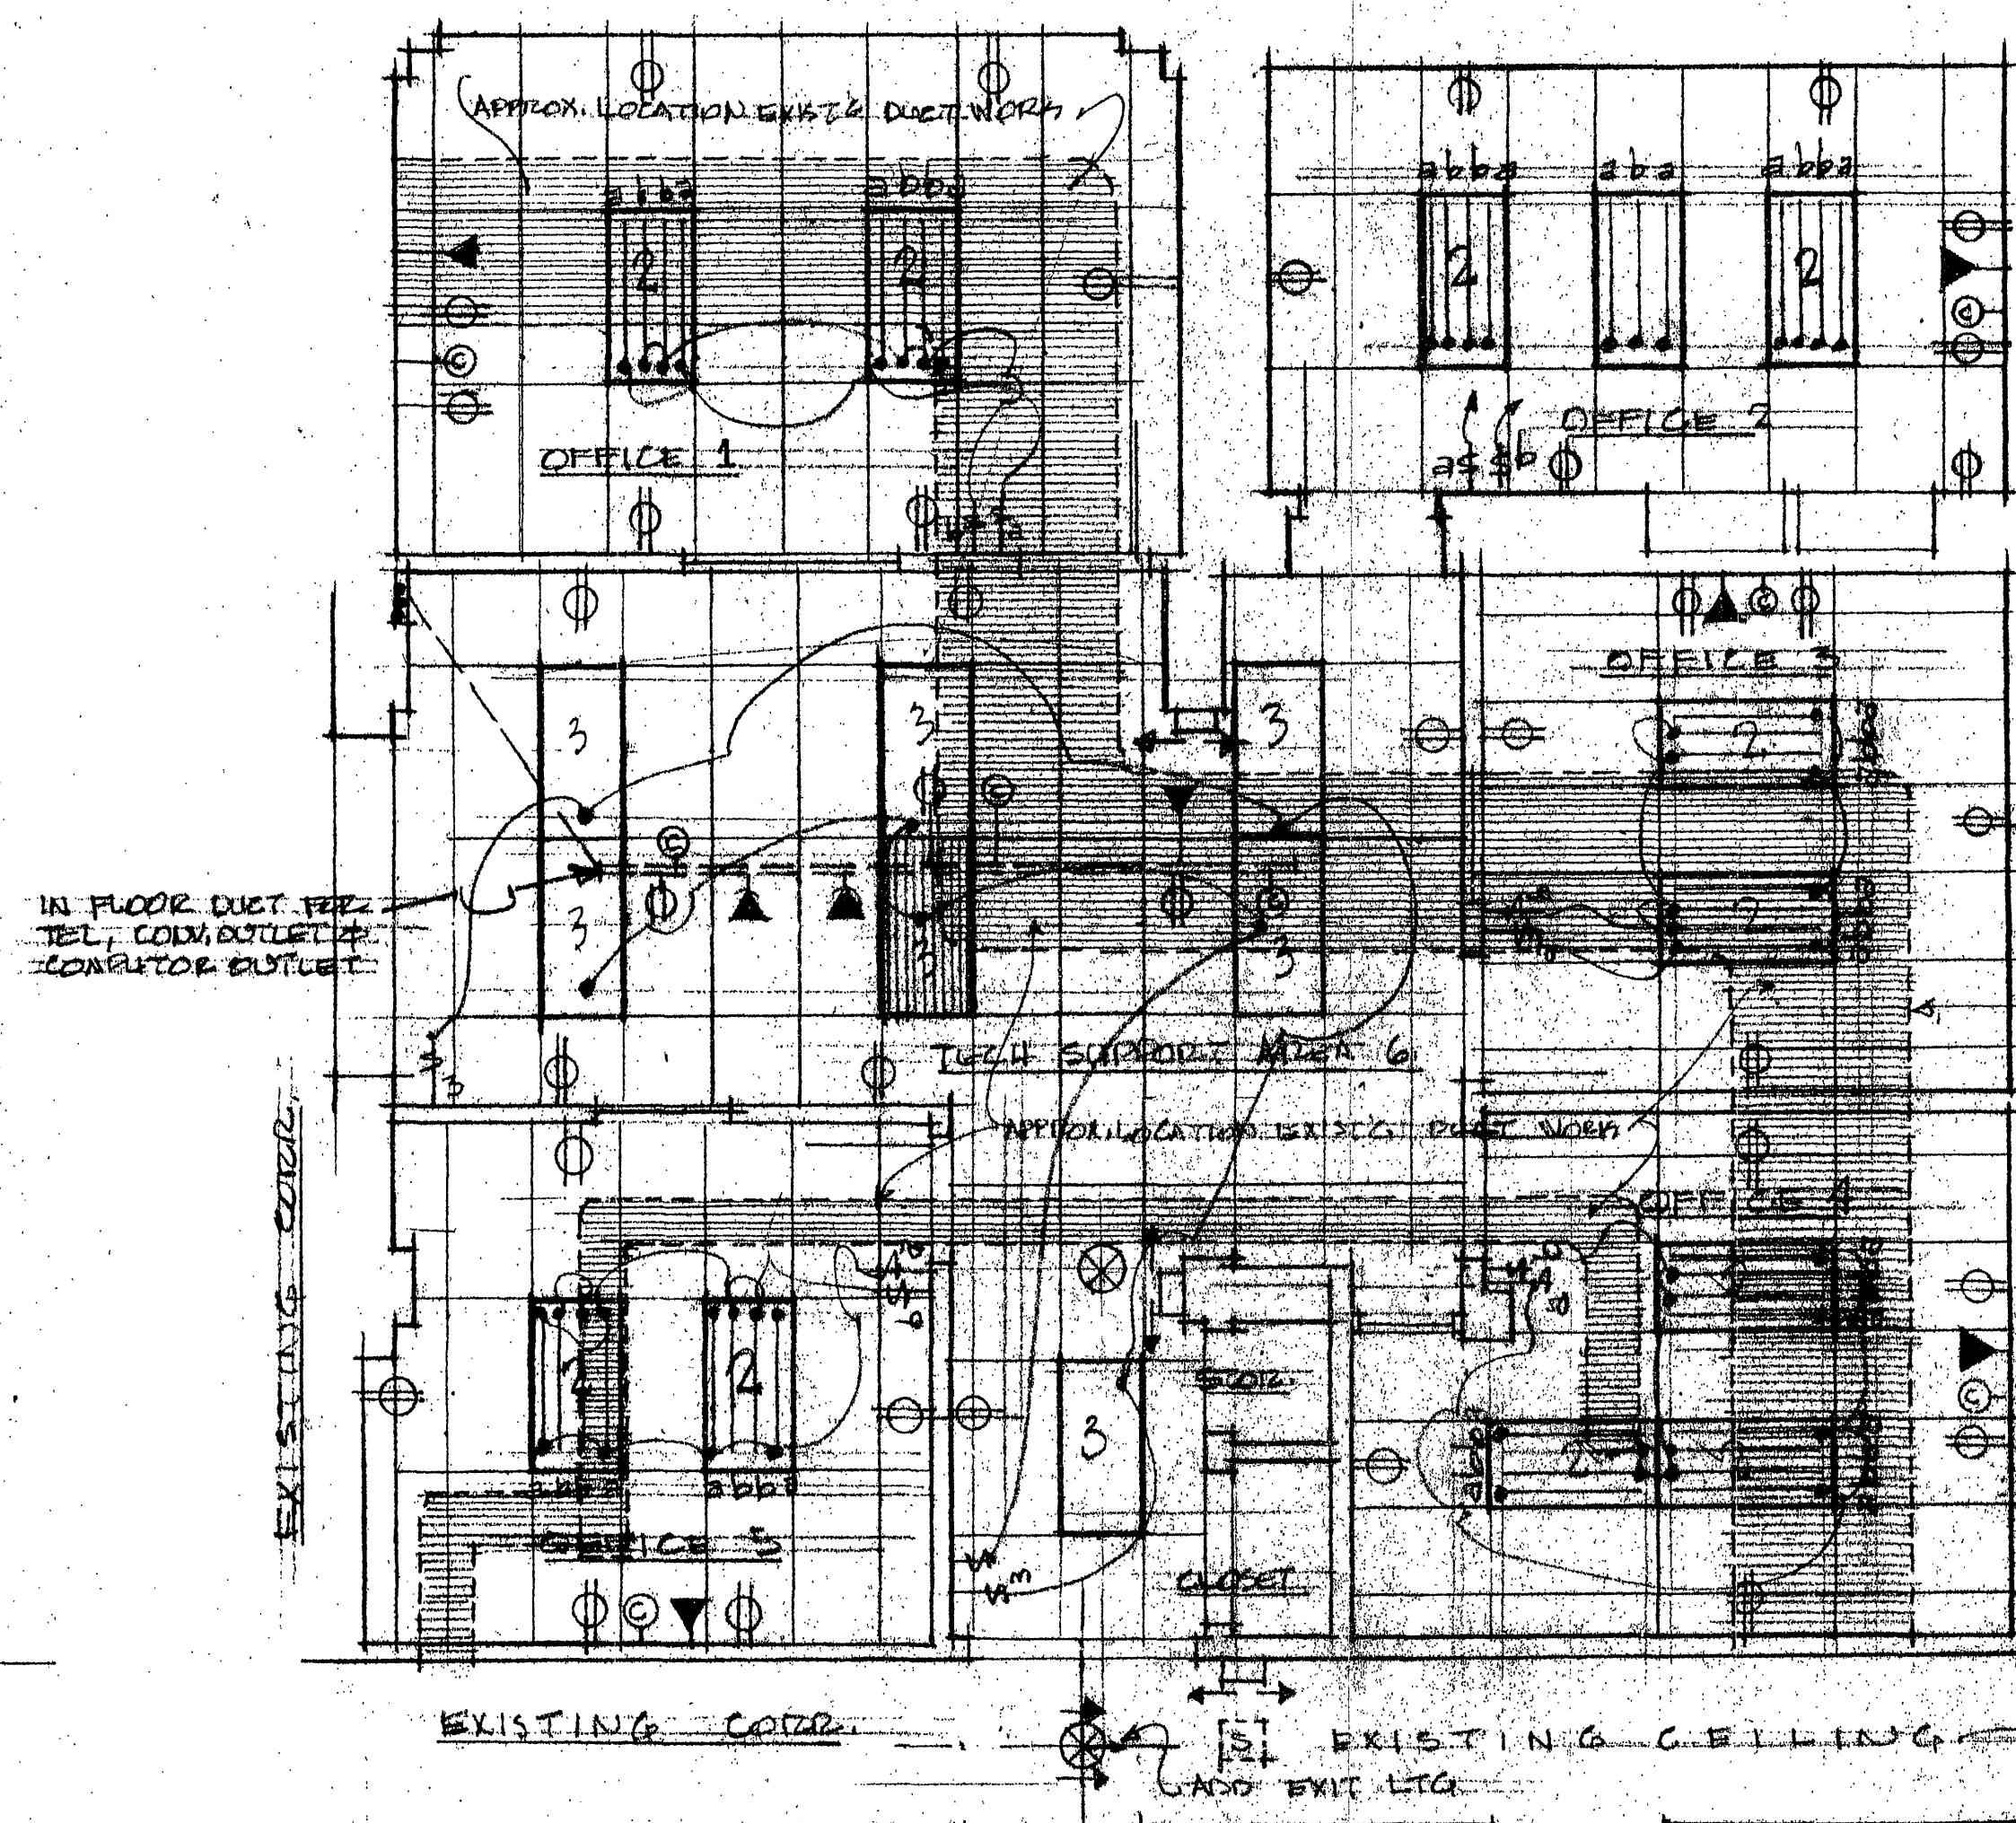


LIGHTING & POWER PLAN

14' = 1'-0"

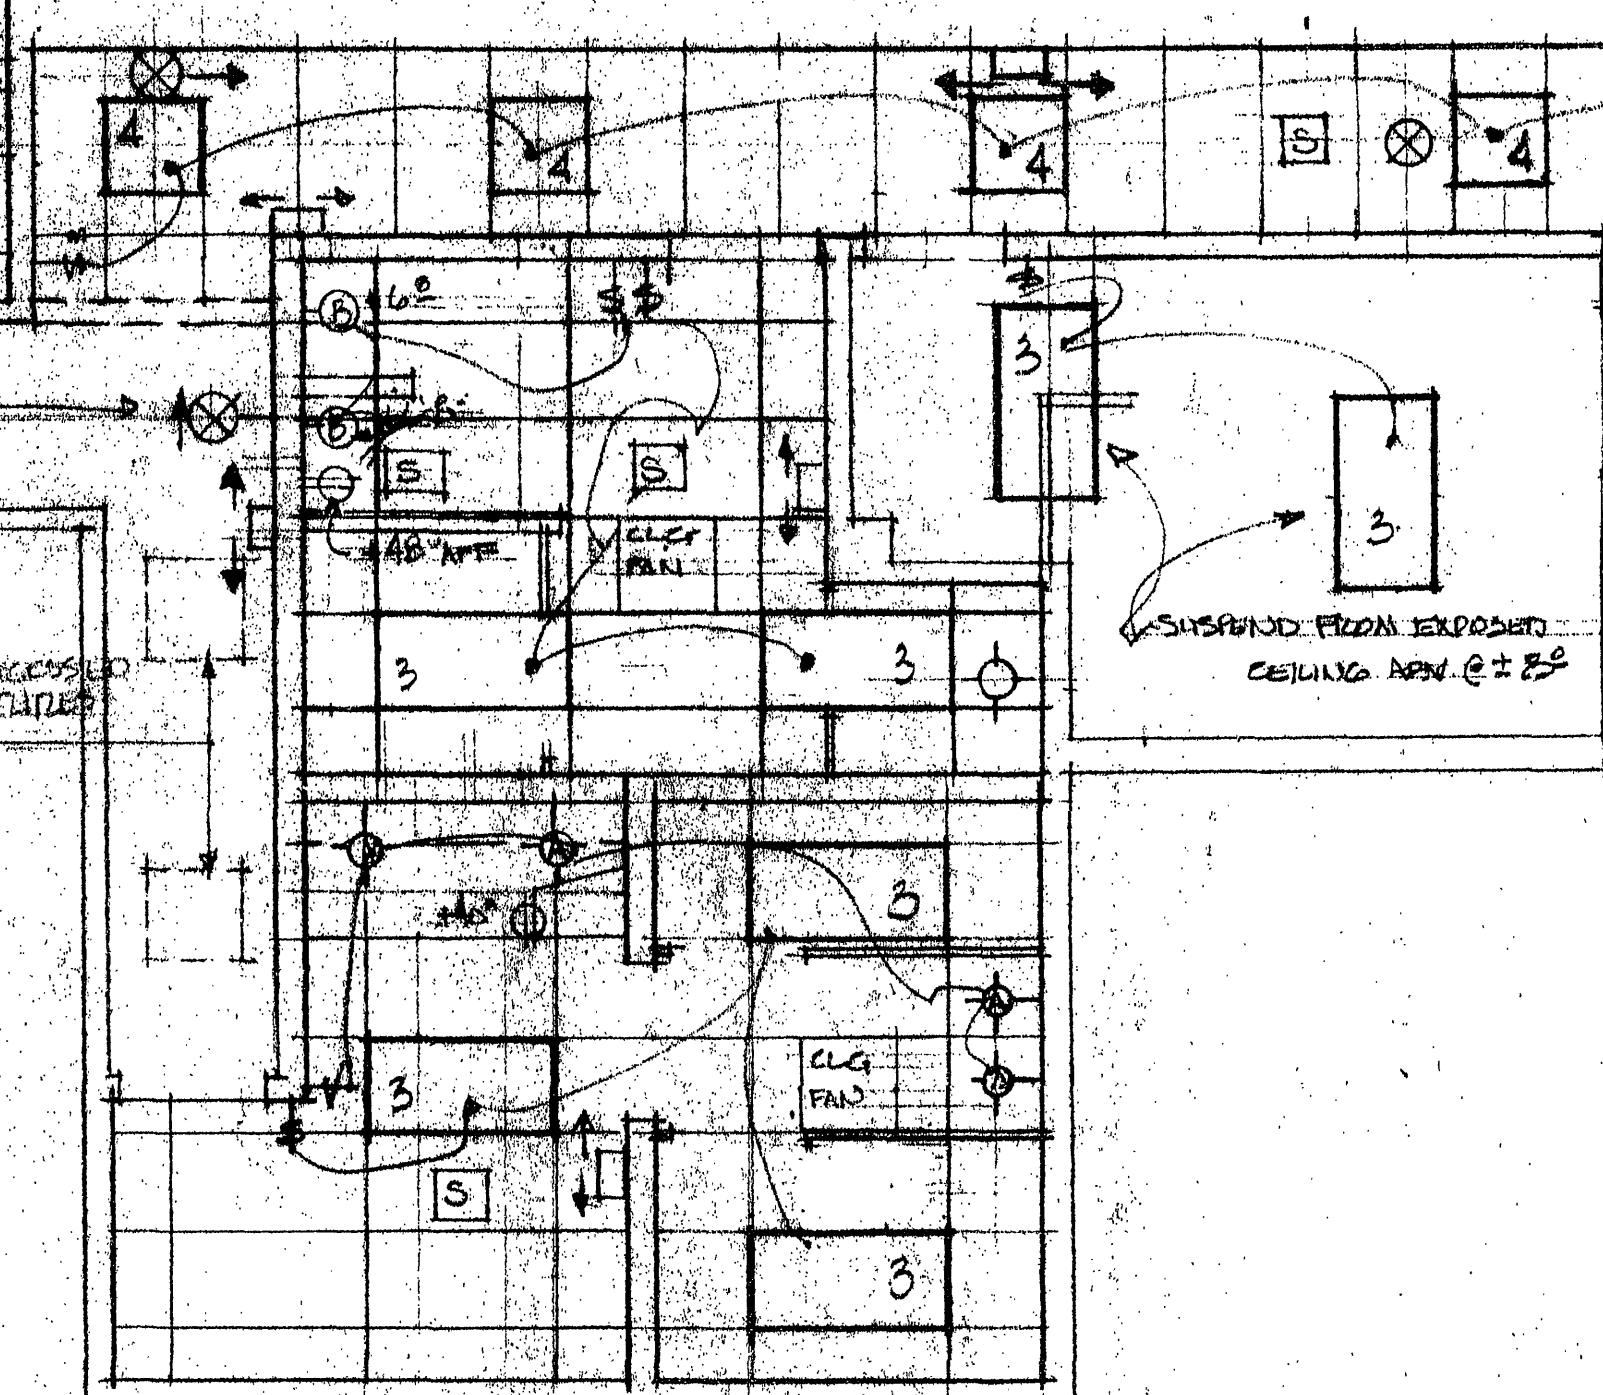

NOTE: EXISTING DUCT WORK
IN CEILINGS OF EXISTING TOILET
ROOMS. CEILING HIGHS, FIXTURE
PLACEMENT MUST BE WORKED
AROUND EXISTING DUCTWORK.

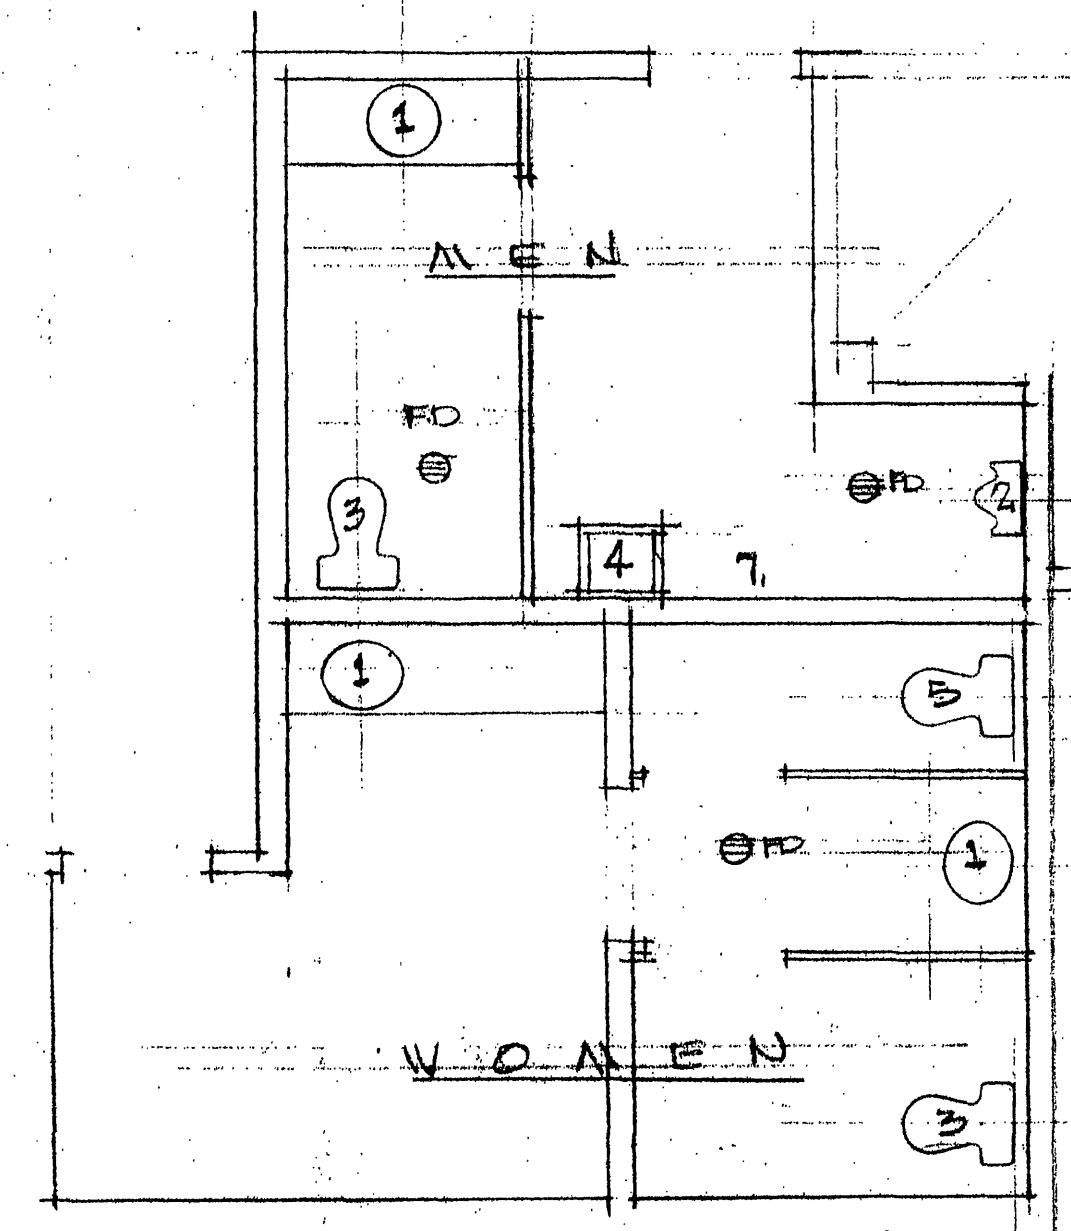

Schematic Plumbing Plan

SEE FLOOR PLAN FOR DIMENSIONS

PLUMBING FIXTURES

1. LAVATORY: AMERICAN STANDARD D420.011, WHITE, EASY-SET FAUCET HOLES, PALECEYAN STD 2000.101 W/ AERATOR, POP-UP DRAIN, ALL EXPOSED PIPING & FAUCETS CHROME PLATED.
2. URINAL: WALL ATD: LYNNBROOK 101, 6601.012, WHITE, SLOAN 1/2" POT FLOW VALVE.
3. WATER CLOSET: AMERICAN STANDARD 72108.408, WHITE, ELONGATED BOWL, H.C. HEIGHT, WHITE SEAT / COVER FOR ELONGATED BOWL, CHROME SUPPLY & STOP.
4. WALL HUNG LAVATORY: REUSE EXISTING.
5. WATER CLOSET: AMERICAN STANDARD 72292.100, WHITE, WHITE SEAT / COVER, CHROME SUPPLY & STOP, EXISTING VALVE TO BE INSTALLED.
6. FLOOR DRAIN: 4" CAST BRASS, FLAT STREAMER CHROME PLATED.
7. WATER HEATER: AO SMITH ELEZ. 24 GA. 12.5A, 120 V MODEL ELC-23100 OR APPROVED EQUIVALENT, LOCATE HIGH ON WALL IN TOILET ROOM.

PLUMBING CONTRACTOR TO CONNECT SANITARY SERVER LINES FROM NEW TOILET ROOMS TO EXISTING SANITARY SERVER.

ELECTRICAL LEGEND

- 1 SURFACE MOUNTED 2x4 4-LAMP FLUORESCENT FIXTURES, ACRYLIC LENS, WHITE METAL FORMED LAMP BODY, FIXTURES TO BE SUSPENDED FROM STRUCTURE ABOVE @ ± 8F. A PP.
- 2 2x4 RECESSED FLUORESCENT FIXTURE IN ACUSTIC CEILING, (4) 40W LAMPS, WHITE FORMED STEEL BODY, ACRYLIC LENS, 2 LEVEL LIGHTING, WILLIAMS 30G-524-4230C-SWKA 125, OR EQUAL.
- 3 2x4 RECESSED FLUORESCENT FIXTURE IN ACUSTIC CEILING, (6) 40W LAMPS, WHITE FORMED STEEL BODY, ACRYLIC LENS, WILLIAMS 30G-524-2320C-SWKA 125 OR EQUAL.
- 4 FIXTURE 3 & FIXTURE 4 WIRED FOR 24 HOUR OPERATION.
- 5 2x2 RECESSED FLUORESCENT FIXTURE, ACRYLIC LENS, WHITE FORMED STEEL BODY, (2) 40W LAMPS, MATCH EXISTING 2x2 FIXTURES.
- 6 SELF-Powered EXIT FIXTURE, CEILING MTD, UNLESS NOTED OTHERWISE, RED OR GREEN LETTERS & ARROWS WHERE INDICATED, W/ BACK-UP PHOTOELEC BACK-UP OPERATION, 90 MINUTE RESERVE, HIGH LITES BY 120V PLUG-IN, LAMPS.
- 7 WALL MOUNTED EMERGENCY FIXTURE W/ TWO HEADS, BATTERY BACK-UP W/ 90 MINUTE RESERVE, MOUNT NOMINAL 2' BELOW CEILING, HI-LITES HL-BD, 6 VOL 10 WATTS.
- 8 SURFACE MOUNTED, (4) 60W LAMPS, EXTRUDED ALUM. BODY, PRICESCOLITE 32040-4, OR EQUAL, VERTICAL MOUNTING UNLESS NOTED "H".
- 9 DUPLEX CONVENIENCE OUTLET, 120 V, IVORY PLATE & WIRING, DEVICE ± 24 AFF.
- 10 COMPUTER OUTLET, BE TO PROVIDE IN WALL BOX, W/ 1/2" CONDUIT, MINIMUM 12" ABV. CEILING, COMPUTER SYSTEM BY OWNER.
- 11 TELEPHONE OUTLET, BE TO PROVIDE J-BOX W/ 3/4" CONDUIT FROM BOX TO MINIMUM 12" ABV. CEILING, COMPUTER SYSTEM PROVIDED & INSTALLED BY OWNER.
- 12 LOCAL SWITCH, 120V, IVORY PLATE & DEVICE.
- 13 SMOKE DETECTOR, MATCH EXISTING DEVICES.
- 14 CEILING FAN(S) CONNECT TO DUCT WORK TO EXISTING TOILET ROOMS EXHAUST SYSTEM, CONSTANT 24 HR OPERATION.
- 15 PRICESCOLITE 4041, (2) 100W, 10 3/4" x 50" x 18" DEEP, BLACK T21A, WALL ATD @ ± 6' 8" AFF.

DRAWN BY:	SCOTT STRICKLAND
CHECKED BY:	SCOTT STRICKLAND
DATE:	3/10/03
SCALE:	1/2 INCH = 1'-0"
JOB NO.:	20110
SHEET:	2