

DATE: March 22, 2005
 REVISIONS:
 1 May 3, 2005
 2
 3
 4
 5

HUGHES ASSOCIATES ARCHITECTS
 Architecture • Planning • Consulting



656 ELM AVENUE, S.W.
 P.O. BOX 1034
 ROANOKE, VIRGINIA 24005-1034

TEL (540) 342-4002
 FAX (540) 342-2060
 www.HughesArchitects.com

ALTERATIONS TO WESTERN VIRGINIA WATER AUTHORITY COULTER BUILDING
 601 South Jefferson Street Roanoke, Virginia

ENLARGED FLOOR PLAN (TELEPHONE, DATA, POWER & ELECTRICAL)
 PHASE 1

COMMISSION No. 04102
 SHEET **E1-4**
 No. 11 of 13
 COPYRIGHT 2005 HUGHES ASSOCIATES ARCHITECTS

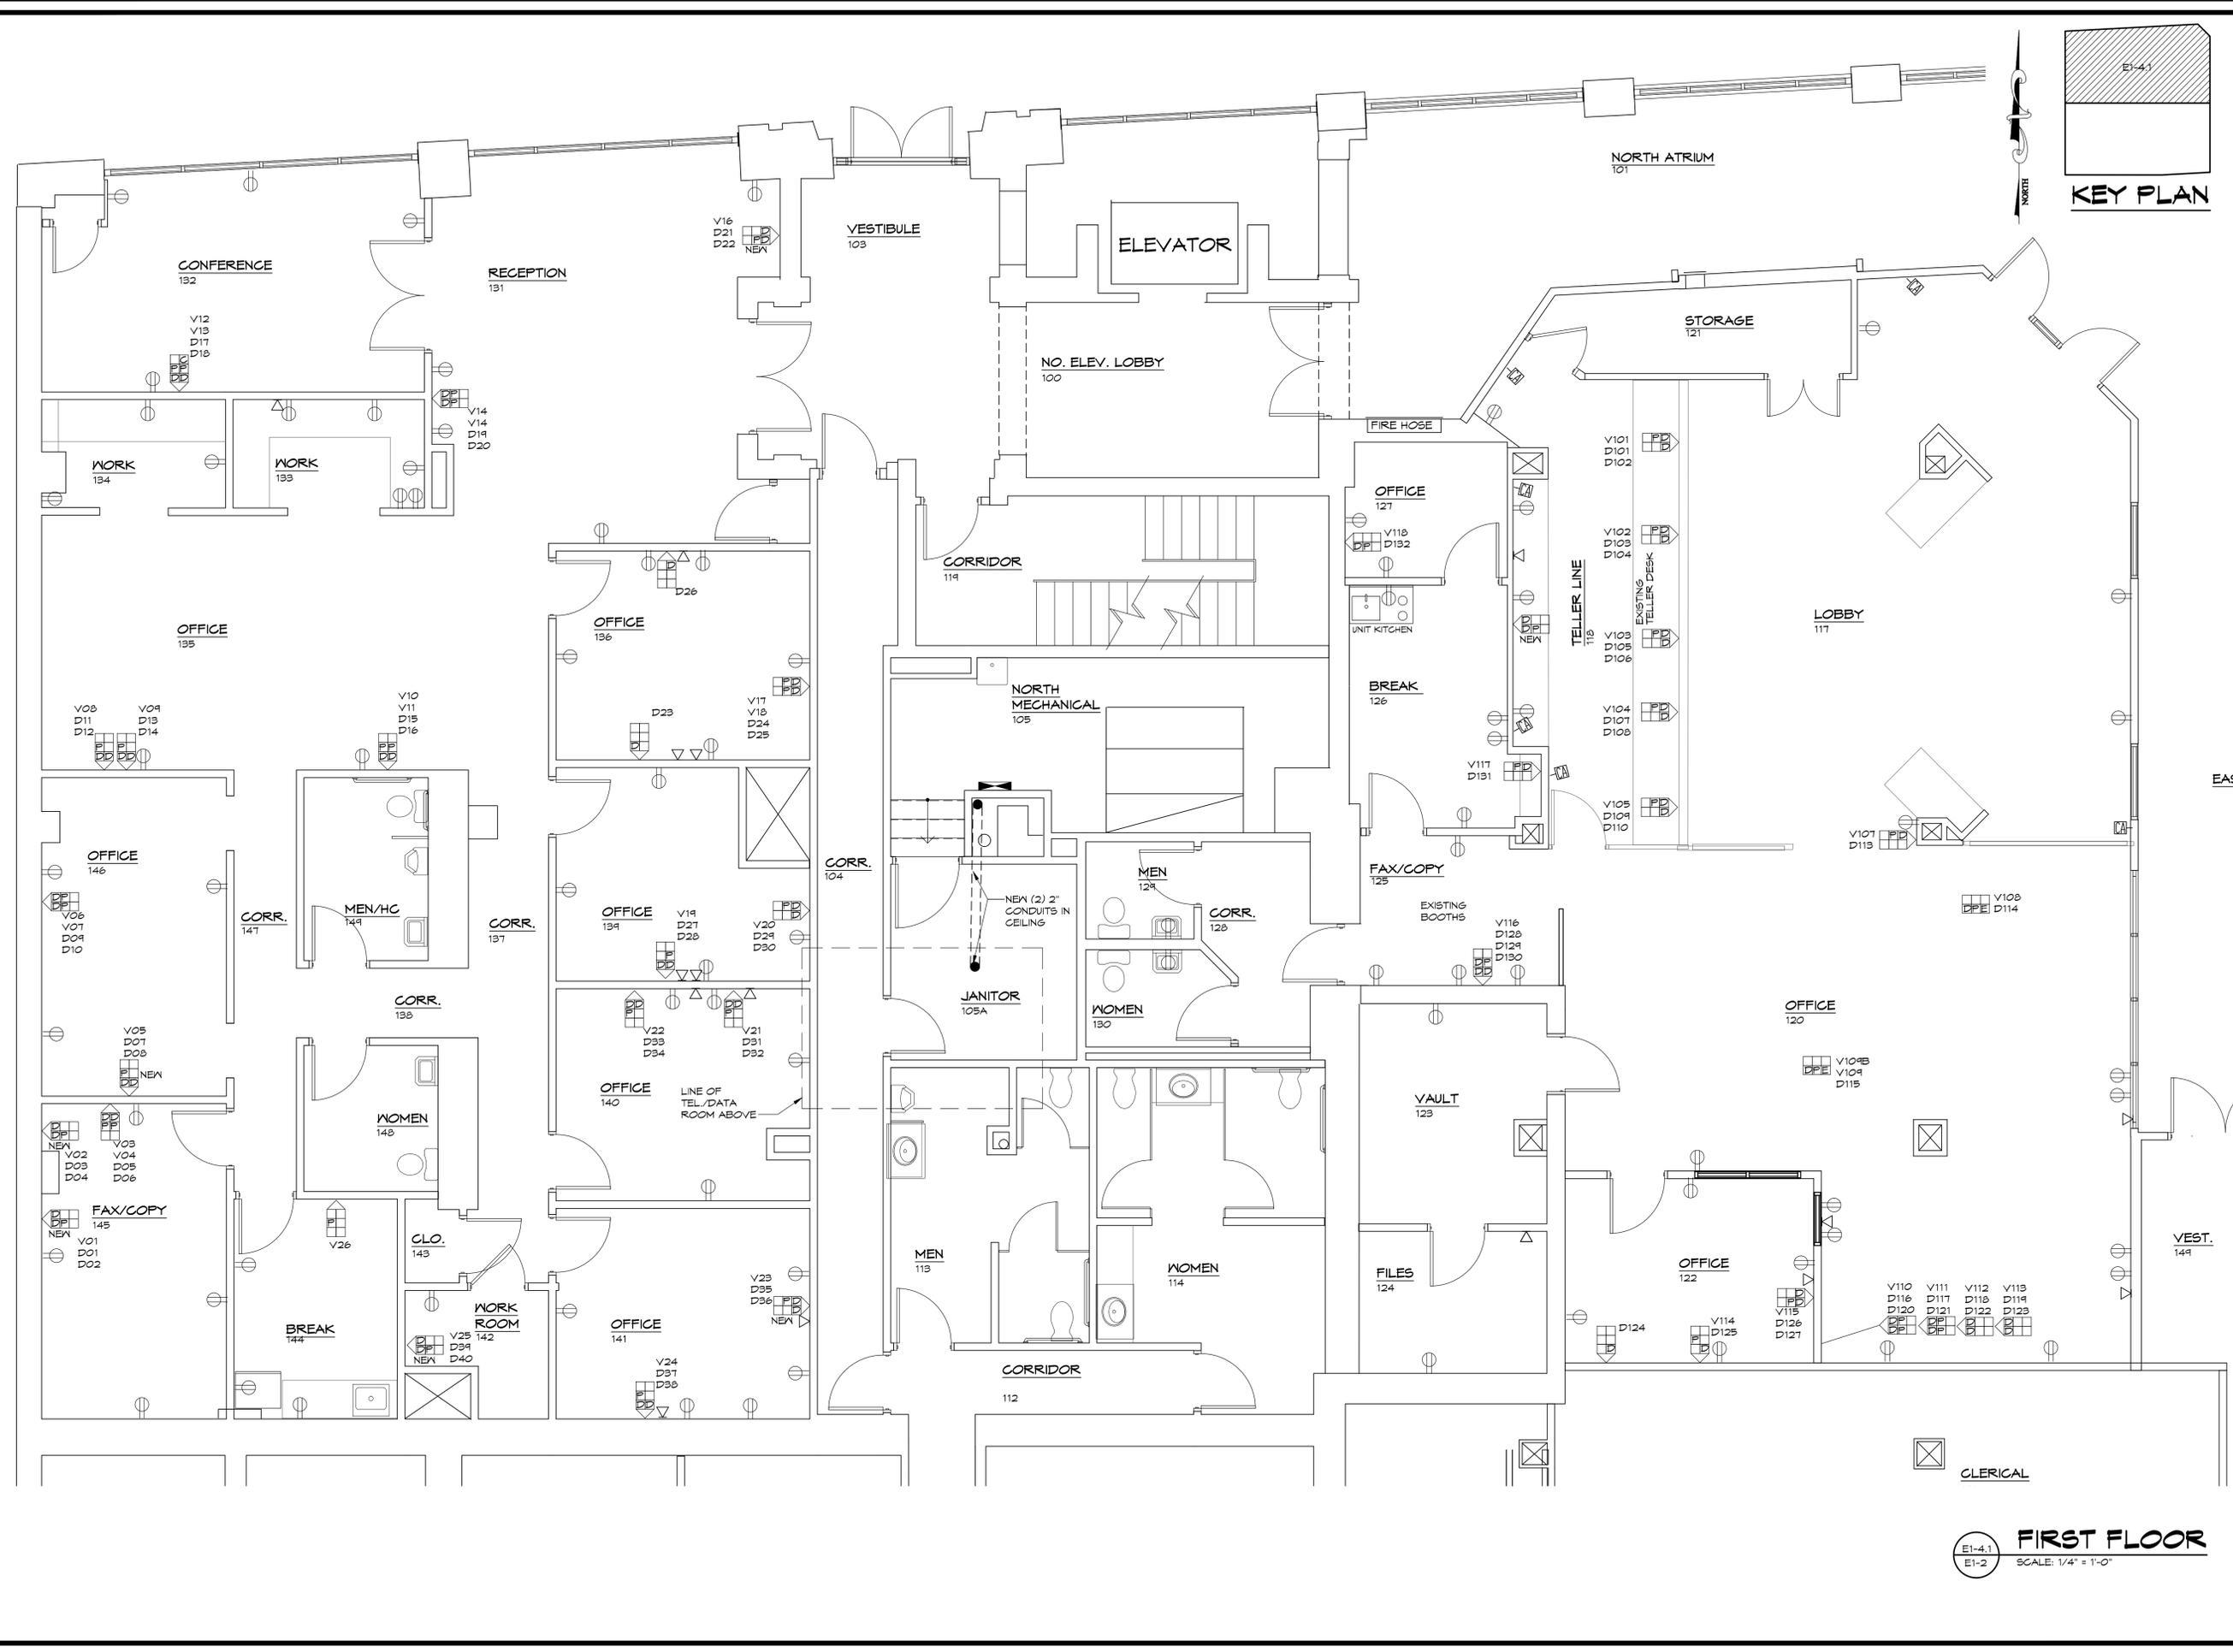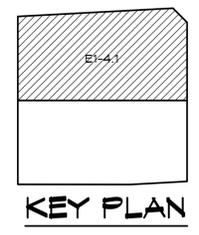

FIRST FLOOR
 SCALE: 1/4" = 1'-0"

CLERICAL