

## NOTES:

1 CONTRACTOR SHALL VERIFY SIZE AND LOCATION OF OPENING SHOWN FOR EXHAUST FAN WITH MANUFACTURES RECOMMENDATION AND HVAC DRAWINGS. OPENING IN ROOF PLANKS FOR REFRIGERANT LINES NOT SHOWN. COORDINATE SIZE AND LOCATION OF OPENING FOR REFRIGERANT LINES WITH HVAC DRAWINGS AND FIELD PLACEMENT OF HVAC EQUIPMENT

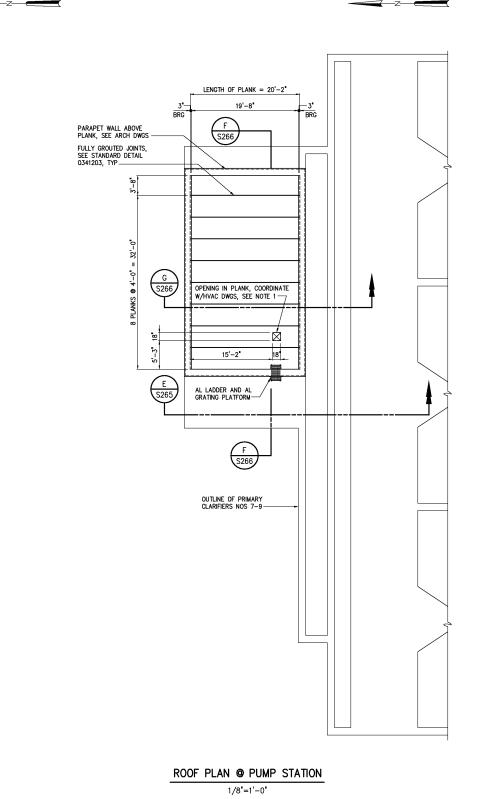

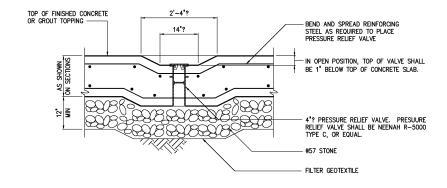

PRESSURE RELIEF VALVES

DETAIL 22

3/4\*=1'-0\* \$260

				DESIGNED AGM
				DRAWNAGM
				CHECKED
	RECORD DRAWINGS	MAR 2008	RLT	
	CONSTRUCTION	MAR 2004	RLT	PROJ. ENGRDAN
	REGULATORY APPROVAL	NOV 2003	RLT	
	PRELIMINARY DESIGN	NOV 2002	RLT	
NO.	ISSUED FOR	DATE	BY	APPROVED

(K) (S266)

G S266

E S265

3'-4" MFR VERIFY

3'-4" MFR VERIFY EL 905.00 -

⊢EL 905.00

F S266 8 27

3'-4" MFR

> THIS DOCUMENT ORIGINALLY ISSUED FOR CONSTRUCTION AND SEALED BY ROBERT S. DIFIORE, SEAL NO. 22769

INTERMEDIATE PLAN

1/8"=1'-0"

OPENING IN WALL,
TYP OF 3 PLACES-7

THIS DOCUMENT ORIGINALLY ISSUED FOR CONSTRUCTION AND SEALED BY RONALD L. TAYLOR, SEAL NO. 024649

## RECORD DRAWING

THIS DRAWING HAS BEEN MODIFIED TO REFLECT FIELD CHANGES REPORTED BY THE CONTRACTOR OR ANOTHER PARTY, BUT NOT VERIFIED BY THE CERTIFYING ENGINEER. THIS DOCUMENT ORIGINALLY ISSUED AND SEALED BY CHRISTOPHET. PHILLIPS, 033796. THIS MEDIA SHALL NOT BE CONSIDERED A CERTIFIED DOCUMENT.

## HAZEN AND SAWYER Environmental Engineers & Scientists 4011 WestChase Blvd, Raleigh, North Carolina 27607

## CITY OF ROANOKE VIRGINIA

REGIONAL WATER POLLUTION CONTROL PLANT WET WEATHER IMPROVEMENTS

PRIMARY CLARIFIERS NOS 7-9
STRUCTURAL
INTERMEDIATE AND PUMP STATION ROOF PLANS

THE SCALE BAR	DATE
SHOWN BELOW	Н &
MEASURES ONE	NUM
INCH LONG ON	CO
THE ORIGINAL	Ιਔ
DRAWING.	

BAR	DATE JUL	Y 2003
LOW	H & S JOB NUMBER	30788
ON NAL	CONTRACT NUMBER	DRAWING NUMBER
	Α	S261