
NOTES:

1 SEE DRAWING NO. A2 FOR DOOR SCHEDULE.

2 SEE DRAWING NO. A1 FOR ROOM FINISH SCHEDULE.

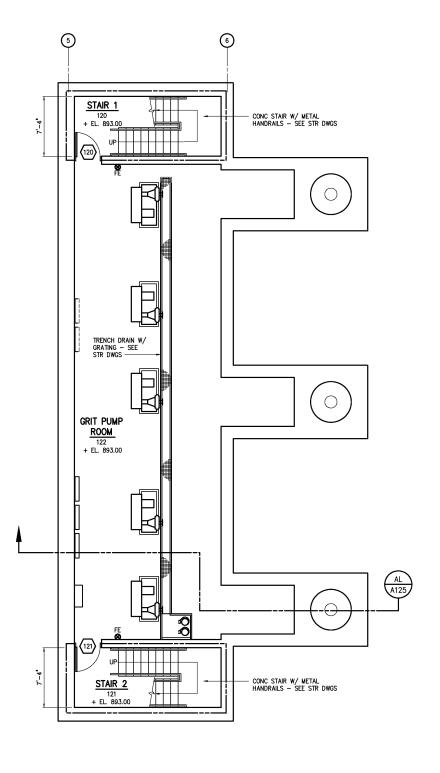

BOTTOM PLAN 3/16"=1'-0"

LEGEND:

1-HR FIRE RATED PARTITION DOOR NUMBER - SEE DRAWING NO. A2



FE- FIRE EXTINGUISHER

				DESIGNED WHR/DAW DRAWN ALB/DAW	
	DECORD DE MINIOS	WID 0000		CHECKED	
	RECORD DRAWINGS CONSTRUCTION	MAR 2008 MAR 2004	RLT RLT	PROJ. ENGR. DAN	
	REGULATORY APPROVAL	NOV 2003	RLT	THOU. LITON.	
	PRELIMINARY DESIGN	NOV 2002	RLT		
NO.	ISSUED FOR	DATE	BY	APPROVED	

THIS DOCUMENT ORIGINALLY ISSUED FOR CONSTRUCTION AND SEALED BY ROBERT S. DIFIORE, SEAL NO. 22769

THIS DOCUMENT ORIGINALLY ISSUED FOR CONSTRUCTION AND SEALED BY RONALD L. TAYLOR, SEAL NO. 024649

RECORD DRAWING

THIS DRAWING HAS BEEN MODIFIED TO REFLECT FIELD CHANGES REPORTED BY THE CONTRACTOR OR ANOTHER PARTY, BUT NOT VERIFIED BY THE CERTIFYING ENGINEER. THIS DOCUMENT ORIGINALLY ISSUED AND SEALED BY WILLIAM H. RUSSELL, SEAL NUMBER OBS\$32. THIS MEDIA SHALL NOT BE CONSIDERED A CERTIFIED DOCUMENT.

HAZEN AND SAWYER Environmental Engineers & Scientists 4011 WestChase Blvd, Raleigh, North Carolina 27607

CITY OF ROANOKE VIRGINIA

REGIONAL WATER POLLUTION CONTROL PLANT WET WEATHER IMPROVEMENTS

PRELIMINARY TREATMENT FACILITIES ARCHITECTURAL BOTTOM PLAN

THE SCALE BAR	D
SHOWN BELOW	н
MEASURES ONE	N
INCH LONG ON	⊢
THE ORIGINAL	ı
DRAWING.	ı
	ı

BAR	DATE JUI	Y 2003
LOW	H & S JOB NUMBER	30788
ON NAL	CONTRACT NUMBER	DRAWING NUMBER
	/ \	/ / 120